

RECEIVED
FEB 06 2001
PRIME CONSTRUCTION GROUP, INC.


LEGAL DESCRIPTION:

A PARCEL OF LAND LYING IN THE NORTHWEST 1/4 OF SECTION 13, TOWNSHIP 24 SOUTH, RANGE 29 EAST, ORANGE COUNTY, FLORIDA, BEING MORE PARTICULARLY DESCRIBED AS FOLLOWS:

COMMENCE AT THE NORTHWEST CORNER OF SECTION 13, TOWNSHIP 24 SOUTH, RANGE 29 EAST; THENCE RUN N 89°59'27"E, ALONG THE NORTH LINE OF SAID SECTION 13, A DISTANCE OF 2247.54 FEET; THENCE DEPARTING SAID NORTH LINE RUN S 00°00'33"E, A DISTANCE OF 1345.75 FEET TO THE SOUTHERLY RIGHT OF WAY LINE OF A 120 FEET WIDE ORLANDO UTILITIES COMMISSION RAILROAD RIGHT OF WAY; THENCE ALONG SAID SOUTHERLY RIGHT OF WAY THE FOLLOWING COURSES AND DISTANCES: N 89°58'23"E, A DISTANCE OF 1059.64 FEET; THENCE RUN S 00°01'37"E, A DISTANCE OF 28.60 FEET; THENCE RUN N 89°58'30"E, A DISTANCE OF 752.00 FEET; THENCE DEPARTING SAID RIGHT OF WAY LINE RUN S 00°04'11"E, A DISTANCE OF 1019.47 FEET; THENCE RUN S 89°55'49"E, A DISTANCE OF 287.98 FEET TO THE POINT OF BEGINNING; THENCE CONTINUE S 89°55'49"E, A DISTANCE OF 221.73 FEET; THENCE RUN S 22°08'56"E, A DISTANCE OF 8.78 FEET; THENCE RUN S 35°22'51"W, A DISTANCE OF 78.85 FEET; THENCE RUN S 52°10'13"W, A DISTANCE OF 77.69 FEET; THENCE RUN S 41°16'30"W, A DISTANCE OF 43.12 FEET; THENCE RUN S 11°10'34"W, A DISTANCE OF 78.66 FEET; THENCE RUN S 42°09'04"E, A DISTANCE OF 65.91 FEET; THENCE RUN S 40°09'20"E, A DISTANCE OF 69.29 FEET; THENCE RUN S 32°54'21"E, A DISTANCE OF 64.08 FEET; THENCE RUN S 37°18'00"E, A DISTANCE OF 180.71 FEET; THENCE RUN N 60°43'31"E, A DISTANCE OF 183.81 FEET; THENCE RUN N 70°42'33"E, A DISTANCE OF 98.39 FEET; THENCE RUN N 69°22'29"E, A DISTANCE OF 51.46 FEET; THENCE RUN N 60°56'58"E, A DISTANCE OF 30.54 FEET; THENCE RUN N 33°31'21"W, A DISTANCE OF 383.73 FEET; THENCE RUN N 00°04'11"W, A DISTANCE OF 35.00 FEET; THENCE RUN N 44°55'49"E, A DISTANCE OF 28.28 FEET TO THE POINT OF BEGINNING.

CONTAINING: 174,325.50 SQUARE FEET/4.00 ACRES.

THE ABOVE DESCRIBED PARCEL BEING MORE PARTICULARLY DESCRIBED AS: LOT 7, JETPORT ADDITION NO. 1, ACCORDING TO THE PLAT THEREOF AS RECORDED IN PLAT BOOK 44, PAGES 29 - 34, OF THE PUBLIC RECORDS OF ORANGE COUNTY, FLORIDA.

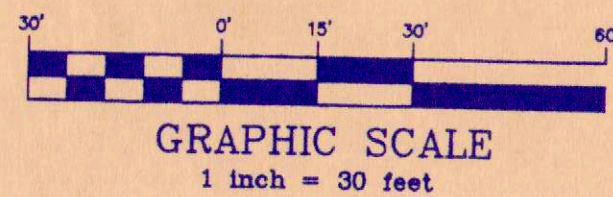

TRACT D
(CONSERVATION & OPEN SPACE)

TRACT E
(RETENTION)

WATER ELEVATION = 78.20'

LEGEND:

- HALOGEN LIGHT
- SITE BENCHMARK
- MANHOLE
- TELEPHONE CABINET
- 100.0' SPOT ELEVATION
- WATER VALVE
- METAL LIGHT POLE
- ELECTRIC RISER
- POWER POLE
- FIRE HYDRANT
- WATER METER
- ROAD SIGN
- METERED END SECTION
- TELEPHONE WARNING MARKER
- EXISTING CONTOUR
- BURIED CABLE TELEVISION LINE
- BURIED TELEPHONE LINE
- BURIED POWER LINE
- BURIED WATER LINE
- BURIED GAS LINE
- OVERHEAD POWER LINE
- SOIL BORING SITE

ABBREVIATIONS:

- CALC - CALCULATED
- CH BRG - CHORD BEARING
- EL/ELEV - ELEVATION
- INV - INVERT
- LB - LICENSED BUSINESS
- LS - LAND SURVEYOR
- OR - OFFICIAL RECORDS BOOK
- PC - POINT OF CURVATURE
- PI - POINT OF INTERSECTION
- PT - POINT OF TANGENCY
- PVC - POLYVINYLCHLORIDE PIPE
- ERCP - ELLIPTICAL REINFORCED CONCRETE PIPE
- RCC - REINFORCED CONCRETE PIPE
- R/W - RIGHT-OF-WAY
- Δ - DELTA (CENTRAL ANGLE)
- R - RADIUS
- L - ARC LENGTH
- C - CENTERLINE

DETAIL
(NOT TO SCALE)

TRACT D
(CONSERVATION & OPEN SPACE)

TRACT D
(CONSERVATION & OPEN SPACE)

NOTES:

- BEARINGS SHOWN HEREON ARE BASED ON THE NORTH LINE OF THE NW 1/4 OF SECTION 13-24-29 AS BEING N89°59'27"E.
- UNDERGROUND FOUNDATIONS AND UTILITIES WERE NOT LOCATED AS A PART OF THIS SURVEY.
- LANDS SHOWN HEREON WERE NOT ABSTRACTED FOR RIGHT-OF-WAYS, EASEMENTS, OWNERSHIP AND OTHER INSTRUMENTS OF RECORD.
- BASED ON THE FEDERAL EMERGENCY MANAGEMENT AGENCY FLOOD INSURANCE RATE MAPS, COMMUNITY PANEL NUMBER 120179 0400 C, EFFECTIVE DATE AUGUST 5, 1986 THE PARCEL SHOWN HEREON LIES WITHIN FLOOD ZONES "A" & "C", AND DOES LIE WITHIN THE 100 YEAR FLOOD HAZARD AREA.
- ZONING: PLANNED UNIT DEVELOPMENT (INDUSTRIAL) SETBACKS: FRONT 35.0' SIDE 25.0' REAR 10.0' FROM PUD BOUNDARY 25.0'
- ELEVATIONS BASED ON ORANGE COUNTY BENCHMARK DESIGNATION NO. D-370-037; BEING A 2" ALUMINUM DISK IN A CONCRETE HEADWALL AT THE NORTHWEST CORNER OF MEADOW WOODS PROPERTY ELEVATION = 82.065.
- THE EASEMENT AGREEMENT AS RECORDED IN O.R. BOOK 5703 PAGE 4601 DOES NOT AFFECT THIS PARCEL.

CERTIFICATION:


PCG PROPERTIES, INC.
CITRUS BANK, N.A.
OLD REPUBLIC NATIONAL TITLE
INSURANCE COMPANY
MARLOWE, APPLETON & WEATHERFORD, P.A.
JOHN KINGMAN KEATING, P.A.

SURVEYOR'S CERTIFICATION:

This is to certify that this map or plat and the survey on which it is based were made (1) in accordance with "Minimum Standard Detail Requirements for ALTA/ACSM Land Title Surveys," jointly established and adopted by ALTA/ACSM in 1997, and includes items 1-13 of table A thereof, and (2) pursuant to the Accuracy Standards (as adopted by ALTA and ACSM and in effect on the date of this certification) of an "Urban" Survey.

William D. Donley, President
Florida Surveyor and Mapper
REGISTRATION NUMBER 5381

THIS SURVEY NOT VALID UNLESS EMBOSSED WITH THE ORIGINAL SIGNATURE AND RAISED SEAL.

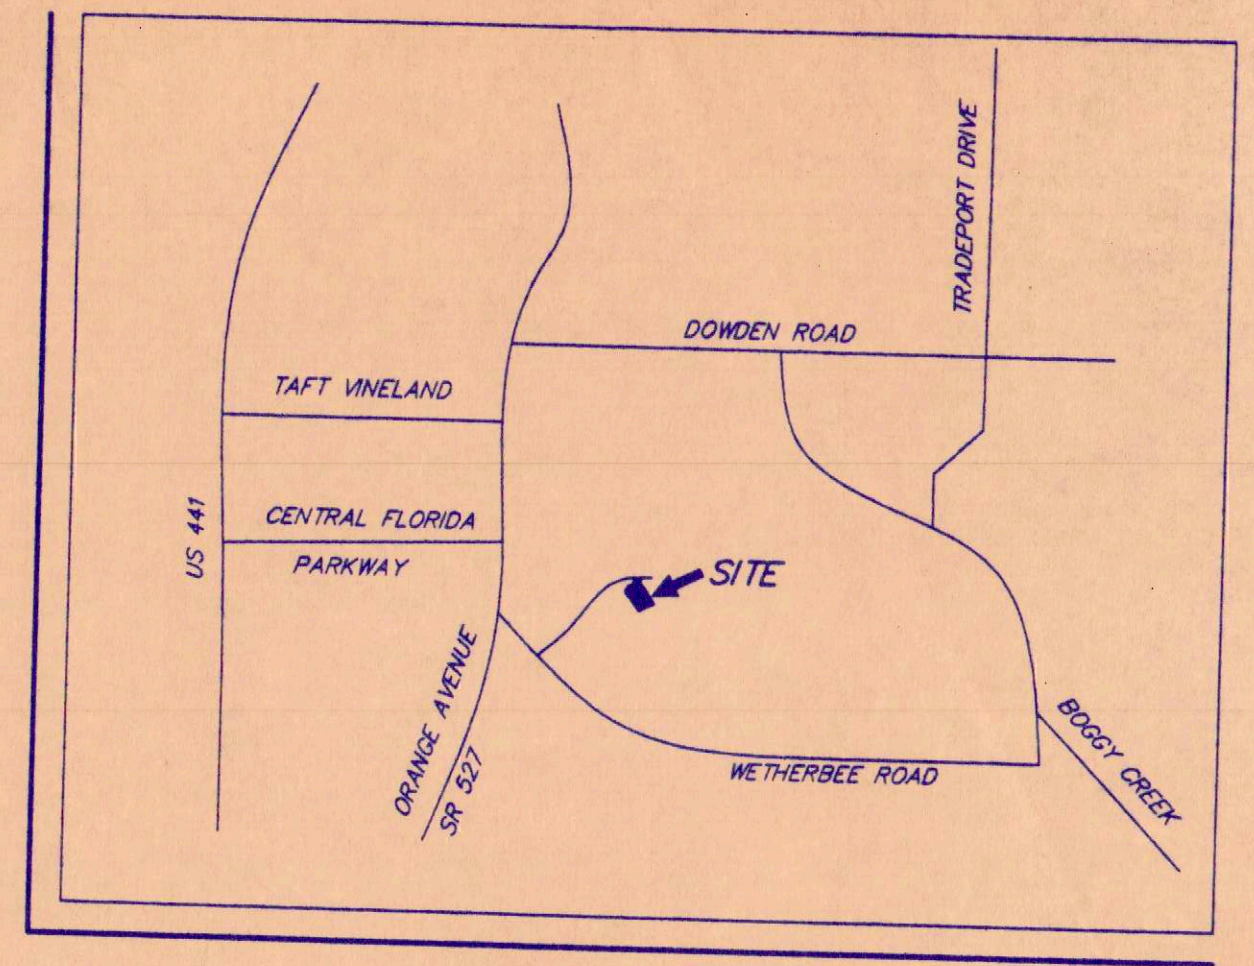

PROJECT NO. 1 OF 1

WORK ORDER 991480 (BOUNDARY) 300.039 991480 (CONSTRUCTION)



SCALE 1" = 30'

PLAT OF BOUNDARY SURVEY FOR:
PRIME CONSTRUCTION GROUP

LOT 7
JETPORT PARK ADDITION NO. 1
PLAT BOOK 44, PAGES 29 - 34.
SECTION 13, TOWNSHIP 24 SOUTH, RANGE 29 EAST, ORANGE COUNTY, FLORIDA.


DOWLEY & ASSOCIATES, INC.
SURVEYORS AND MAPPERS
420 EAST STATE ROAD 434, SUITE "F"
LONGWOOD, FLORIDA 32750
VOICE 407.260.1818 FAX 407.260.1848
(CERTIFICATE OF AUTHORIZATION NO. 6663)

NO.	DATE	DESCRIPTION	BY	CHKD
1	1/20/01	AS BUILT	W.D.	W.D.
2	1/20/01	AS BUILT	W.D.	W.D.
3	1/20/01	AS BUILT	W.D.	W.D.
4	1/20/01	AS BUILT	W.D.	W.D.
5	1/20/01	AS BUILT	W.D.	W.D.
6	1/20/01	AS BUILT	W.D.	W.D.
7	1/20/01	AS BUILT	W.D.	W.D.
8	1/20/01	AS BUILT	W.D.	W.D.
9	1/20/01	AS BUILT	W.D.	W.D.
10	1/20/01	AS BUILT	W.D.	W.D.

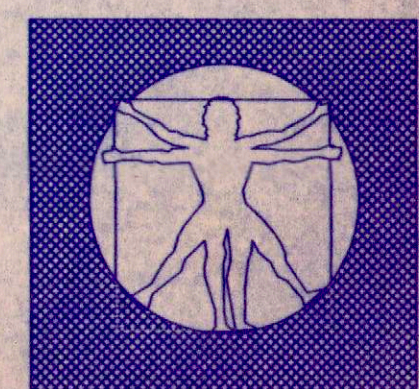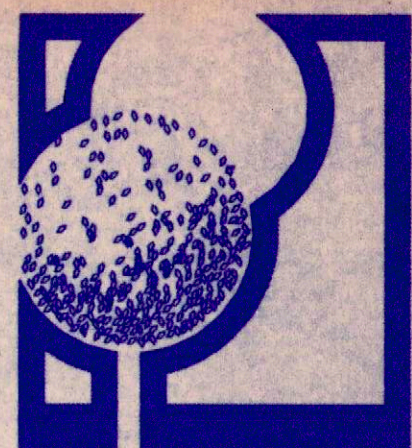

IRRIGATION AS-BUILTS

AS BUILT

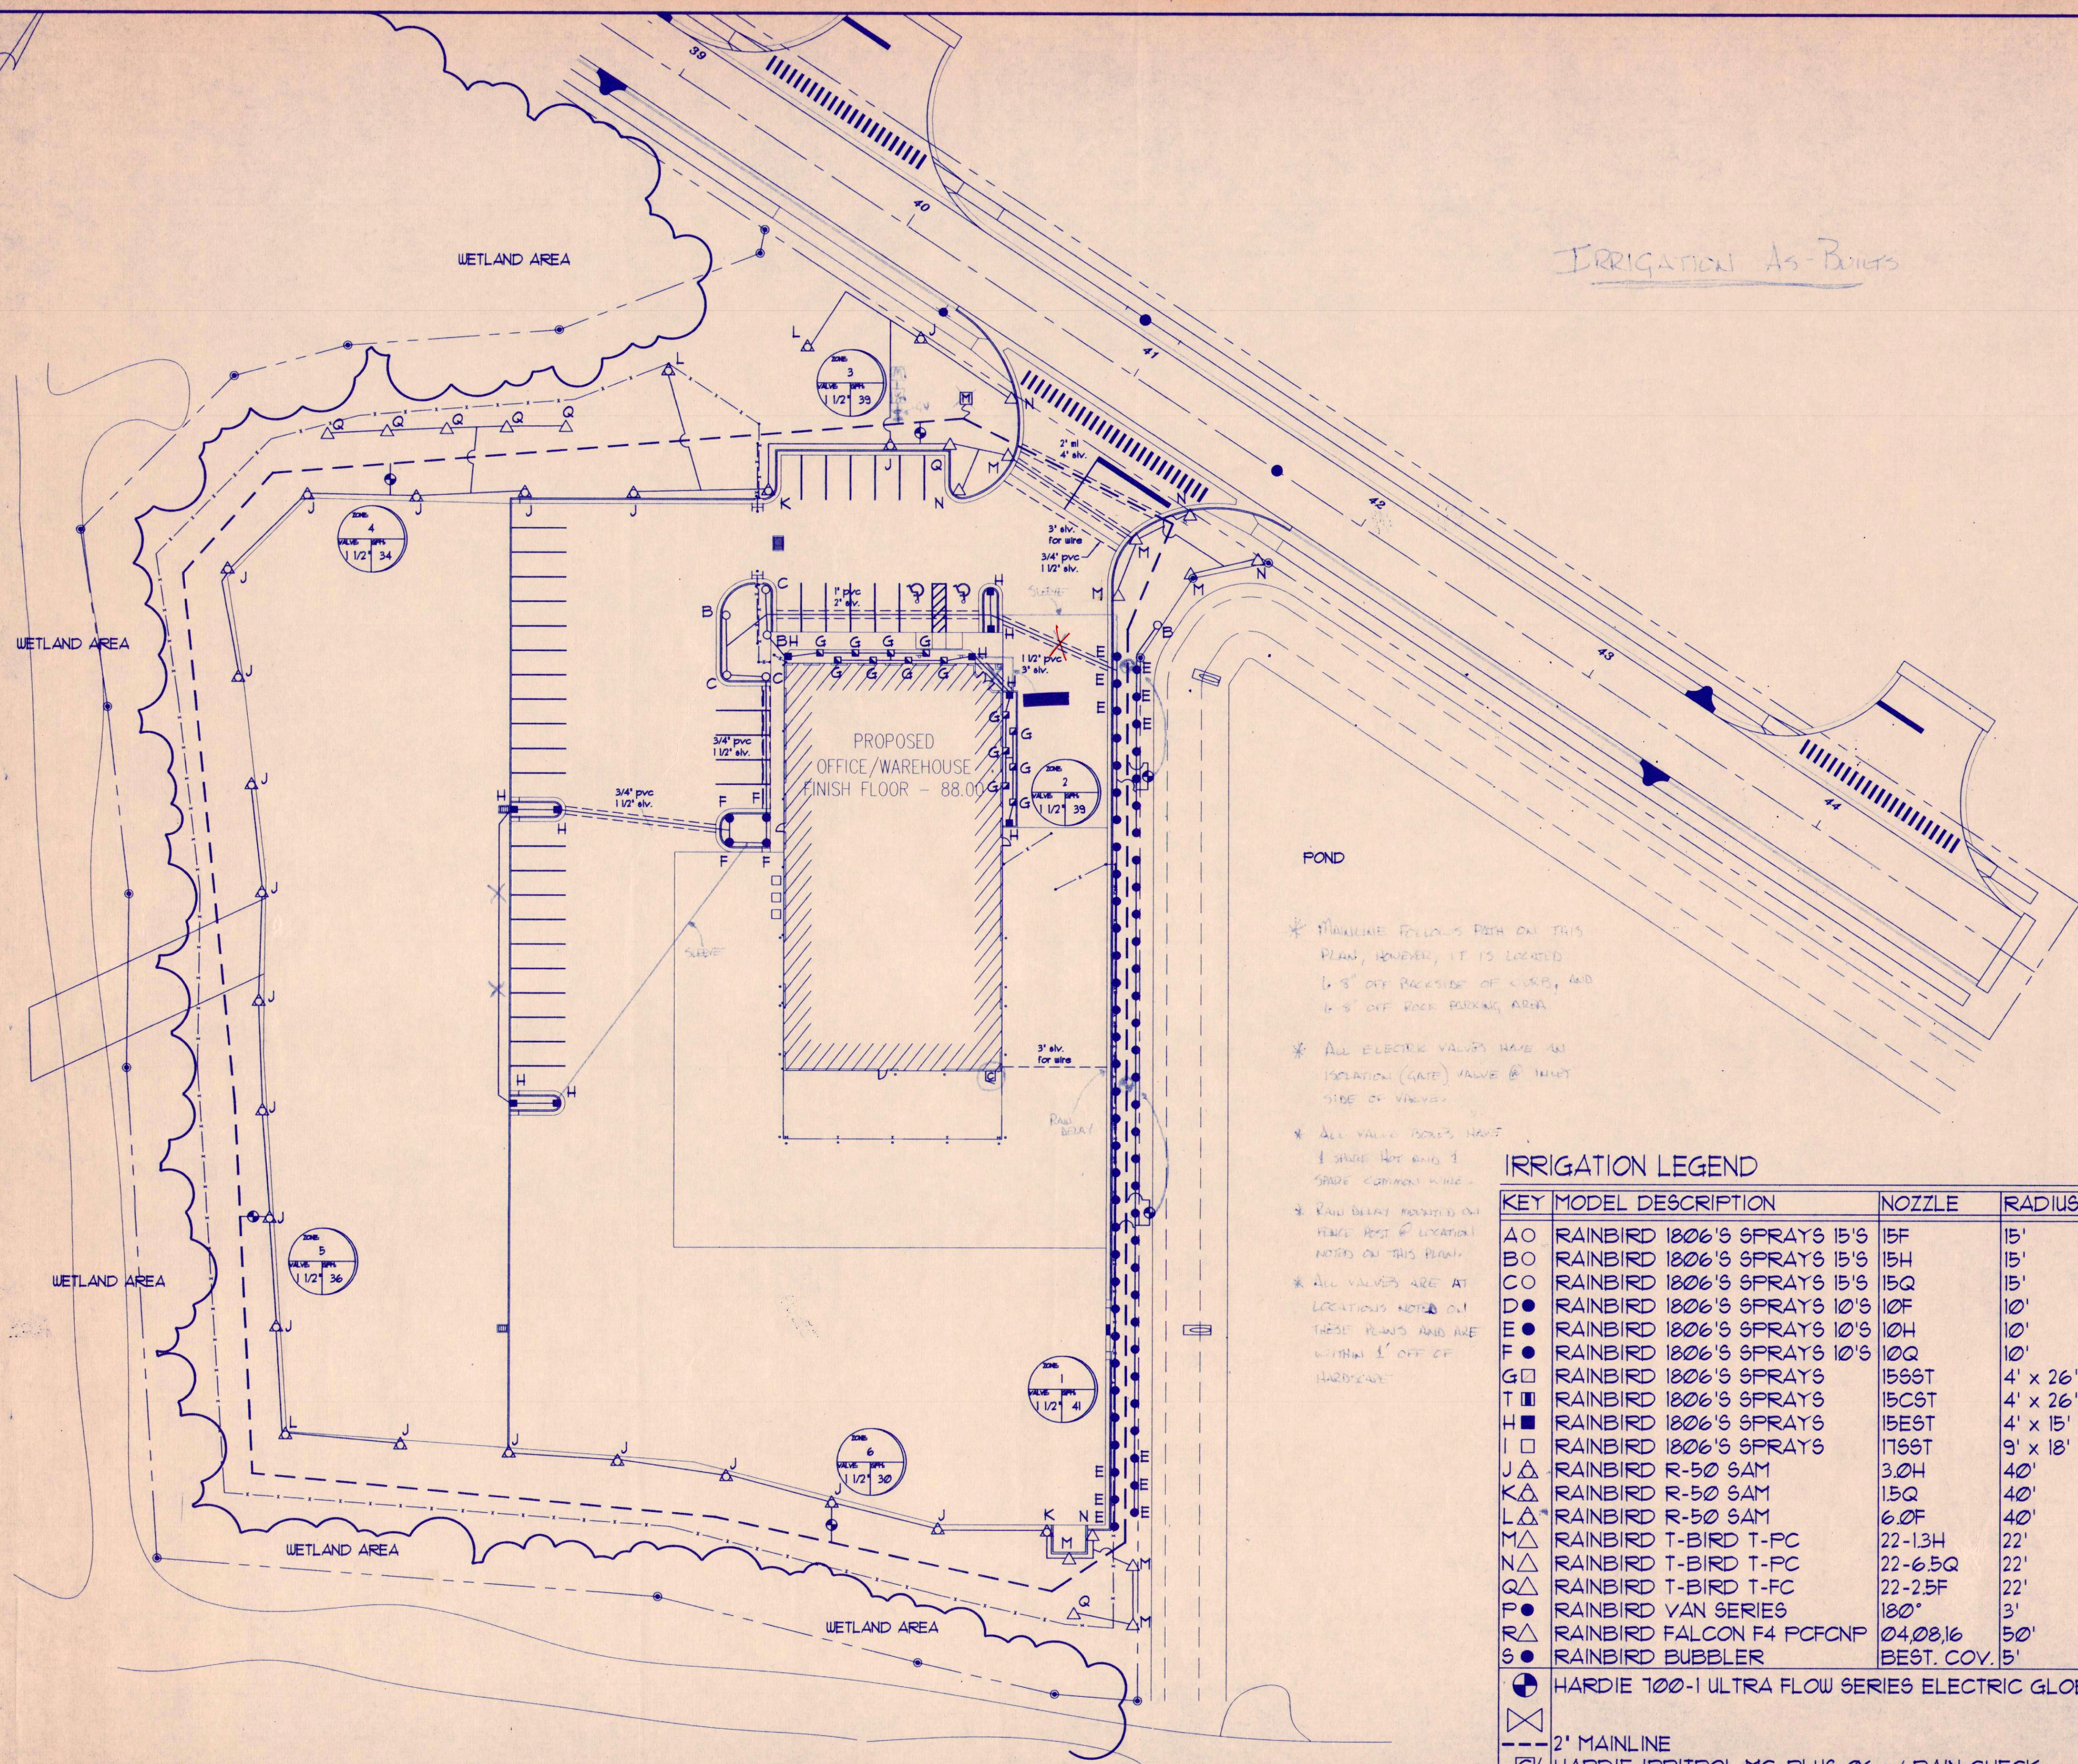


- * MAINLINE FOLLOWS PATH ON THIS PLAN, HOWEVER, IT IS LOCATED 6'-8" OFF BACKSIDE OF CURB, AND 16'-8" OFF ROAD PARKING AREA.
- * ALL ELECTRIC VALVES HAVE AN ISOLATION (GATE) VALVE @ 10' WET SIDE OF VALVE.
- * ALL VALVE BOXES HAVE 1 SHADE HOT AND 1 SHADE COOLANT WIRE.
- * RAIN DELAY PROVIDED ON FENCE POST @ LOCATION NOTED ON THIS PLAN.
- * ALL VALVES ARE AT LOCATIONS NOTED ON THESE PLANS AND ARE WITHIN 1' OFF OF HARDWARE.

IRRIGATION LEGEND

KEY	MODEL DESCRIPTION	NOZZLE	RADIUS	GPM	PSI	COMMENTS
AO	RAINBIRD 1806'S SPRAYS 15'S	15F	15'	3.7	30	12" POP-UPS IN BEDS OF GROUND COVER
BO	RAINBIRD 1806'S SPRAYS 15'S	15H	15'	1.85	30	
CO	RAINBIRD 1806'S SPRAYS 15'S	15Q	15'	.93	30	
DO	RAINBIRD 1806'S SPRAYS 10'S	10F	10'	1.57	30	
EO	RAINBIRD 1806'S SPRAYS 10'S	10H	10'	.79	30	
FO	RAINBIRD 1806'S SPRAYS 10'S	10Q	10'	.39	30	
GO	RAINBIRD 1806'S SPRAYS	15SST	4' x 26'	.89	15	
HO	RAINBIRD 1806'S SPRAYS	15CST	4' x 26'	.89	15	
IO	RAINBIRD 1806'S SPRAYS	15EST	4' x 15'	.61	30	
JO	RAINBIRD 1806'S SPRAYS	17SST	9' x 18'	1.6	25	
KA	RAINBIRD R-50 SAM	3.0H	40'	4.2	45	
LA	RAINBIRD R-50 SAM	1.5Q	40'	2.0	45	
MA	RAINBIRD R-50 SAM	6.0F	40'	7.0	35	
NA	RAINBIRD T-BIRD T-PC	22-13H	22'	1.3	35	
QA	RAINBIRD T-BIRD T-PC	22-6.5Q	22'	.65	35	
RA	RAINBIRD T-BIRD T-FC	22-2.5F	22'	2.5	35	
PA	RAINBIRD VAN SERIES	180"	3'	.37	20	
RA	RAINBIRD FALCON F4 PCFCNP	04.08.16	50'	3.5, 6.4, 13.1	40	
SA	RAINBIRD BUBBLER	BEST. COV.	5'	.5	30	

- HARDIE 100-1 ULTRA FLOW SERIES ELECTRIC GLOBE VALVE
- ⊗ 2" MAINLINE
- ⊠ HARDIE IRRITROL MC-PLUS 06 w/ RAIN CHECK
- ⊡ 1 1/2" IRRIGATION METER OR OPTIONAL WELL & PUMP TO DRAW FROM POND
- ⊢ 1 1/2" BACKFLOW PREVENTER
- * VELOCITY SHALL NOT EXCEED 5' PER SEC. IN ALL PIPELINES

ARCHITECT:

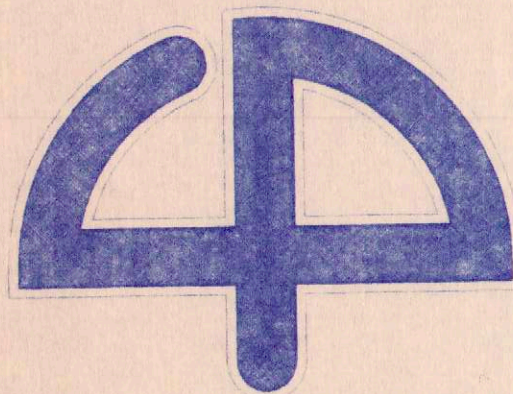

CUHACI & PETERSON
ARCHITECTS

1220 ALDEN ROAD
ORLANDO, FL 32803
PHONE (407) 228-4220
FAX (407) 228-4219

ELECTRICAL
ENGINEER:

ALEX PIPER, PE

1226 TURNER ROAD
WINTER PARK, FL 32789
PHONE (407) 628-8418
FAX (407) 628-9793

STRUCTURAL
ENGINEER:



HB ASSOCIATES, INC.
STRUCTURAL/CIVIL ENGINEERING


HB ASSOCIATES INC.

990 LEWIS DRIVE
WINTER PARK, FL 32789
PHONE (407) 740-5444
FAX (407) 740-7900

GENERAL NOTES :

1. WRITTEN DIMENSIONS PREVAIL. DO NOT SCALE THESE DRAWINGS. IF DIMENSIONS ARE IN QUESTION THE CONTRACTOR SHALL BE RESPONSIBLE FOR OBTAINING CLARIFICATION FROM THE ARCHITECT BEFORE PROCEEDING.
2. FOR EASE OF PARTITION LAYOUT, ALL STANDARD GYPSUM BOARD PARTITIONS ARE DIMENSIONED FROM STUD FACE TO STUD FACE. MASONRY AND CONCRETE SURFACES ARE DIMENSIONED TO FACE OF WALL.
3. WHERE BUILDING ELEMENTS ARE TOO LARGE TO FIT INSIDE THE CAVITY OF WALLS, WALLS ARE TO BE FURRED TO CONCEAL OR "BUILD IN" PIPING, ELECTRICAL PANELS AND OTHER RECESSED OBJECTS.
4. IF THE CONTRACTOR DISCOVERS ANY CONFLICT BETWEEN THE DRAWINGS AND THE CONDITIONS WHERE WORK IS TO BE PERFORMED, HE SHALL PROMPTLY NOTIFY THE ARCHITECT.
5. THE CONTRACTOR SHALL CONSULT WITH THE FIRE AUTHORITY HAVING JURISDICTION REGARDING FIRE EXTINGUISHER PROTECTION FOR THE BUILDING, OBTAIN CLARIFICATION, AND PROVIDE APPROPRIATE QUANTITIES AND LOCATIONS OF FIRE EXTINGUISHERS.
6. SIDEWALK SLABS SHALL BE A MINIMUM 4" THICK CONCRETE WITH NON-SLIP FINISH ON COMPACTED EXISTING POROUS SUB-BASE OR COMPACTED POROUS FILL AS REQUIRED AND/OR RECOMMENDED BY SOILS ENGINEER. CONTROL JOINTS SHALL BE SPACED AS INDICATED. SIDEWALK TO SLOPE AWAY FROM BUILDING AT 1/4" /FOOT.
7. ALL EXPOSED GYPSUM BOARD WALL AND CEILING SURFACES IDENTIFIED IN THE WORK ARE TO BE APPROPRIATELY PREPARED INCLUDING TAPING, SPACKLING, AND SANDING TO A SMOOTH FINISH. COMPLETED WORK SHALL BE PAINT READY FOR FINISH REQUIREMENT SEE FINISH SCHEDULE.
8. ALL PENETRATIONS THAT OCCUR WHERE FIRE RATINGS ARE REQUIRED SHALL BE APPROPRIATELY SEALED TO MAINTAIN THE INTEGRITY OF THE WALL TO THE COMPLETE REQUIREMENTS OF THE UNDERWRITER'S LABORATORY OR GYPSUM ASSOCIATION ASSEMBLY IDENTIFIED.
9. WHERE WALLS ARE INDICATED TO BE EXTENDED FROM FLOOR TO ROOF DECK, THE WALL SHALL BE COMPLETELY SEALED TO MAINTAIN THE INTEGRITY OF THE WALL. WHERE FIRE RATINGS ARE REQUIRED, THE WALL SHALL BE SEALED TO THE COMPLETE SPECIFICATIONS OF THE UL/OR GYPSUM ASSOCIATION ASSEMBLY IDENTIFIED.
10. THE GENERAL CONTRACTOR IS TO FILE AND SECURE ALL APPROVALS, PERMITS, TESTS, INSPECTIONS AND CERTIFICATES OF COMPLIANCE AS REQUIRED.
11. THE GENERAL CONTRACTOR IS TO PROVIDE ADEQUATE BARRICADES AS PER LOCAL BUILDING CODES AND ORDINANCES TO INSURE THE SAFETY OF PERSONS AND PROPERTY.
12. NO REPAIR OR PARKING OF EQUIPMENT WITHIN THE WAREHOUSE SPACE.

VICINITY MAP

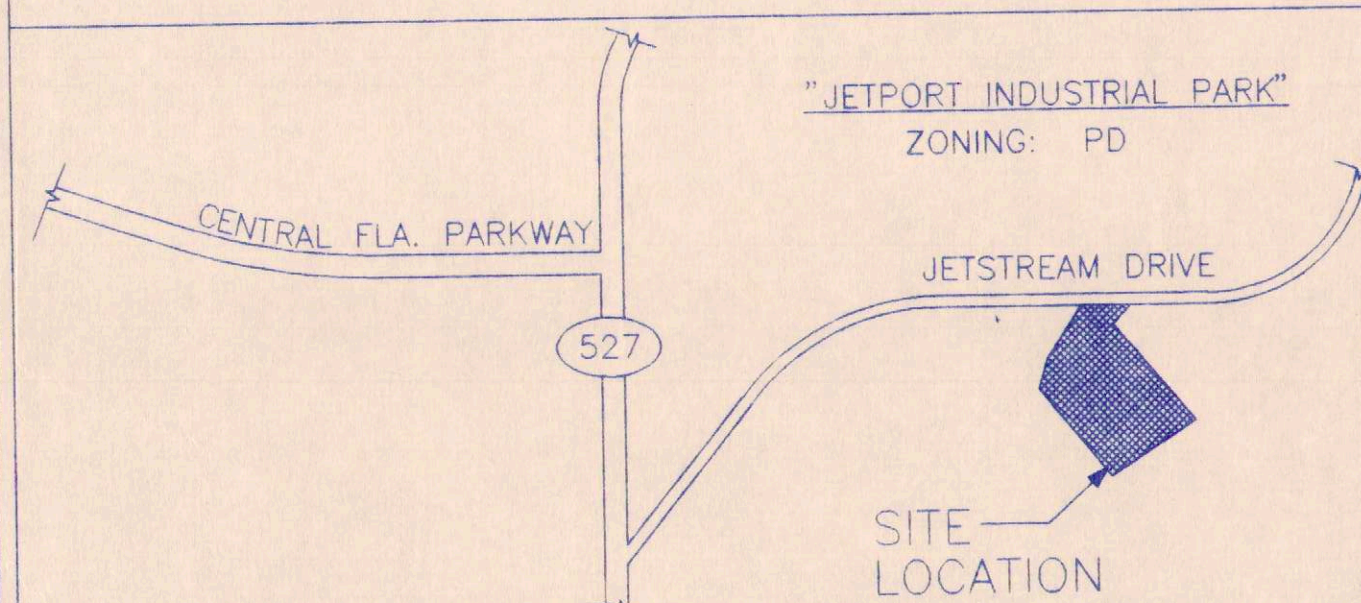

CLIENT:

PCG PROPERTIES INC.

5528 FORCE FOUR PARKWAY
ORLANDO, FLORIDA 32839
PHONE (407) 856-8180
FAX (407) 856-8182

MECHANICAL
ENGINEER:

JOHN ANTHONY ANDARY
& ASSOCIATES

P.O. BOX 3634
WINTER PARK, FL 32789
PHONE (407) 366-7256
FAX (407) 366-7146

CONSTRUCTION
MANAGER:

PERTREE
CONSTRUCTORS

845 SUNSHINE LANE
ALTAMONTE SPRINGS, FL 32714
PHONE (407) 869-0039
FAX (407) 869-1848

© COPYRIGHT

All reports, plans, specifications, computer files, field data, notes and other documents and instruments prepared by Cuhaci & Peterson Architects (C & P) as instruments of service remain the property of C & P. C & P shall retain all common law, statutory and other reserved rights, including the copyright thereto. Any use or reproduction of this document without written permission from C & P is a violation of Federal copyright laws.

FIRE PROTECTION
ENGINEER:

HAZARD FIRE
PROTECTION
ENGINEERING, INC.

222 CAPITOL COURT
OCDEE, FL 34761
PHONE (407) 877-5580
FAX (407) 650-8026

CODE INFORMATION

1. MEZZANINE:
CONSTRUCTION: TYPE 4 (3" CONCRETE SLAB/1 1/2" 22 GA. MTL. DECK/STEEL JOISTS)
PER 1005.7.3-THE MEZZANINE SPACE, BEING ENCLOSED SHALL HAVE A PROTECTED SMOKE DETECTION SYSTEM IN ACCORDANCE WITH NFPA 72 WHICH SOUNDS AN ALARM IN THE MEZZANINE.
PER 1005.7.3.3-TRAVEL DISTANCE SHALL NOT EXCEED 75 FT WHERE A SINGLE MEANS OF EGRESS IS PERMITTED.
 2. BUILDING:
PER SECTION 303.1-A BUILDING CONTAINING TWO OR MORE OCCUPANCIES, NONE GROUP H, MAY BE CONSIDERED A SINGLE OCCUPANCY WHEN:
(1) BUILDING MEETS MOST RESTRICTIVE TYPE OF CONSTRUCTION REQUIREMENTS;
(2) ENTIRE BUILDING CONFORMS TO MOST RESTRICTIVE FIRE PROTECTION REQUIREMENTS;
(3) ENTIRE BUILDING CONFORMS WITH THE MOST RESTRICTIVE OCCUPANCY GROUP SPRINKLER, STANDPIPE AND ALARM SYSTEM.
 3. CORRIDORS:
PER TABLE 704.2.4-INDUSTRIAL BUILDING, BEING SPRINKLERED DOES NOT NEED TO HAVE A RATED CORRIDOR.
 4. WALLS:
PER SECTION 609.2.3-TYPE IV CONSTRUCTION, PARTITIONS IN FULLY SPRINKLERED BUILDINGS, REGARDLESS OF HEIGHT, MAY BE OF ANY MATERIAL PERMITTED BY THIS CODE.
 5. A SEPARATE PERMIT MUST BE APPROVED BY THE ORANGE COUNTY FIRE AND RESCUE FOR THE FIRE ALARM SYSTEM, AUTOMATIC SPRINKLER SYSTEM AND/OR SUPPRESSION SYSTEM.
- STANDARD BUILDING CODE (SBC) 1997
MECHANICAL CODE 1997
PLUMBING CODE 1994
ELECTRICAL CODE 1996
LIFE SAFETY CODE NFPA-101 1994
FLORIDA ACCESSIBILITY CODE 5TH EDITION 1997
FLORIDA STATE MODEL ENERGY CODE 1997
- BUILDING SQUARE FOOTAGE = 12,000 SQUARE FEET

PROJECT ADDRESS:

1000 JETSTREAM DRIVE
JETPORT PARK ADDITION #1 LOT 7,
ORLANDO, FLORIDA

REGULATORY CONTACTS

BUILDING DEPARTMENT: ORANGE COUNTY (407) 836-5760
BUILDING CLASSIFICATION:

TYPE IV, UNPROTECTED SPRINKLERED
OCCUPANCY TYPE: INDUSTRIAL
TABLE 400: Maximum Height 55'
Maximum Area 27,000 S.F.

ALLOWABLE HEIGHTS AND FLOOR AREA:

PERIMETER OPEN ALL SIDES MIN. 60'-UNLIMITED AREA
OCCUPANT:

Per Section 1105 SBC and Life Safety Code
NFPA 101 Section 24-1.7
One person per each 30 s.f. sales area.
One person per each 100 s.f. storage area.

EXIT REQUIREMENTS: Section 5-3.2.1 NFPA 101

Means of egress shall be measured in units of exit width with width of .02 inches one (1) unit of exit is required for each 100 occupants. Section 5-2.1.3.1 NFPA 101 no door openings in the means of egress shall be less than 32 inches in clear width.

TRAVEL DISTANCE: Section 24-2.6 NFPA 101 250'-0"
maximum distance in a building protected throughout by an approved automatic sprinkler system.

HANDICAP REQUIREMENTS: Provided per Florida Accessibility Code.


INTERIOR FINISHES: Section 704.3 SBC Class "A" Minimum.

ROOF COVERING: Class "A", Class "B"

RELEASED FOR
CONSTRUCTION PERMIT

NEW FACILITY FOR:

PRIME CONSTRUCTION
GROUP INC.

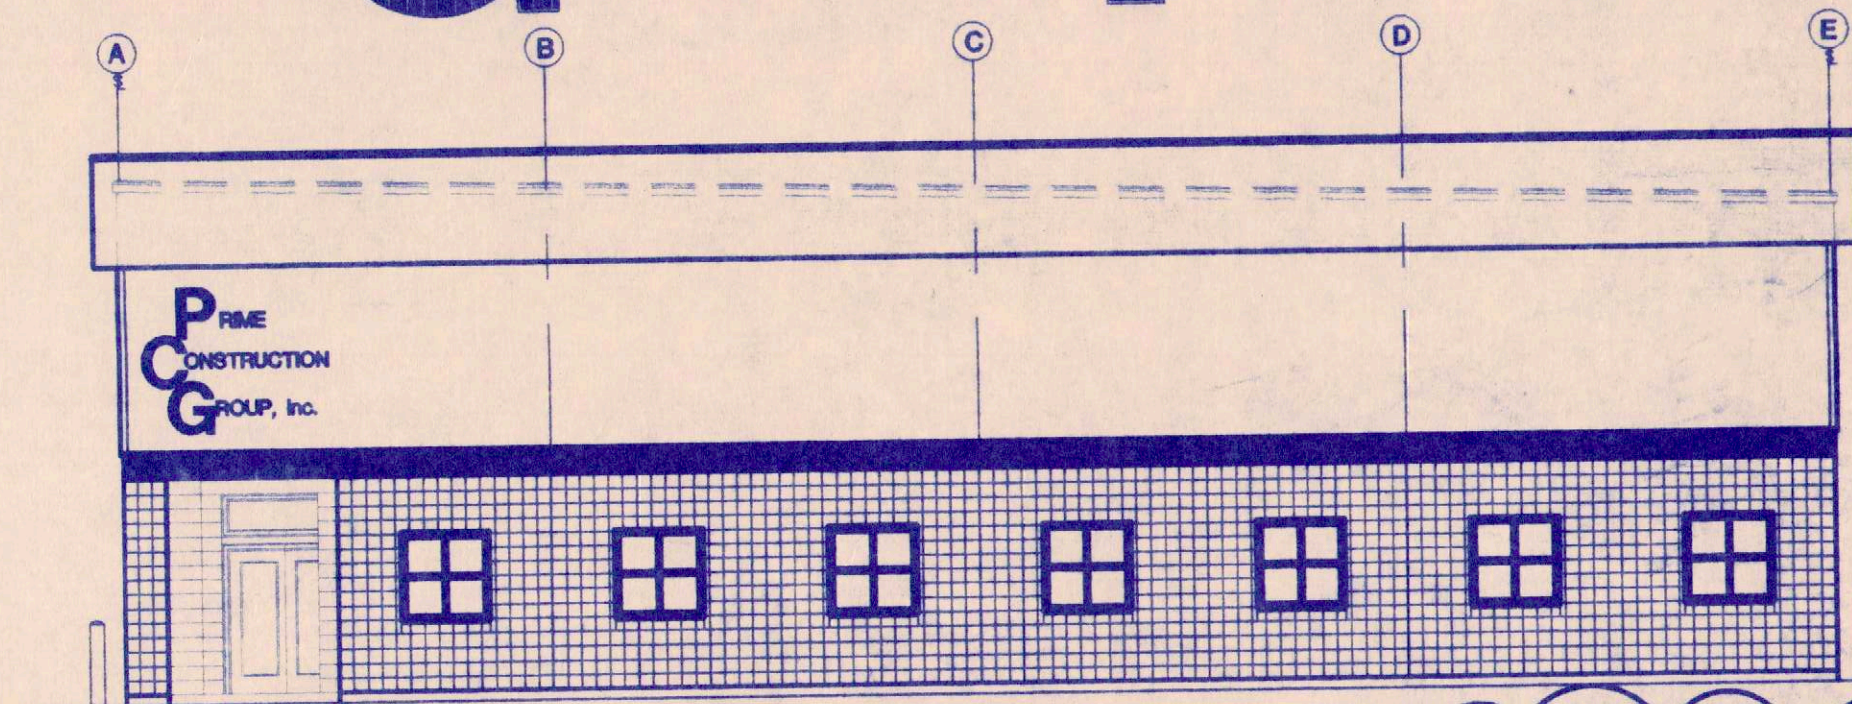

SITE PERMIT: 1300800534
BLDG. PERMIT: 130091235/PCG PROPERTIES

LEGAL DESCRIPTION - 1000 JETSTREAM DRIVE, JETPORT PARK, ADDITION #1, LOT 7.

A PARCEL OF LAND LYING IN THE NORTHWEST 1/4 OF SECTION 13, TOWNSHIP 24 SOUTH, RANGE 29 EAST, ORANGE COUNTY, FLORIDA, BEING MORE PARTICULARLY DESCRIBED AS FOLLOWS:

COMMENCE AT THE NORTHWEST CORNER OF SECTION 13, TOWNSHIP 24 SOUTH, RANGE 29 EAST; THENCE RUN N 89°59'27" E, ALONG THE NORTH LINE OF SAID SECTION 13, A DISTANCE OF 2247.54 FEET; THENCE DEPARTING SAID NORTH LINE RUN S 00°00'33" E, A DISTANCE OF 1345.75 FEET TO THE SOUTHERLY RIGHT OF WAY LINE OF A 120 FEET WIDE ORLANDO UTILITIES COMMISSION RAILROAD RIGHT OF WAY; THENCE RUN ALONG SAID SOUTHERLY RIGHT OF WAY THE FOLLOWING COURSES AND DISTANCES: N 89°56'23" E, A DISTANCE OF 1059.64 FEET; THENCE RUN S 00°03'37" E, A DISTANCE OF 28.60 FEET; THENCE RUN N 89°59'50" E, A DISTANCE OF 752.00 FEET; THENCE DEPARTING SAID RIGHT OF WAY LINE RUN S 00°04'11" E, A DISTANCE OF 1019.47 FEET; THENCE RUN S 89°55'49" W, A DISTANCE OF 384.60 FEET TO THE POINT OF BEGINNING; THENCE CONTINUE S 89°55'49" W, A DISTANCE OF 105.11 FEET; THENCE RUN S 22°08'56" E, A DISTANCE OF 8.78 FEET; THENCE RUN S 35°22'51" W, A DISTANCE OF 78.85 FEET; THENCE RUN S 52°10'13" W, A DISTANCE OF 77.69 FEET; THENCE RUN S 41°16'30" E, A DISTANCE OF 43.12 FEET; THENCE RUN S 40°09'20" E, A DISTANCE OF 69.29 FEET; THENCE RUN S 32°54'21" E, A DISTANCE OF 64.08 FEET; THENCE RUN N 60°43'31" E, A DISTANCE OF 183.81 FEET; THENCE RUN N 70°42'33" E, A DISTANCE OF 98.39 FEET; THENCE RUN N 69°22'29" E, A DISTANCE OF 51.46 FEET; THENCE RUN N 60°56'58" E, A DISTANCE OF 30.54 FEET; THENCE RUN N 33°31'23" W, A DISTANCE OF 383.73 FEET; THENCE RUN N 00°04'11" W, A DISTANCE OF 35.00 FEET; THENCE RUN N 44°56'46" E, A DISTANCE OF 28.28 FEET TO THE POINT OF BEGINNING.

ZONE: PD ZONE
SUBDIVISION PLAT BOOK 44, PAGE 29
RECORDED MARCH 31ST, 2000.

CONTAINING: 174,325.50 SQUARE FEET/4.00 ACRES.

AS BUILT

CONSTRUCTION DOCUMENT INDEX

SHEET NO.	DESCRIPTION	DATE	REVISION	REVISION	REVISION
COVER	COVER SHEET	4/10/00	6/2/00		
SP-1	SITE PLAN/LIGHTING PLAN	4/10/00	6/2/00		
A1	FLOOR PLAN & WALL TYPES	4/10/00	6/2/00		
A2	FLOOR FINISH PLAN, SCHEDULE & DETAIL	4/10/00			
A3	REFLECTED CEILING PLAN	4/10/00			
A4	ROOF PLAN	4/10/00			
A5	EXTERIOR ELEVATIONS & DETAILS	4/10/00	4/27/00	6/2/00	
A6	BUILDING SECTIONS & SECTION DETAILS	4/10/00	6/2/00		
A7	WALL SECTIONS & DETAILS	4/10/00	6/2/00		
A8	INTERIOR ELEVATIONS & DETAILS	4/10/00	6/2/00		
A9	DOORS/WINDOWS, FINISH SCHEDULE	4/10/00	6/2/00		
A10	RESTROOM PLANS & INTERIOR ELEVATIONS	4/10/00	6/2/00		
S1	FOUNDATION/FRAMING PLAN	4/10/00	6/2/00		
S2	DETAILS	4/10/00	6/2/00		
E1	ELECTRICAL LIGHTING PLAN	4/10/00	6/2/00		
E2	POWER PLAN	4/10/00	6/2/00		
M1	MECHANICAL PLAN	4/10/00	6/2/00		
M2	HVAC DETAILS	4/10/00	6/2/00		
P1	PLUMBING PLAN	4/10/00	6/2/00		
P2	PLUMBING DETAILS & RISER	4/10/00	6/2/00		
FP1	FIRE PROTECTION PLAN	4/10/00	6/2/00		
A11	FURNITURE/FIXTURE PLAN				

99228



Cuhaci & Peterson
Architects

1220 Alden Road
Orlando, Florida 32803
Ph. 407 228 4220
Fax. 407 228 4219

© COPYRIGHT
All reports, plans, specifications, computer files,
field notes, notes and other documents and
instruments prepared by Cuhaci & Peterson
Architects (C & P) as instruments of service
remain the property of C & P. C & P
shall retain all common law, statutory and other
reserved rights, including the copyright therein.
Any use or reproduction of this document with-
out written permission from C & P is a
violation of Federal copyright laws.

JOB TITLE
P.C.G. INC
1000 JETSTREAM DRIVE
ORLANDO, FLORIDA

DRAWING TITLE
SITE PLAN
LIGHTING PLAN

AS BUILT

REVISION :	
1	5/2/2000
2	
3	
4	

JOB NO.	99228
SCALE	AS SHOWN
DATE	4/10/2000
DRAWN	CRW
CHECKED	JAF
DRAWING NO.	

SP-1

1 SITE PLAN
SCALE: 1" = 30'-0"



ASPHALT PAVING

PROPOSED
OFFICE/WAREHOUSE
FINISH FLOOR - 88.00
1000 JETSTREAM DRIVE

CONCRETE PAVING

PVC SLEEVES
RE: CIVIL SHEET

PVC CHASE
RE: CIVIL SHEET


NEW ENTRY SIGN
WITH LANDSCAPE LIGHTS
SEE A-5 FOR DETAILS

JETSTREAM DRIVE


NOTE:
TYPE "T" - CONTACTOR MECH. HELD (4) POLE
TYPE "P" - PHOTO CELL CONTROLLED
SEE DRAWING E-1 FOR CATALOG AND SPECIFICATION
RUN 2#10, #10G FOR SITE LIGHTING CIRCUITS.
RUN #12'S UP POLES
1. NUMBER OF LIGHTS REQ'D AS SHOWN
2. COORDINATE W/ CIVIL ENGINEERING PLANS
PREPARED BY FACILITIES AND ENVIRONMENTAL
CONSULTANTS

ATTACHED WITHIN THIS SET OF PLANS ARE THE
SITE GEOMETRY AND SITE LANDSCAPE PLANS
PLEASE COORDINATE BETWEEN THE ARCH/CIVIL

DUMPSTER ENCLOSURE, CONFIRM
LOCATION WITH SITE PLANS, ENCLOSURE
TO BE CONSTRUCTED OUT OF SPLIT-FACE
MASONRY TO MATCH THE MATERIAL AND
COLOR OF THE BUILDING. SEE DETAIL
THIS SHEET

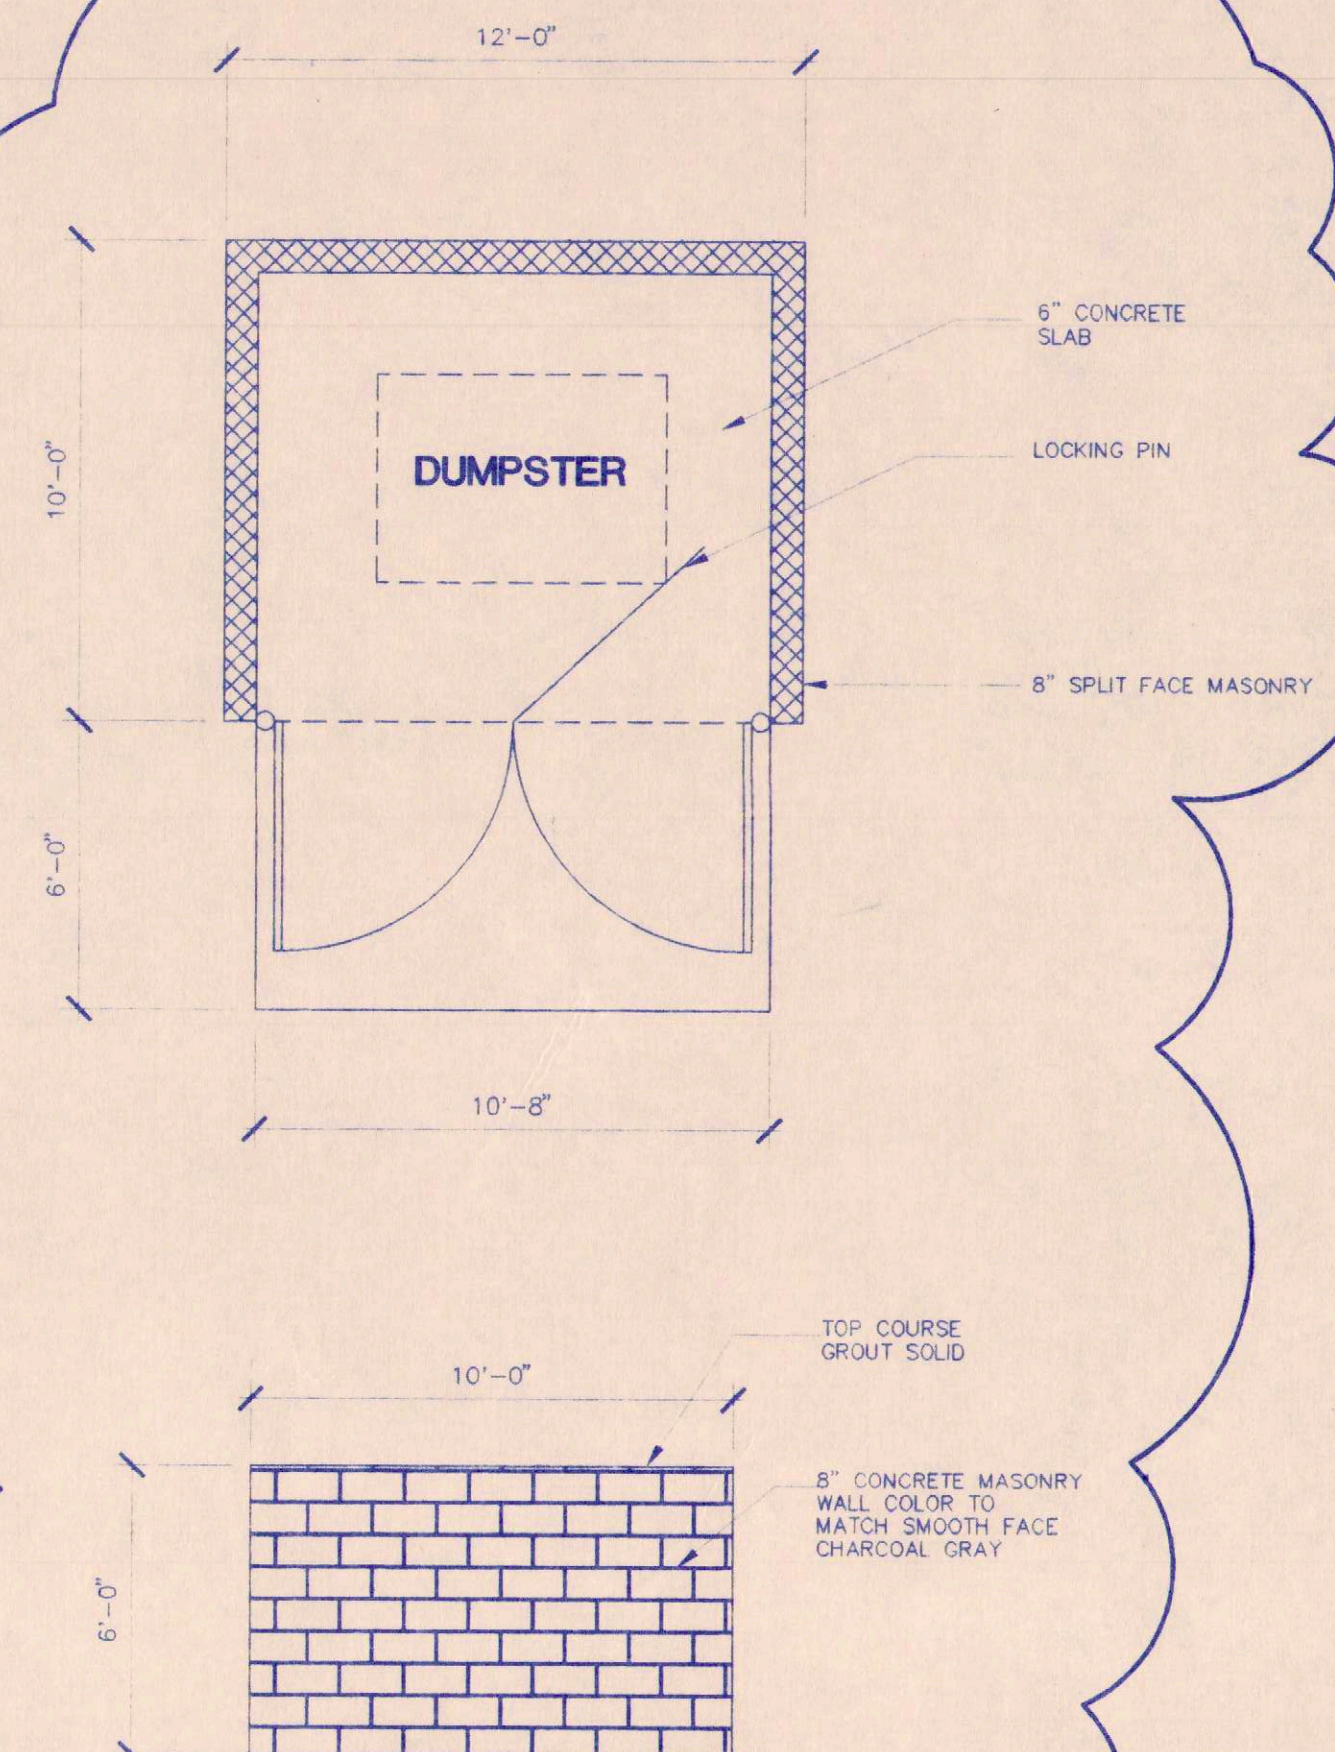

1 DUMPSTER ENCLOSURE
SCALE: 3/8" = 1'-0"

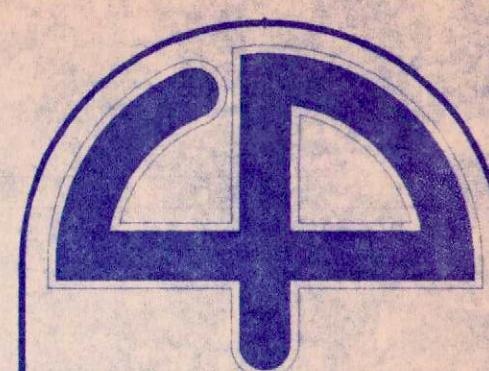

Cuhaci & Peterson
Architects


1220 Alden Road
Orlando, Florida 32803
Ph. 407 228 4220
Fax. 407 228 4219

© COPYRIGHT
All reports, plans, specifications, computer files,
field data, notes and other documents and
instruments prepared by Cuhaci & Peterson
Architects (C & P) as instruments of service
remain the property of C & P. C & P
shall retain all common law, statutory and other
reserved rights, including the copyright therein.
Any use or reproduction of this document with-
out written permission from C & P is a
violation of Federal copyright laws.

P.C.G. INC.
1000 JETSTREAM DRIVE
ORLANDO FLORIDA

FLOOR PLAN
& WALL TYPES


REVISION :	
1	6/2/2000
2	
3	
4	
5	
JOB NO.	99228
SCALE	AS SHOWN
DATE	4/20/2000
DRAWN	CRW
CHECKED	
DRAWING NO.	A1

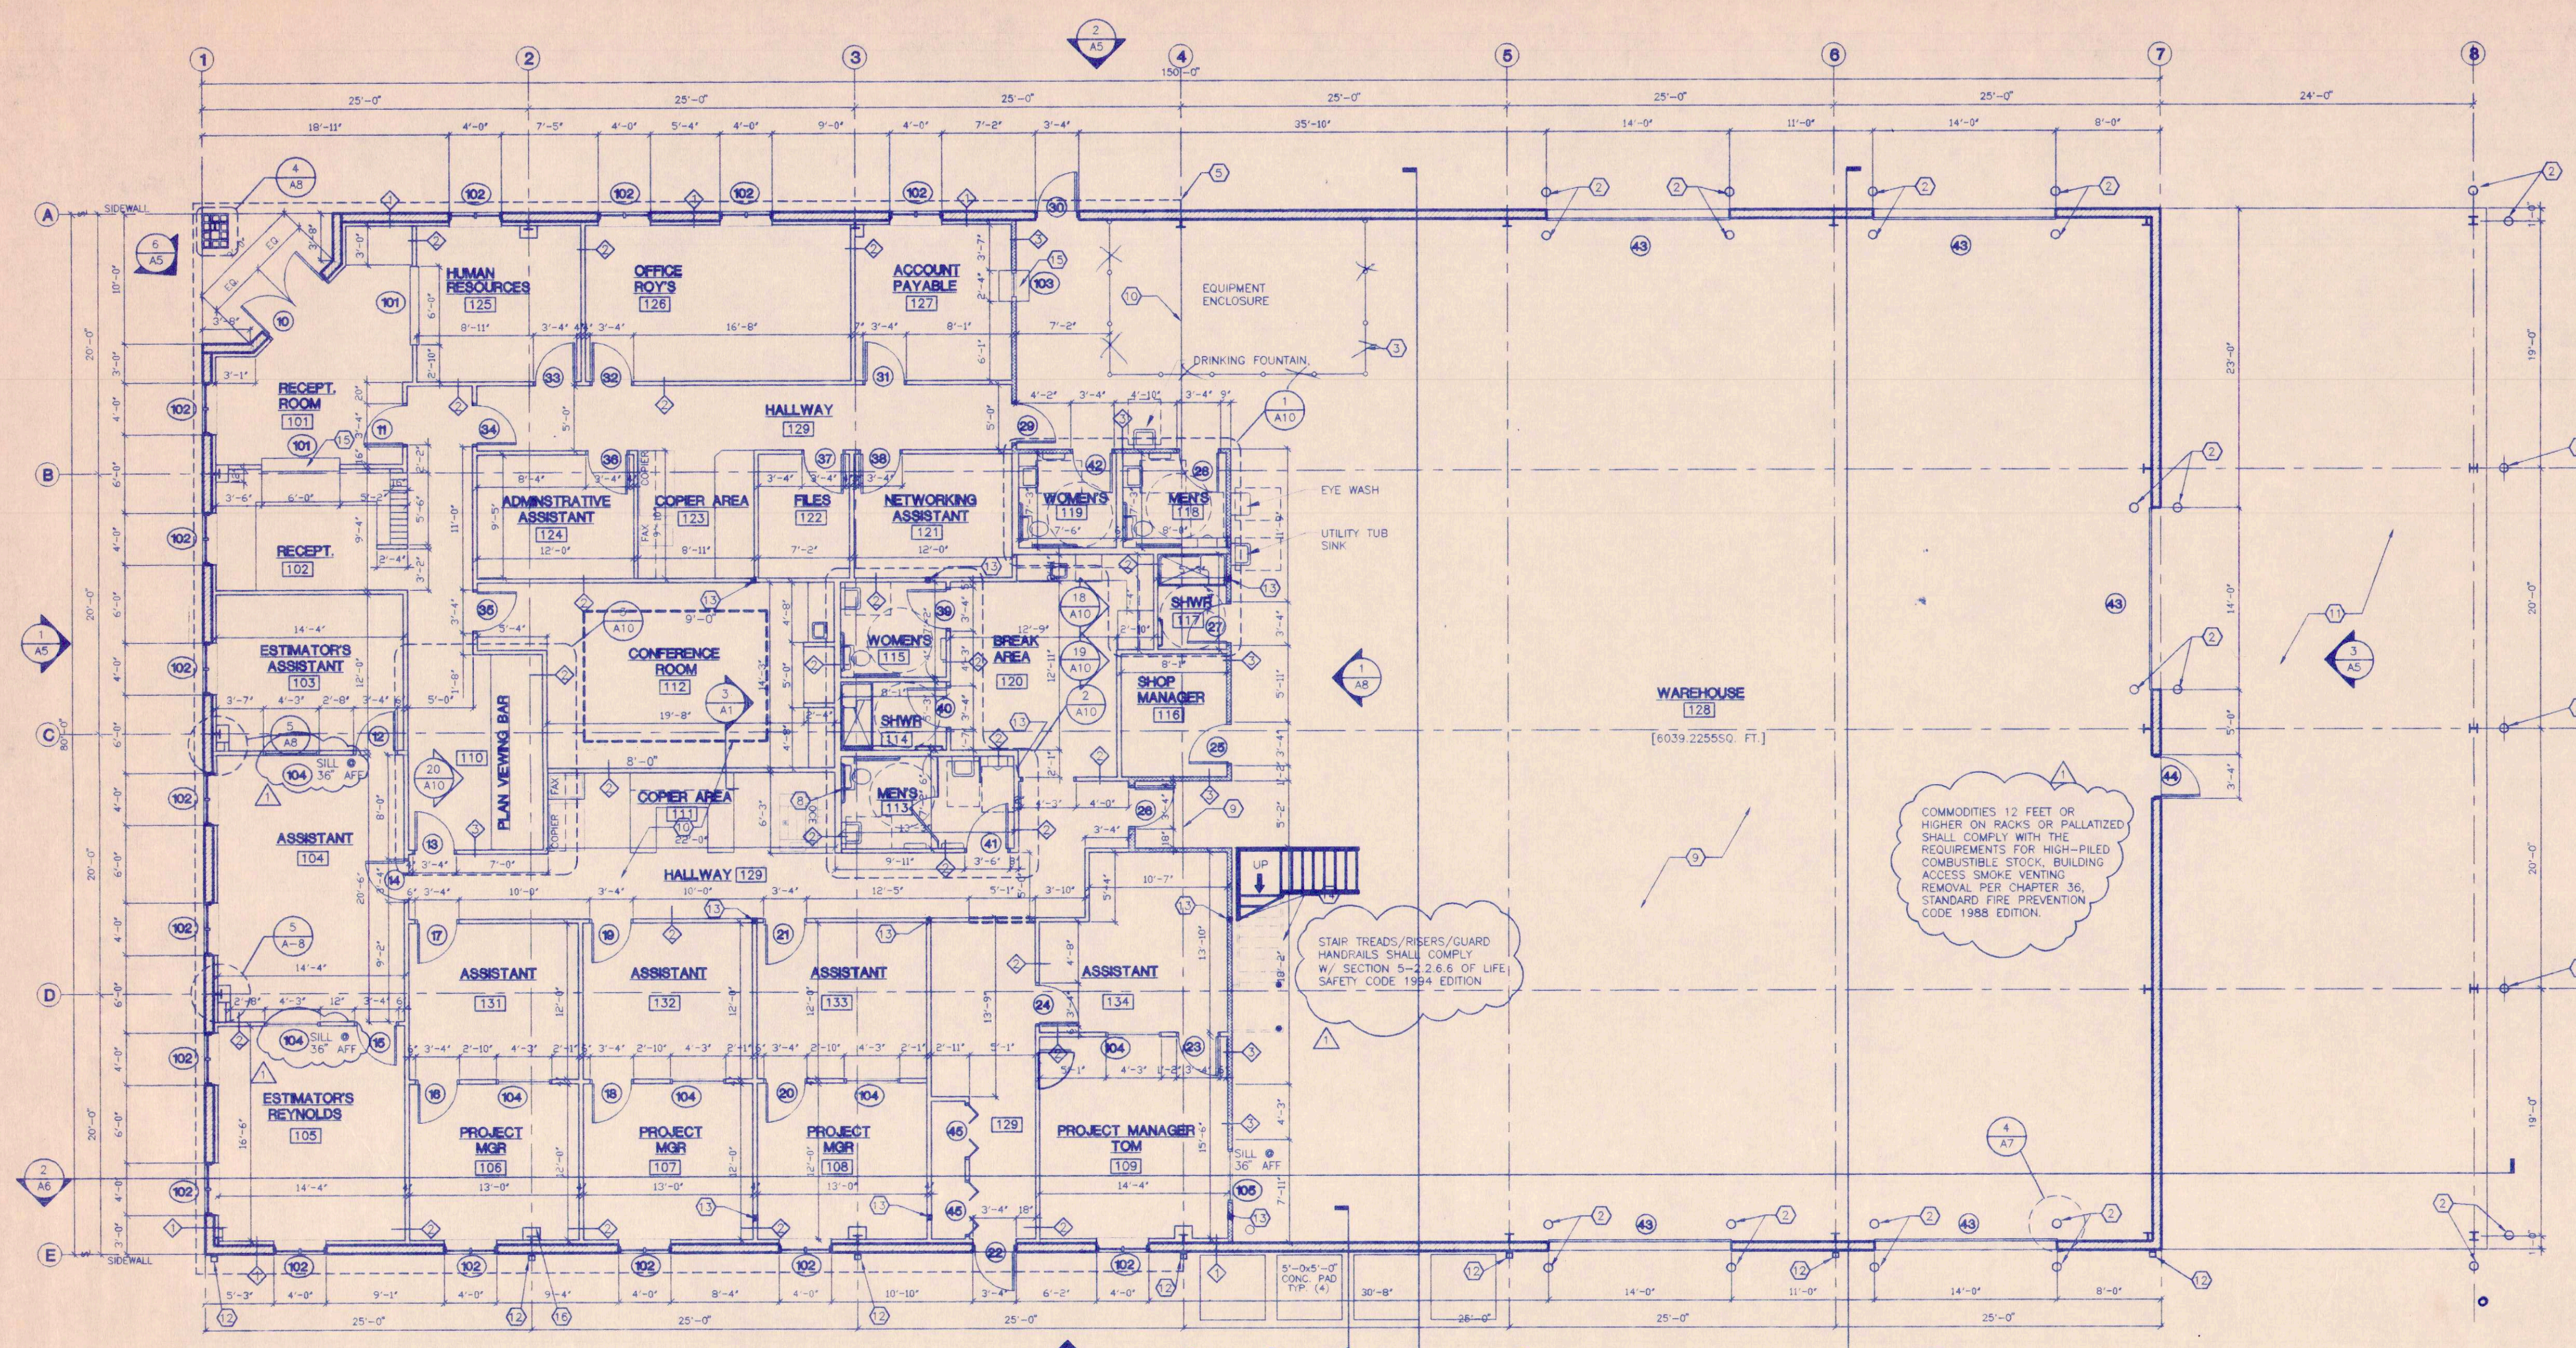

- LEGEND**
- DOOR NUMBER SEE SHEET A9.
 - WALL TYPE SEE DETAIL THIS SHEET
 - WINDOW NUMBER SEE SHEET A9.
 - ROOM NUMBERS
 - SOUND ATTENUATED BATT


- INSULATION CHART**
- R-19: BATT INSULATION ABOVE OFFICE CLG.
 - R-13: INSUL. IN PRE-ENGINEERED ROOF
 - R-13: BATT IN EXT. METAL WALLS

- GENERAL NOTES**
- BUILDING SHALL BE SUPPLIED BY BUTLER MFG COMPANY.
 - ALL DIMENSIONS ARE NOMINAL.
 - VERIFY COLUMN DIMENSION AND TAPER IN FIELD AFTER STEEL ERECTION IS COMPLETE PRIOR TO STUDDING THE WALLS.
 - ALL PLUMBING WALLS ARE TO BE 6" WALLS
- KEYED NOTES**
- PRE-FABRICATED CONCRETE PAN STAIR.
 - 8" STEEL BOLLARD FILLED W/ CONCRETE SEE SHEET A-7 FOR DETAIL.
 - CHAIN LINK FENCE
 - EXHAUST FAN. SEE MECHANICAL DRAWINGS FOR SPECIFICATIONS.
 - FASCIA ABOVE BY BUTLER MANUF. COMPANY.
 - PROVIDE SOLID BLOCKING IN WALL FOR MOUNTING OF HANDRAILS, TOILET ACCESSORIES & GRAB BARS IN RESTROOMS
 - PROVIDE SOLID BLOCKING AS REQUIRED FOR WALL HUNG CABINETS.
 - PROVIDE SOLID BLOCKING AS REQUIRED FOR ALL PLUMBING FIXTURES.
 - LIMIT OF 6" CONCRETE SLAB(SEE STRUCTURAL DWGS) w/ ASHFORD FORMULA SEALER
 - LIMIT OF 4" CONCRETE SLAB(SEE STRUCTURAL DWGS) w/ CURE-N-SEAL (OFFICE AREA ONLY)
 - 6" CONCRETE SLAB(SEE STRUCTURAL DWGS) w/ LIGHT BROOM FINISH (EXTERIOR SLAB ONLY)
 - DOWNSPOUT w/ GUARD (SEE DETAIL 5/A-5)
 - DISCHARGE TO UNDERGROUND PIPE (SEE CIVIL ENGINEERING DWGS.)
 - COLUMN IN WALL (SEE STRUCTURAL ENGINEERING DWGS.)
 - METAL HANDRAIL AT EACH SIDE OF STAIRS AND LANDING(TYP.)
 - 12" PLASTIC LAMINATE PASS-THRU COUNTER
 - GYPSUM BOARD COLUMN WRAP RE: DTL 5/A-8

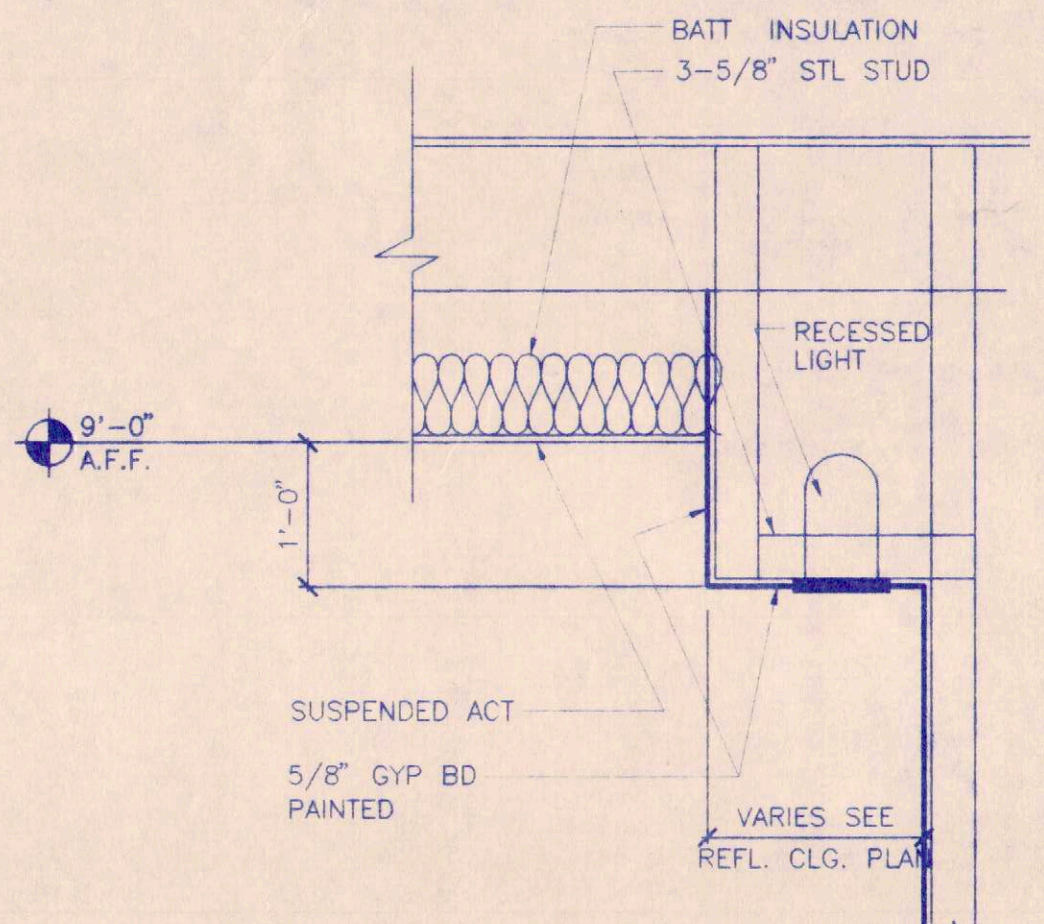


1 FLOOR PLAN
SCALE: 1/8"=1'-0"

3 SOFFIT DETAIL-CONF. ROOM
SCALE: 3/4"=1'-0"

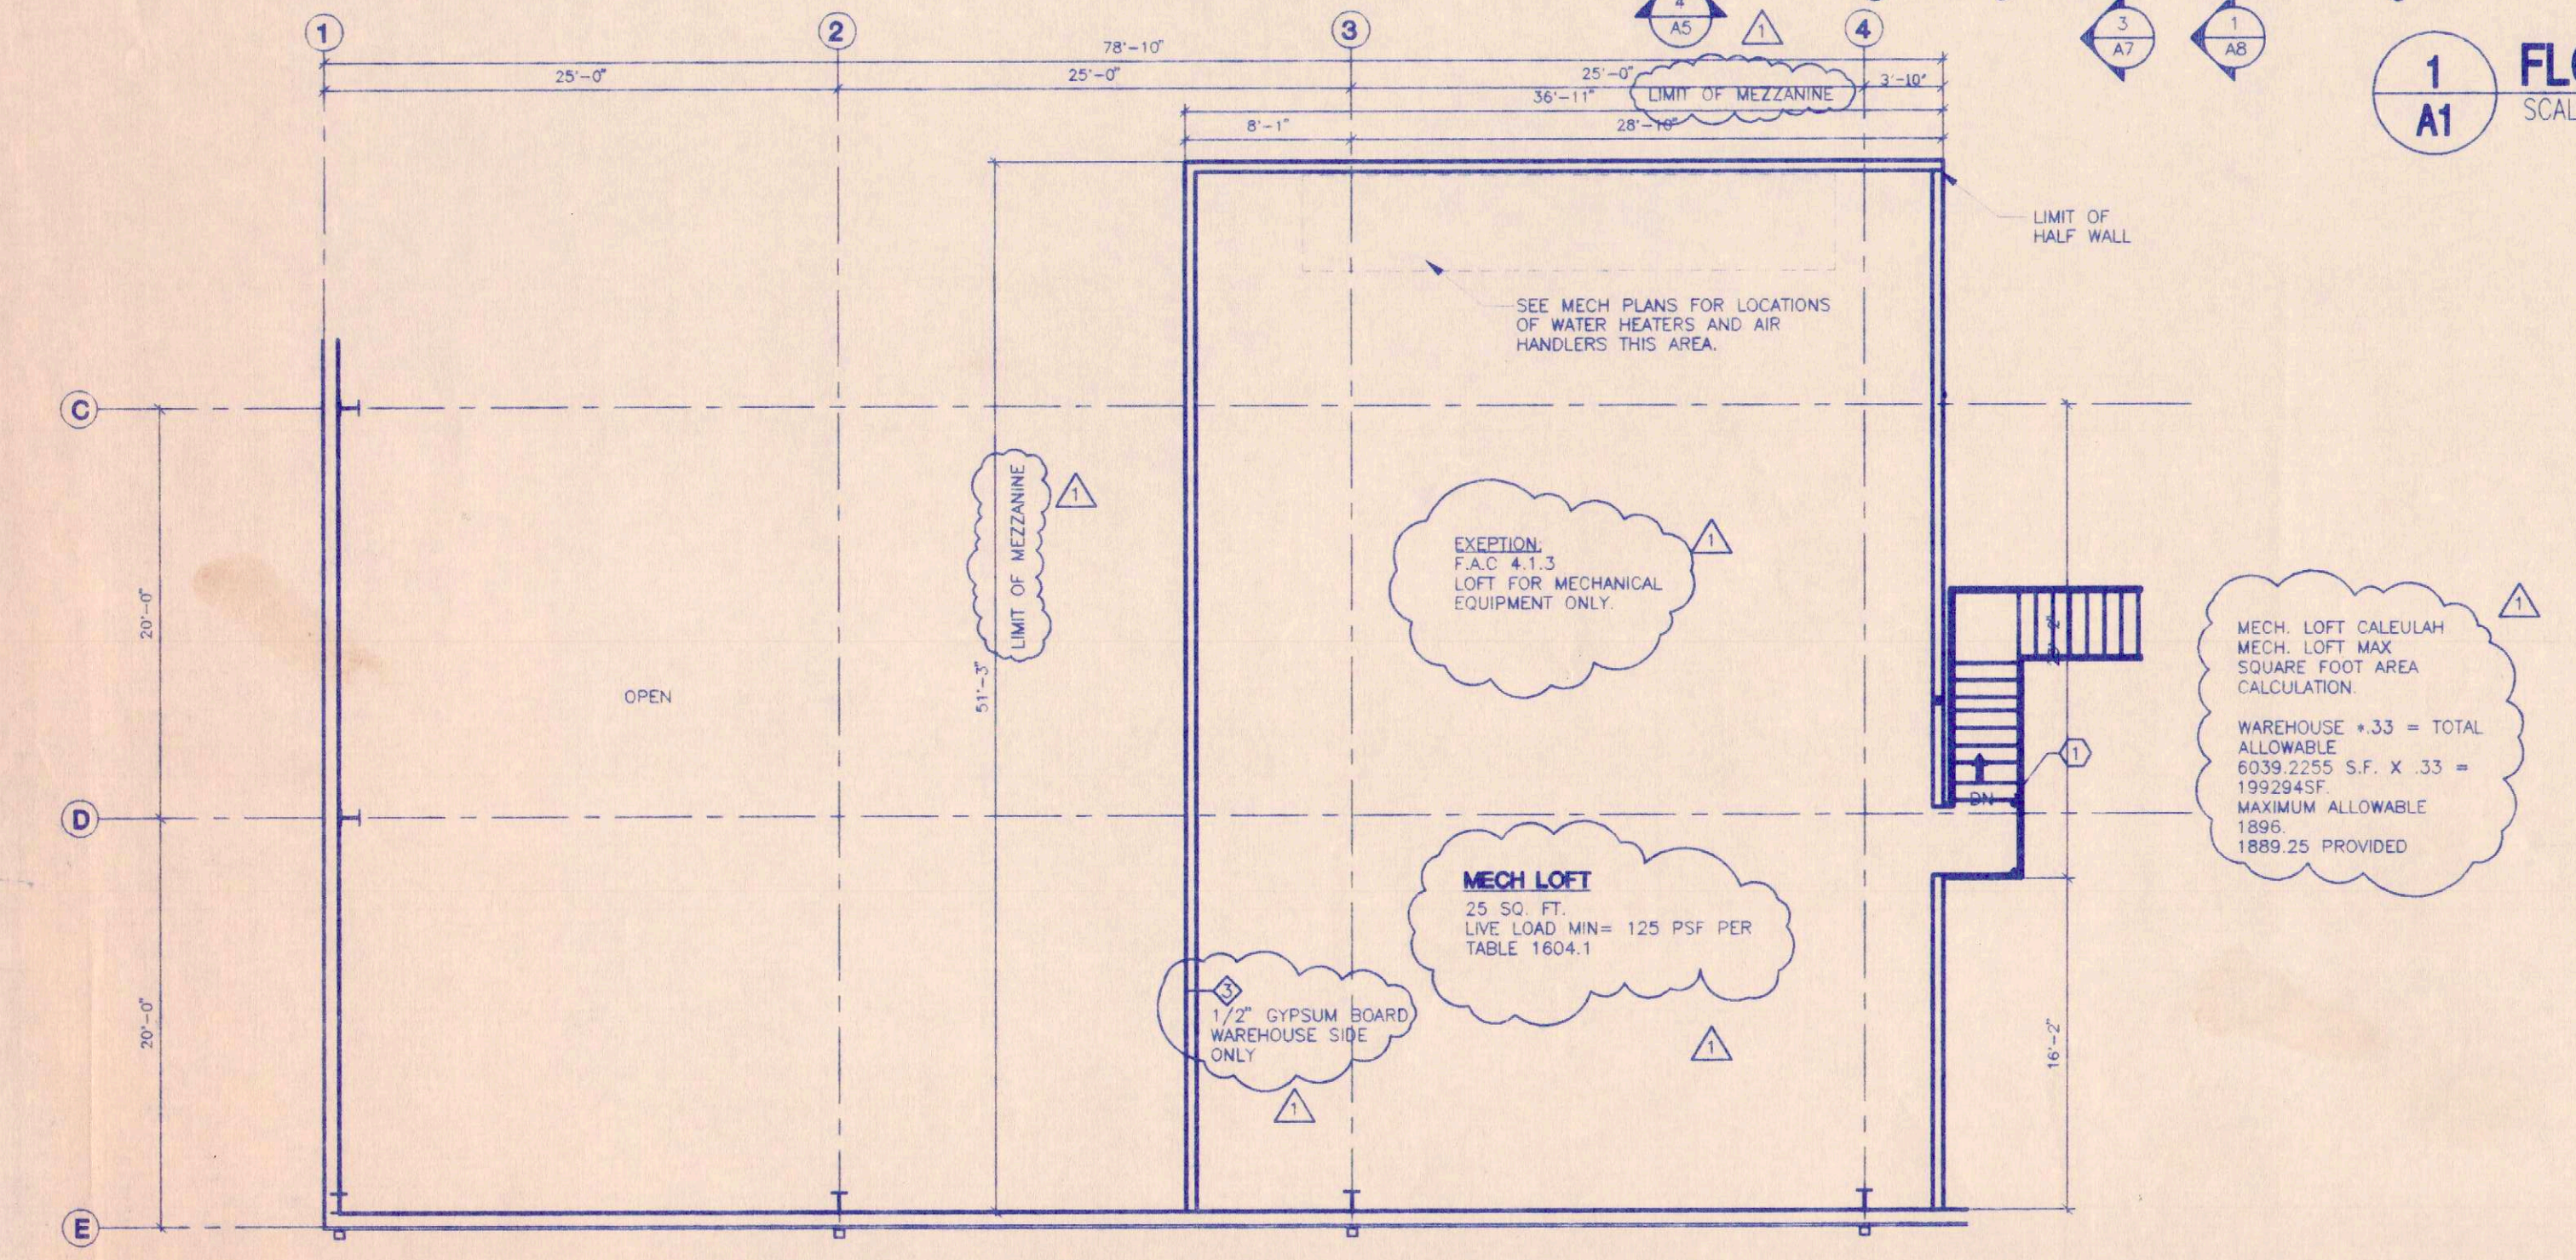


2 MECH. MEZZANINE PLAN
SCALE: 1/8"=1'-0"

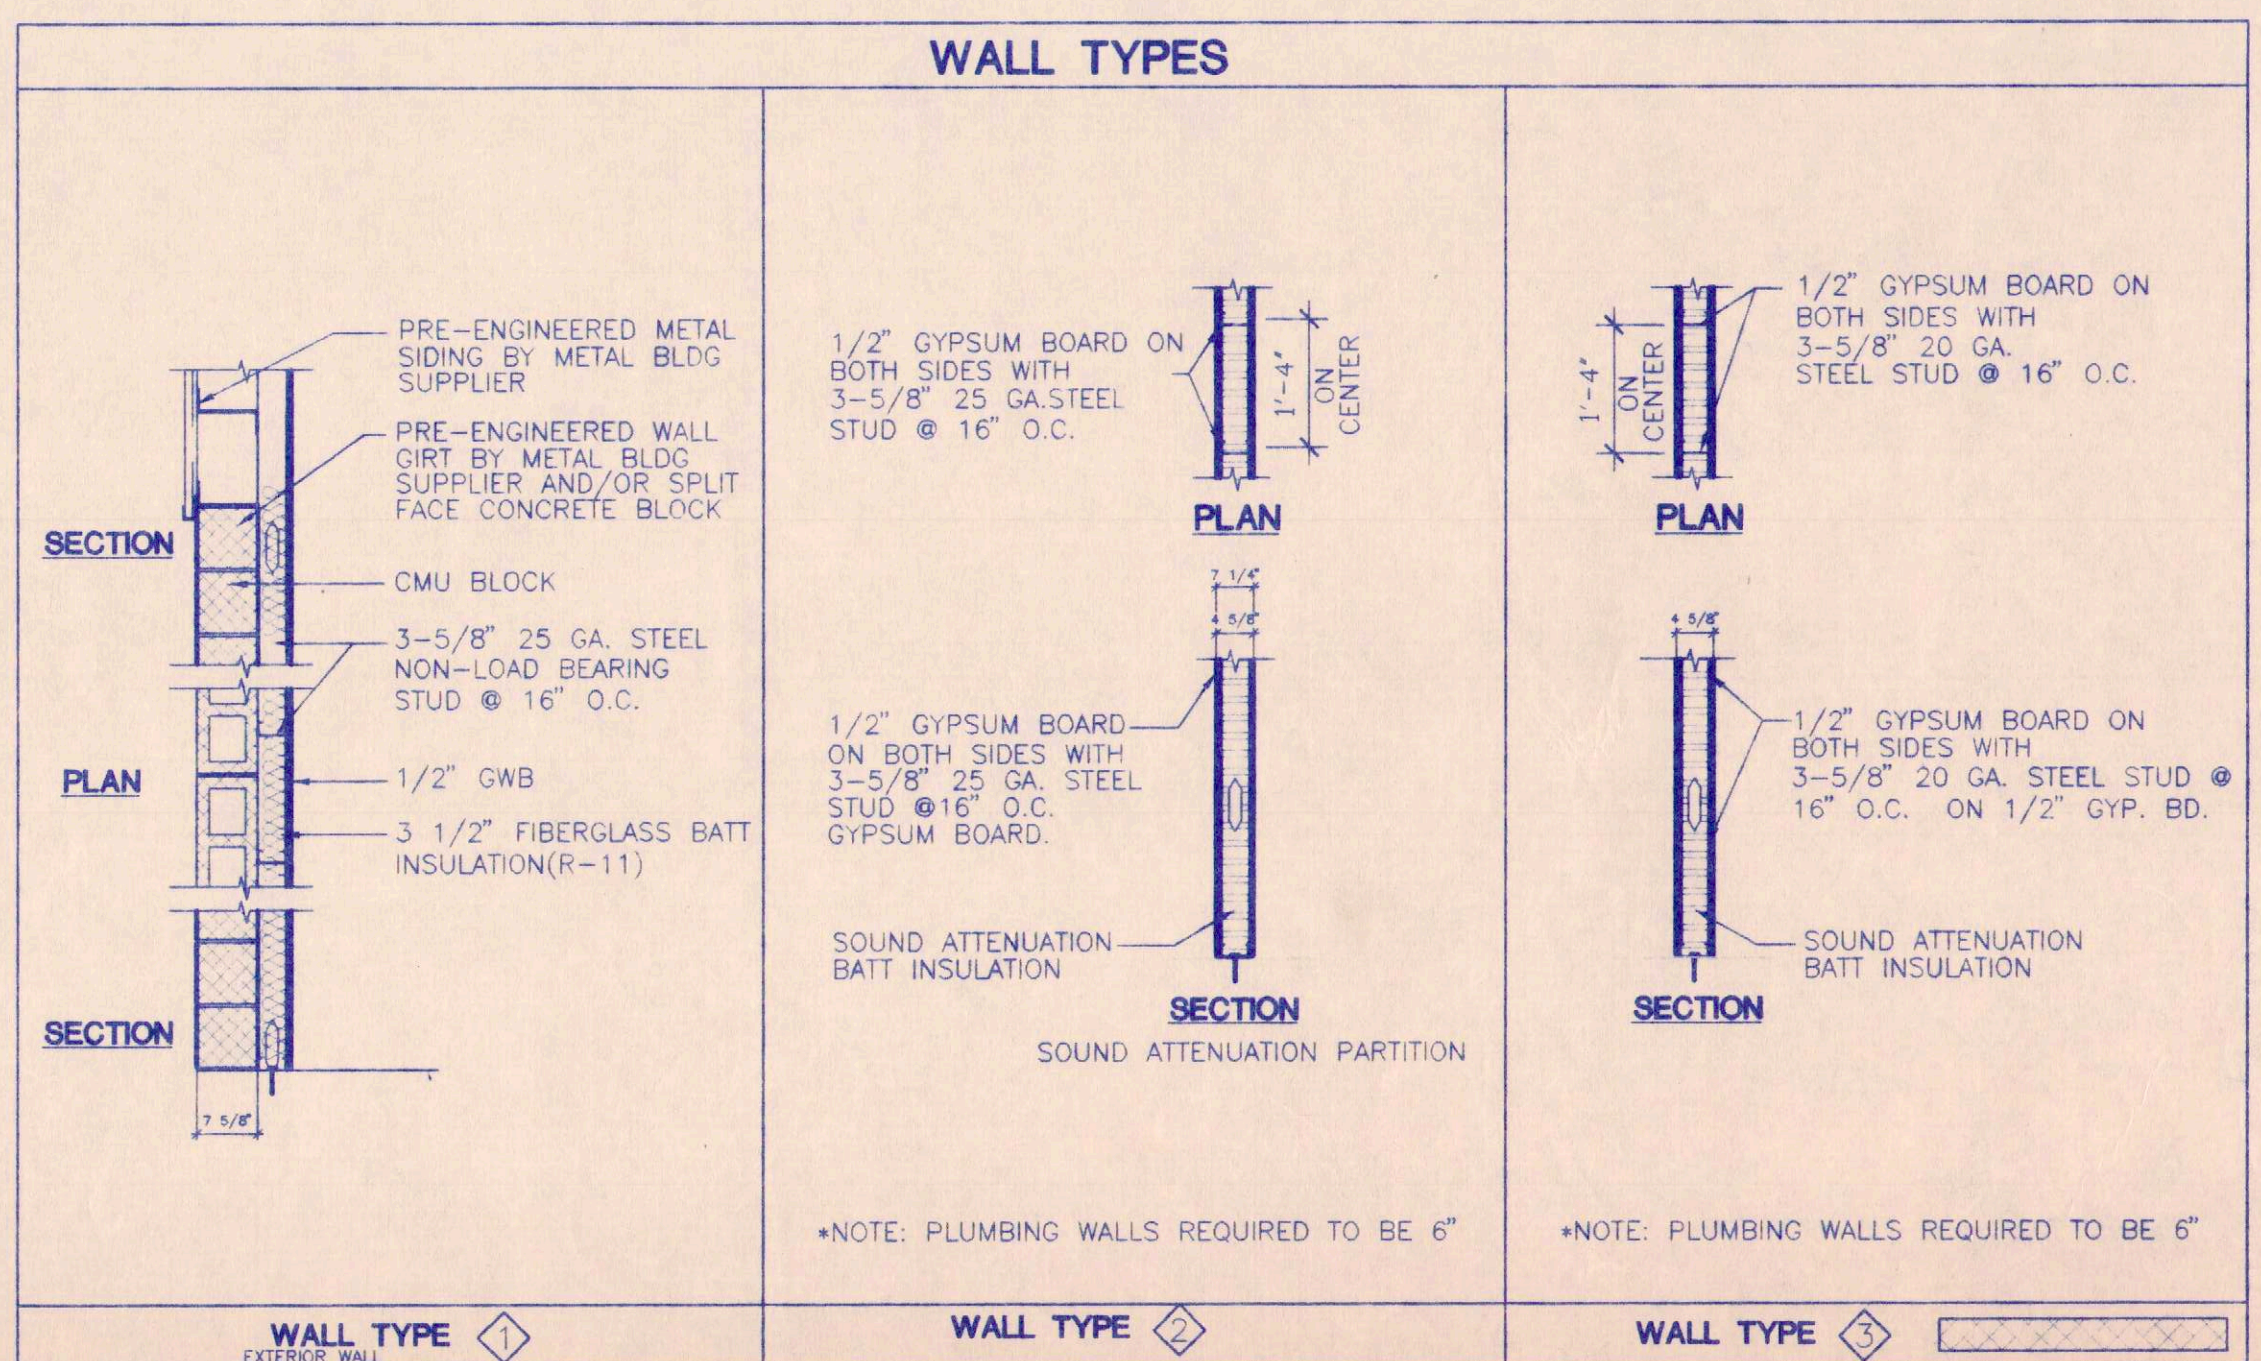

AS BUILT


RELEASED FOR
CONSTRUCTION

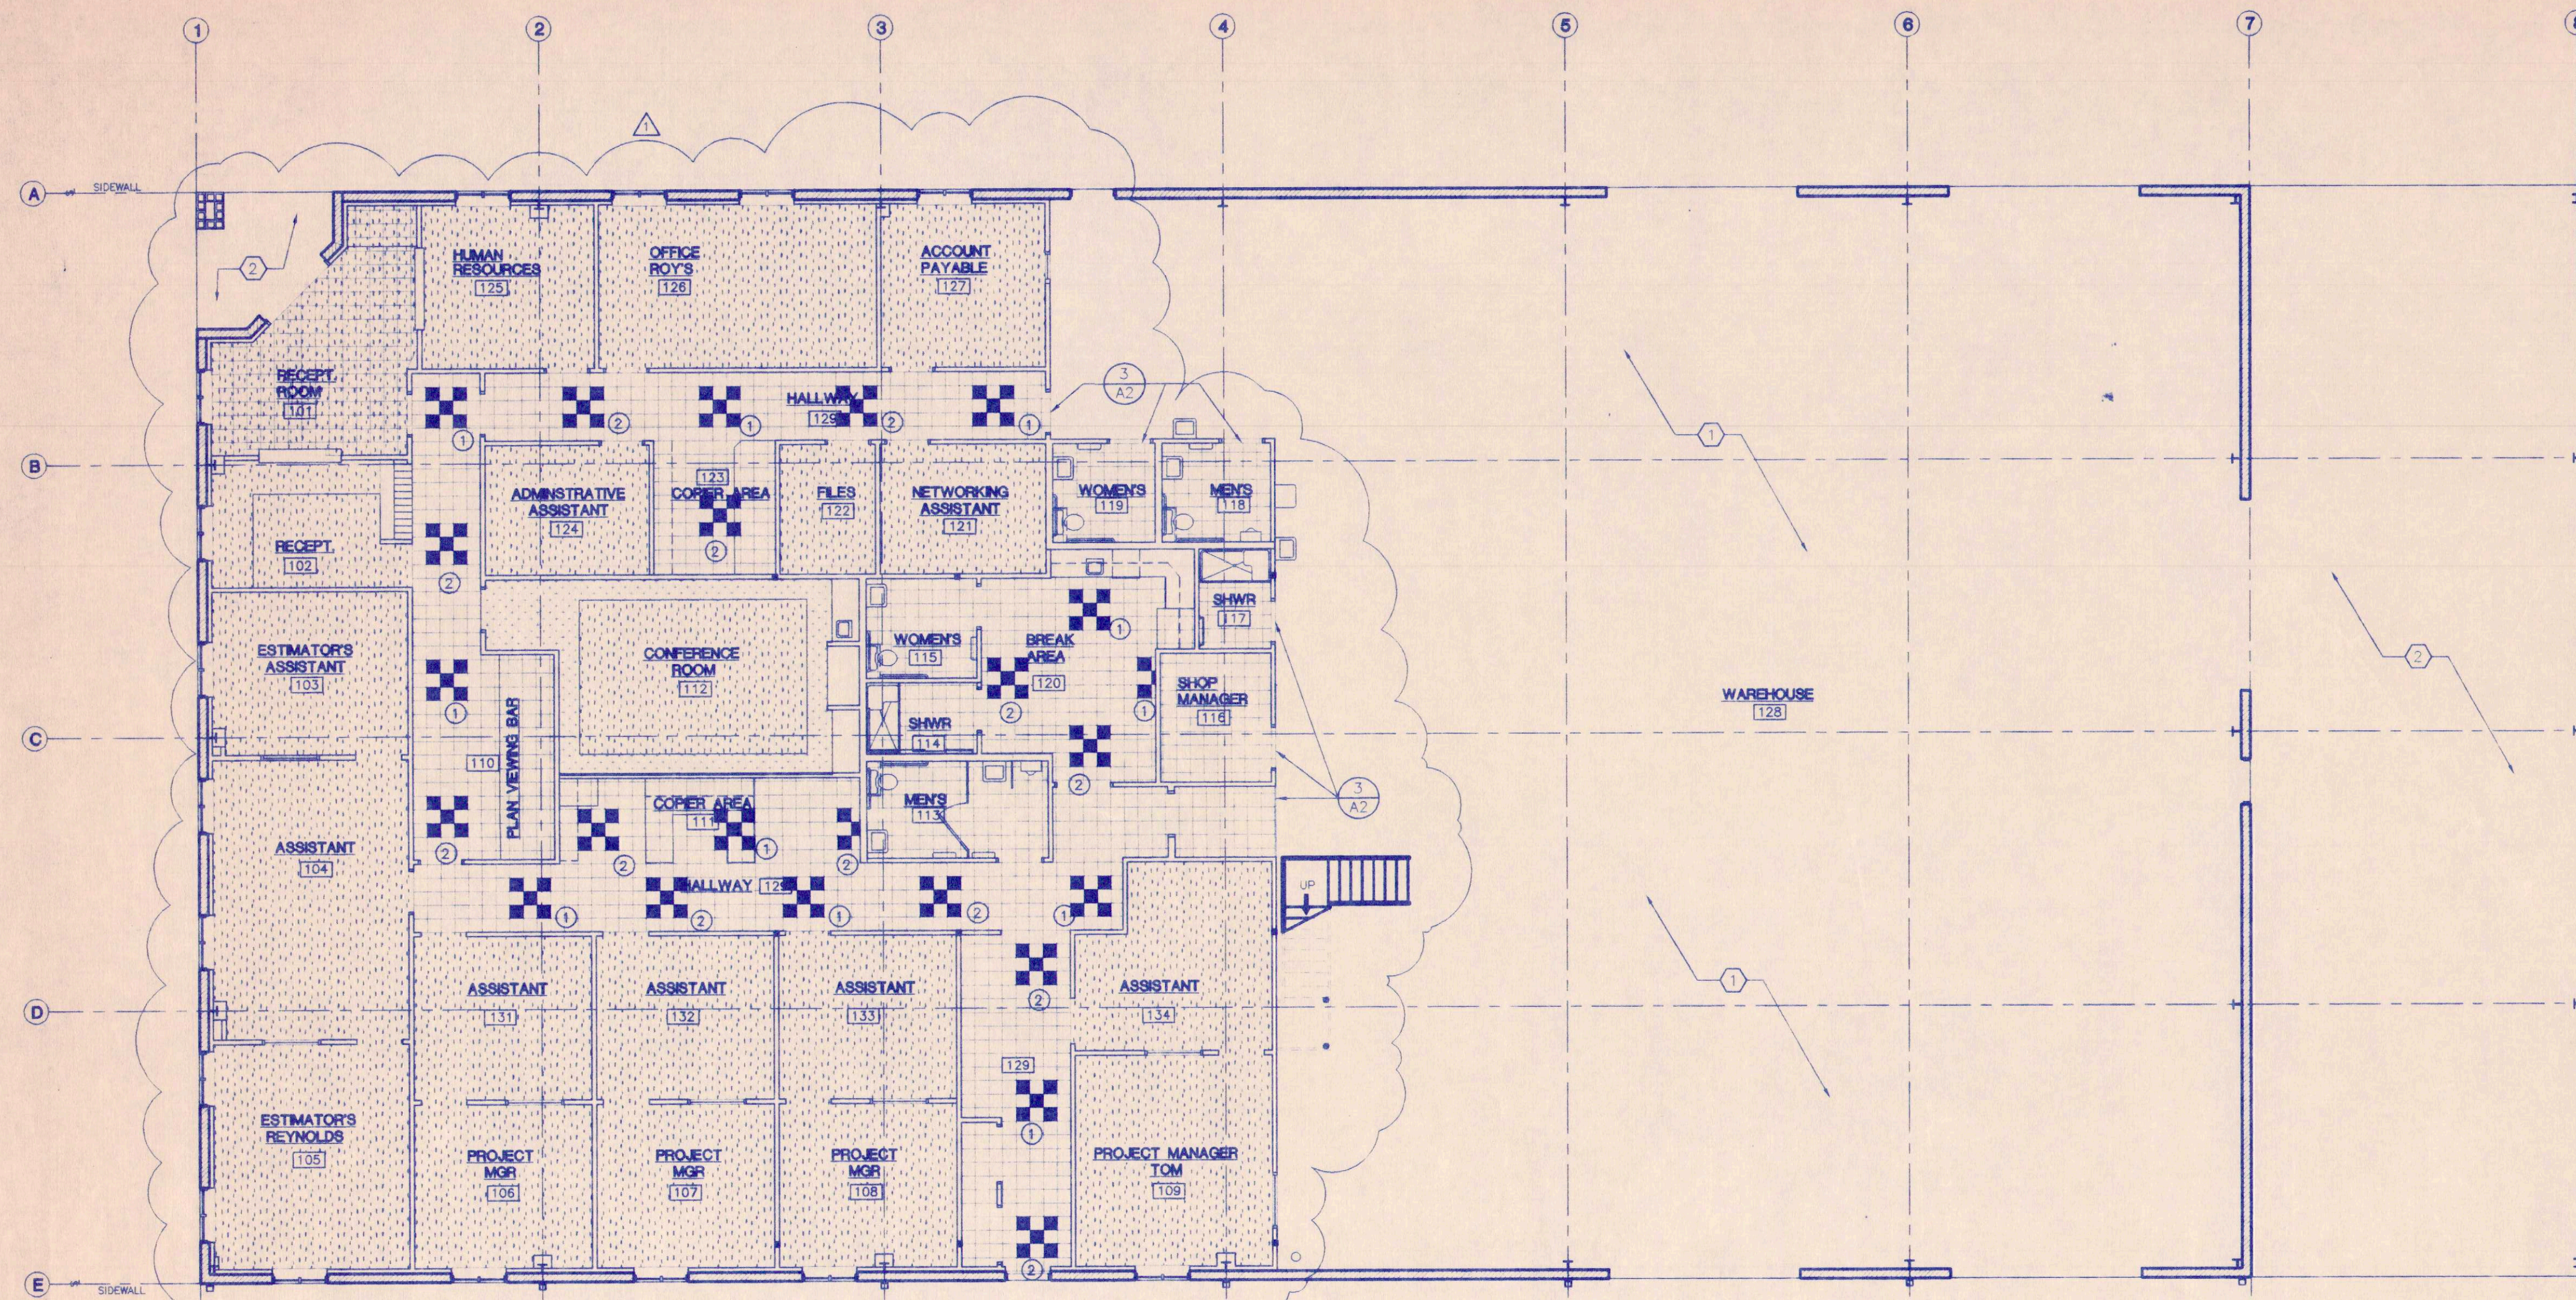


- LEGEND**
- VCT - 12"x12"
 - CT-1 - 12"x12"
 - CP-1 - CARPETING
 - PC-1 - ASHFORD HAREDR/DUSTPROOFER SEALER
 - CP-2 - CARPETING
- KEYNOTES**
- 1 6" CONCRETE FLOOR TO BE ASHFORD FORMULA HARDENER /DUSTPROOFER SEALER
 - 2 CONCRETE APRON WITH ASHFORD FORMULA HARDENER/SEALER "LIGHT" BROOM FINISH
 - 3 MEZZANINE TO BE CONCRETE SLAB SEE STRUCTURAL DRAWINGS FOR CONCRETE SPECIFICATIONS

FLOOR TILE		WALL FINISHES	
VCT-1	LOCATION: HALLWAYS/BREAK AREA COMPANY: MANNINGTON ESSENTIALS ITEM: 112 PEWTER(MAIN), 118 WINEBERRY COLOR: 101 NIGHTBLACK, 121 SILVER WHITE SIZE: TEMPEST NIGHT #39490	PC-1	LOCATION: WAREHOUSE COMPANY: ASHFORD HARDENER/DUSTPROOFER SEALER
CT-1	LOCATION: RECEPTION ROOM COMPANY: DALTILE/PORTALTO/GRIGIO ITEM: GRANITE CD 40 TEXTURED UNPOLISHED COLOR: GROUT: MAPEI, COLOR 11, SAVANNA BEIGE SIZE: 12"x12"	PC-2	LOCATION: CONF. ROOM COMPANY: RICHARDS COLOR: 3276 D "CLAYMIST"
CARPETING		PC-3	LOCATION: HALLWAYS/BREAK AREA/MENS RESTROOM COMPANY: RICHARDS COLOR: 3592F "NORDIC WHITE"
CP-1	LOCATION: OFFICE AREA AND FILE ROOM COMPANY: SHAW ITEM: COMMERCIAL STYLE: WILD CREEK #50639 COLOR: TEMPEST NIGHT #39490	PC-4	LOCATION: WOMENS RESTROOM COMPANY: RICHARDS COLOR: 3154T "ROSE BEIGE"
CP-2	LOCATION: CONFERENCE ROOM COMPANY: SHAW ITEM: COMMERCIAL STYLE: TEMPEST NIGHT #39490	PC-4	LOCATION: OFFICES COMPANY: RICHARDS COLOR: 3273P "LIMESTONE"
CP-3	LOCATION: CONF. RM BORDER COMPANY: SHAW ITEM: COMMERCIAL STYLE: HENNA - #56816 COLOR: CONNECTION 42 - #50257	CEILING FINISHES	
COVE BASE		SUSPENDED CEILING- ACOUSTIC TILE	
VB-1	LOCATION: OFFICE AREA AS NOTED COMPANY: MERGER NOTE: ***CONSIDER RUBBER BASE ITEM: COLOR 607 SIZE: 4" COVE	ACT-1	2"x4" USE ILLUSION REGULAR TILE W/CLIMAPIUS
TILE BASE		ACT-2	2"x2" ARMSTRONG AWES ANGLED REGULAR W/CLIMAPIUS
TB-1	LOCATION: RECEPTION ROOM COMPANY: NOTE: MATCH CT-1 ITEM: SIZE:	COUNTER SHELL- CASE WORK	
CARPET BASE		HPL-1	LOCATION: COMPANY: ITEM: COLOR: FINISH:
CB-2	LOCATION: CONFERENCE ROOM COMPANY: NOTE: ITEM: SIZE:	HPL-2	LOCATION: COMPANY: ITEM: COLOR: FINISH:
		INTERIOR DOOR FINISHES	
		ST-1	LOCATION: OFFICES COMPANY: MOHAWK PREMIUM 2000 PRE-FINISH COLOR: MAHOGANY FINISH: PLAIN SLICED CHERRY PREMIUM

1 FINISH FLOOR PLAN
SCALE: 1/8" = 1'-0"

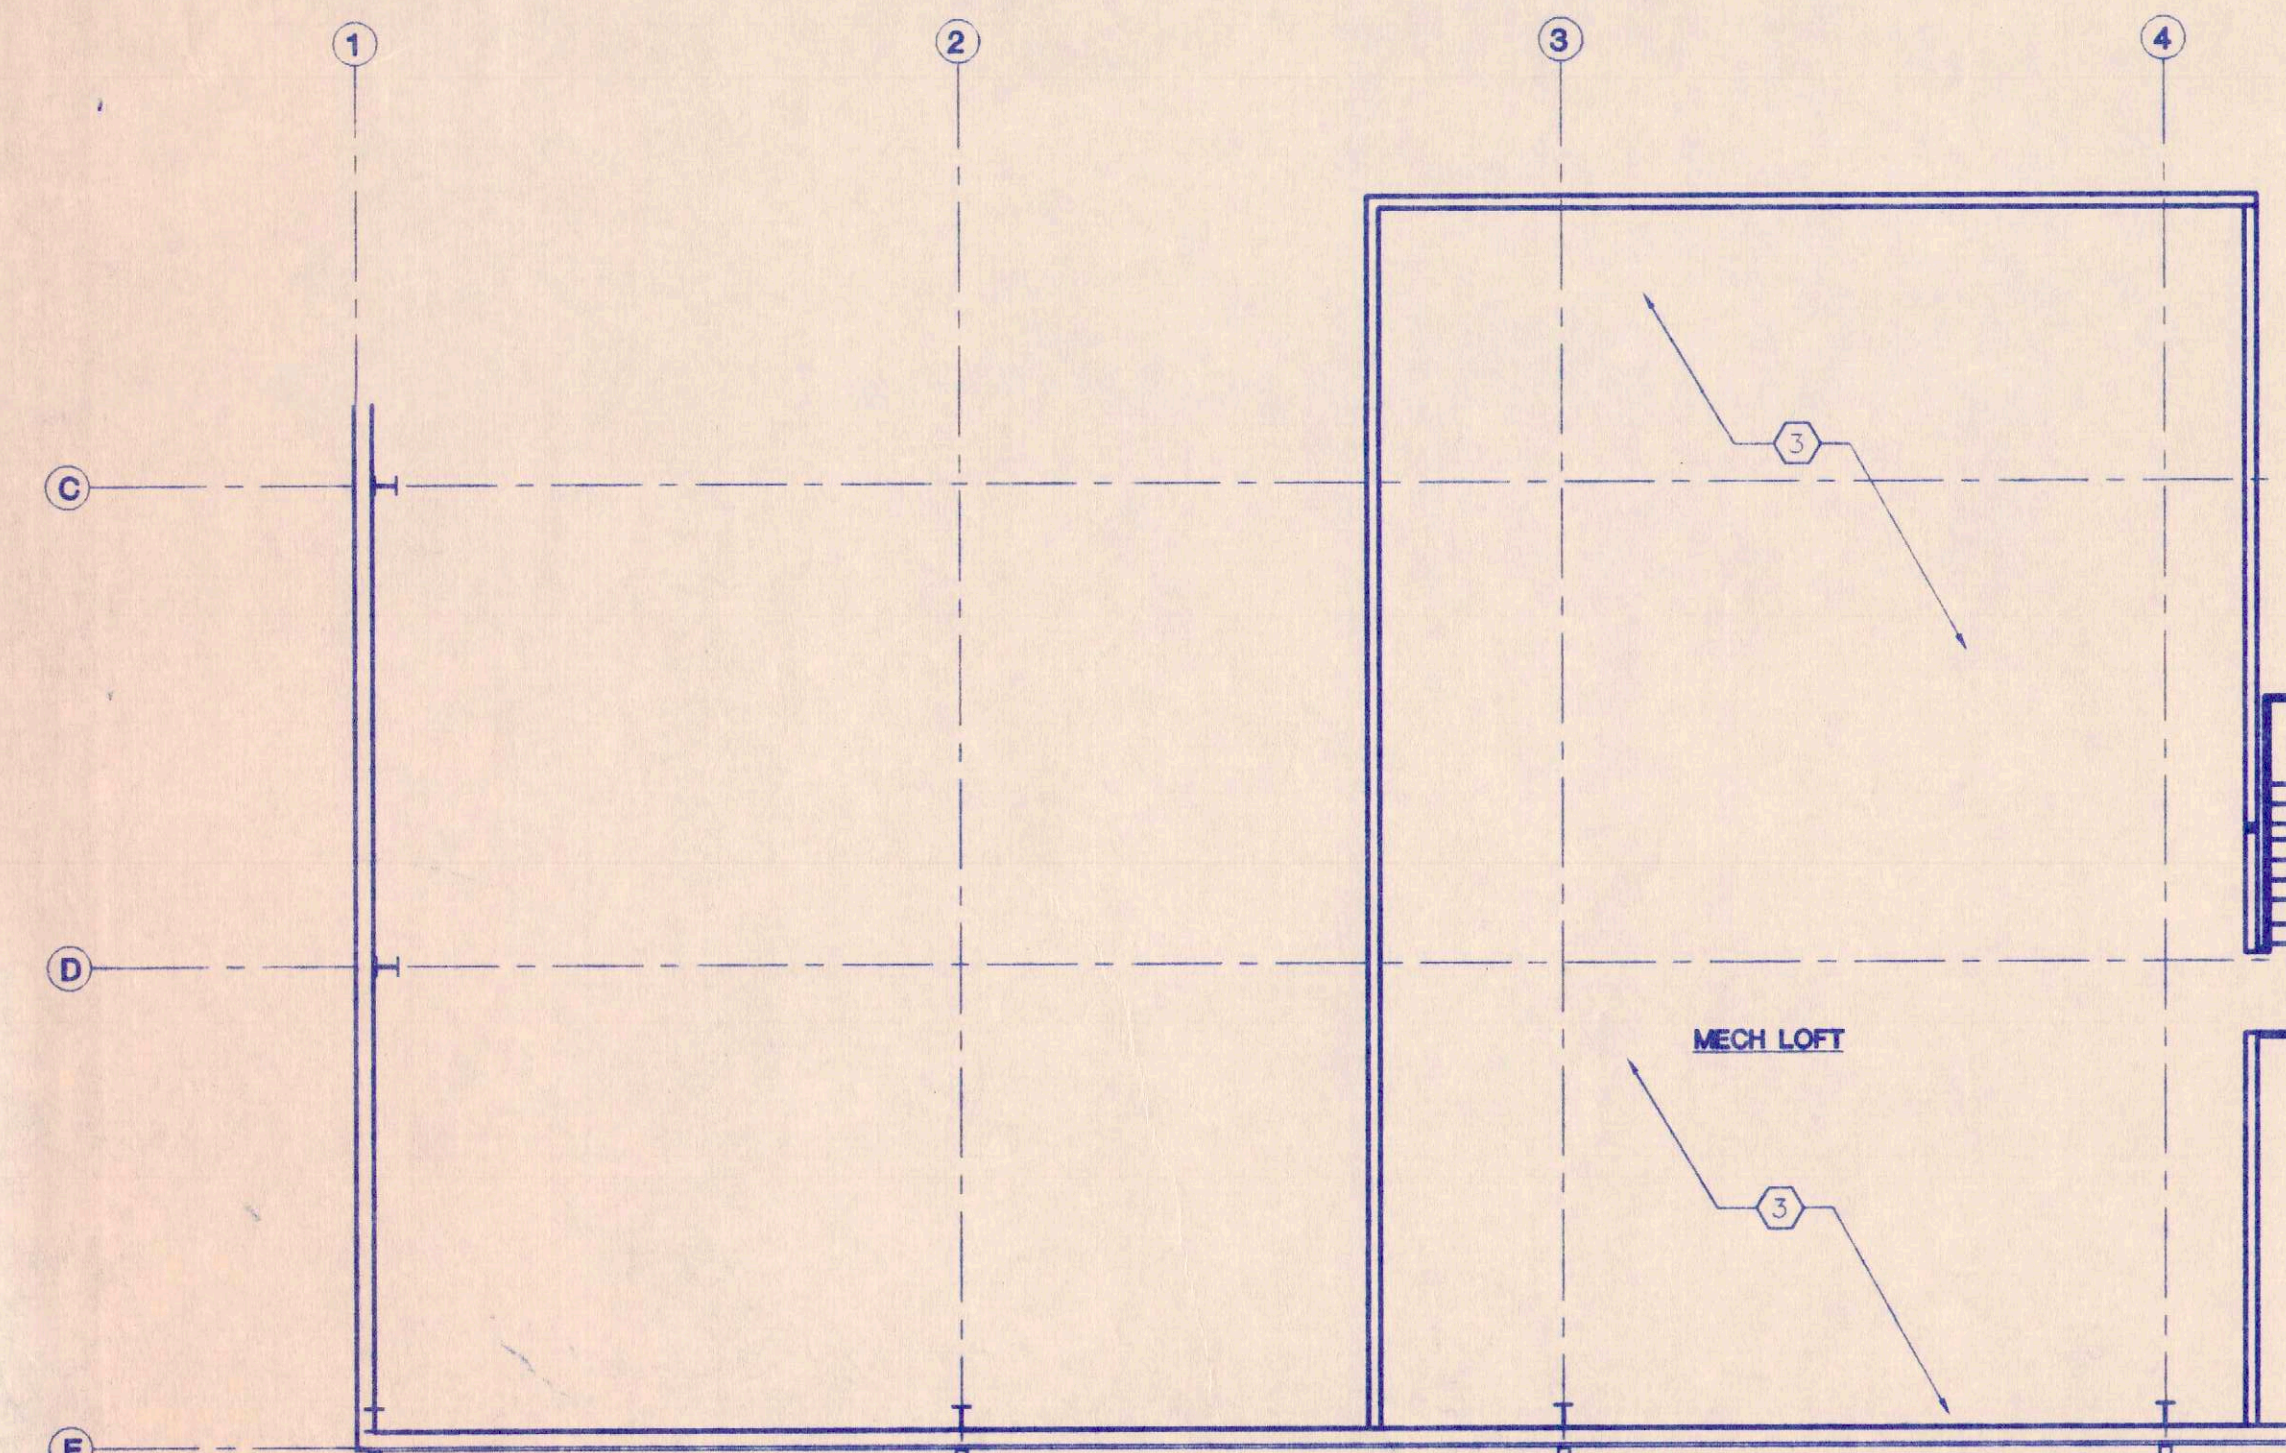


2 MEZZANINE FINISH FLOOR PLAN
SCALE: 1/8" = 1'-0"

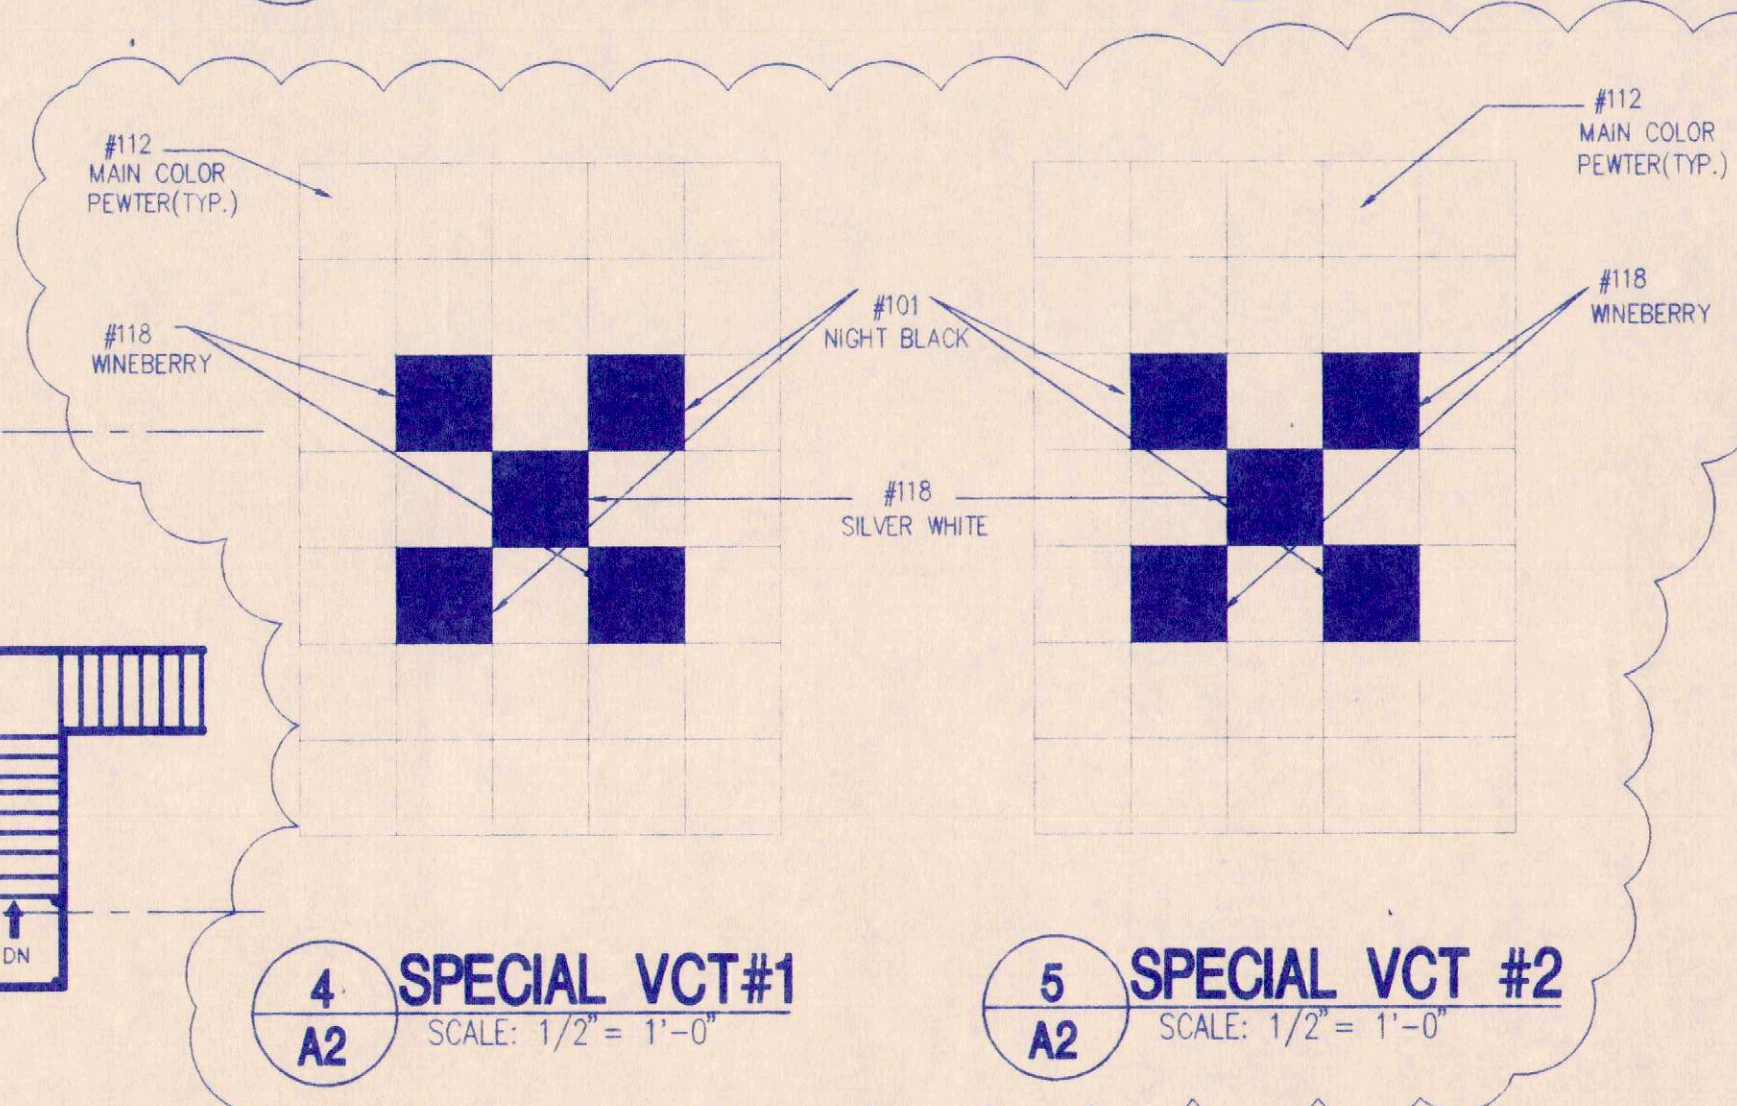

4 SPECIAL VCT#1
SCALE: 1/2" = 1'-0"


5 SPECIAL VCT #2
SCALE: 1/2" = 1'-0"

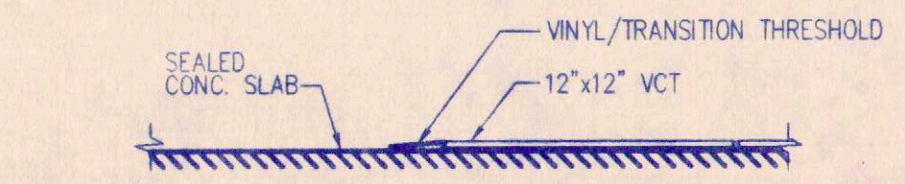

3 CONC. SLAB / VCT DETAIL
SCALE: 1-1/2" = 1'-0"

ROOM FINISH SCHEDULE																			
SYMBOLS		FLOORS		BASE	WALLS	CEILINGS	OTHER FINISHES		REMARKS										
ROOM NUMBER	ROOM DESCRIPTION	VCT-1 VINYL COMPOSITION TILE 12"x12"	CT-1 CERAMIC TILE 12"x12"	CP-1 CARPETING	PC-1 KNOXED FORMULA-HARDNER/SEALER	CP-2 CARPETING	VB-1 3" VINYL BASE	CB-2 CARPET BASE	TB-1 TILE BASE	WP-1 WALL PAPER	ACT-1 ACOUSTICAL TILE - 24"x48"	ACT-2 ACOUSTICAL TILE - 24"x24"	GYPSUM BOARD - PAINTED	NONE - (EXPOSED STRUCTURE)	CEILING HEIGHT	ST-1 DOORS AND FRAMES:			
101	RECEPT. RM.														9'-0"				
102	RECEPT.														9'-0"				
103	ESTIMATOR'S ASSISTANT														9'-0"				
104	ASSISTANT														9'-0"				
105	ESTIMATOR'S - REYNOLDS														9'-0"				
106	PROJECT MANAGER														9'-0"				
107	PROJECT MANAGER														9'-0"				
108	PROJECT MANAGER														9'-0"				
109	PROJECT MANAGER - TOM														9'-0"				
110	PLAN VIEWING BAR														8'-0"				
111	COPIER AREA														8'-0"				
112	CONFERENCE ROOM														9'-0"				
113	MEN'S RESTROOM														8'-0"				
114	SHOWER ROOM														8'-0"				
115	WOMEN'S RESTROOM														8'-0"				
116	SHOP MANAGER														9'-0"				
117	SHOWER ROOM														8'-0"				
118	MEN'S RESTROOM														8'-0"				
119	WOMEN'S RESTROOM														8'-0"				
120	BREAK AREA														8'-0"				
121	NETWORKING ASSISTANT														9'-0"				
122	FILES														9'-0"				
123	COPIER AREA														8'-0"				
124	ADMINISTRATIVE ASSISTANT														9'-0"				
125	HUMAN RESOURCES														9'-0"				
126	OFFICE - ROY'S														9'-0"				
127	ACCOUNT PAYABLE														9'-0"				
128	WAREHOUSE														8'-0"			WAREHOUSE SIDE VINYL BASE ONLY.	
129	HALLWAY														8'-0"				
130	ASSISTANT														9'-0"				
131	ASSISTANT														9'-0"				
132	ASSISTANT														9'-0"				
133	ASSISTANT														9'-0"				
134	ASSISTANT														9'-0"				

RECEIVED
FEB 09 2001
PRIME CONSTRUCTION GROUP, INC.

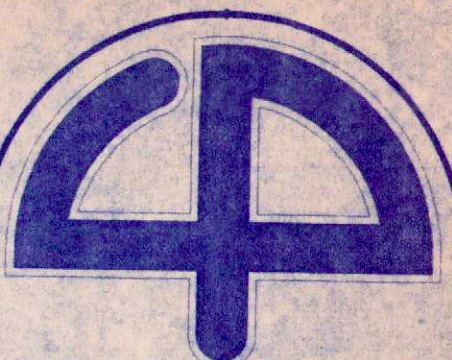

Cuhaci & Peterson
Architects

1220 Alden Road
Orlando, Florida 32803
Ph. 407 228 4220
Fax. 407 228 4215

© COPYRIGHT
All reports, plans, specifications, computer files,
field notes, notes and other documents and
instruments prepared by Cuhaci & Peterson
remain the property of Cuhaci & Peterson
and shall not be copied, reproduced or
transmitted in any form or by any means
without written permission from Cuhaci & Peterson.
Violation of Federal copyright laws.

JOB TITLE
P.C.G., INC.
1000 JETSTREAM DRIVE
ORLANDO, FLORIDA

DRAWING TITLE
REFLECTED CEILING
PLAN


REVISION :	
6/2/00	

JOB NO.	99228
SCALE	AS SHOWN
DATE	4/20/2000
DRAWN	CRW
CHECKED	JAF
DRAWING NO.	

A3

CEILING LEGEND


- EXIT LIGHT (WALL MOUNTED)
- EMERGENCY EXIT LIGHT
- HIGH BAY FIXTURE METAL HALIDE
- 4'-0" FLUORESCENT LIGHT FIXTURE
- 2'-0"x4'-0" FLUORESCENT LIGHT FIXTURE
- 2'-0"x2'-0" FLUORESCENT LIGHT FIXTURE
- 2'-0"x4'-0" FLUORESCENT LIGHT FIXTURE W/PARABOLIC REFLECTORS
- 2'-0"x2'-0" LIGHT FIXTURE W/PARABOLIC REFLECTORS
- RECESSED LIGHT
- WALL SCONCE
- WALL MOUNTED EXTERIOR FIXTURES
- CEILING HEIGHT TAG

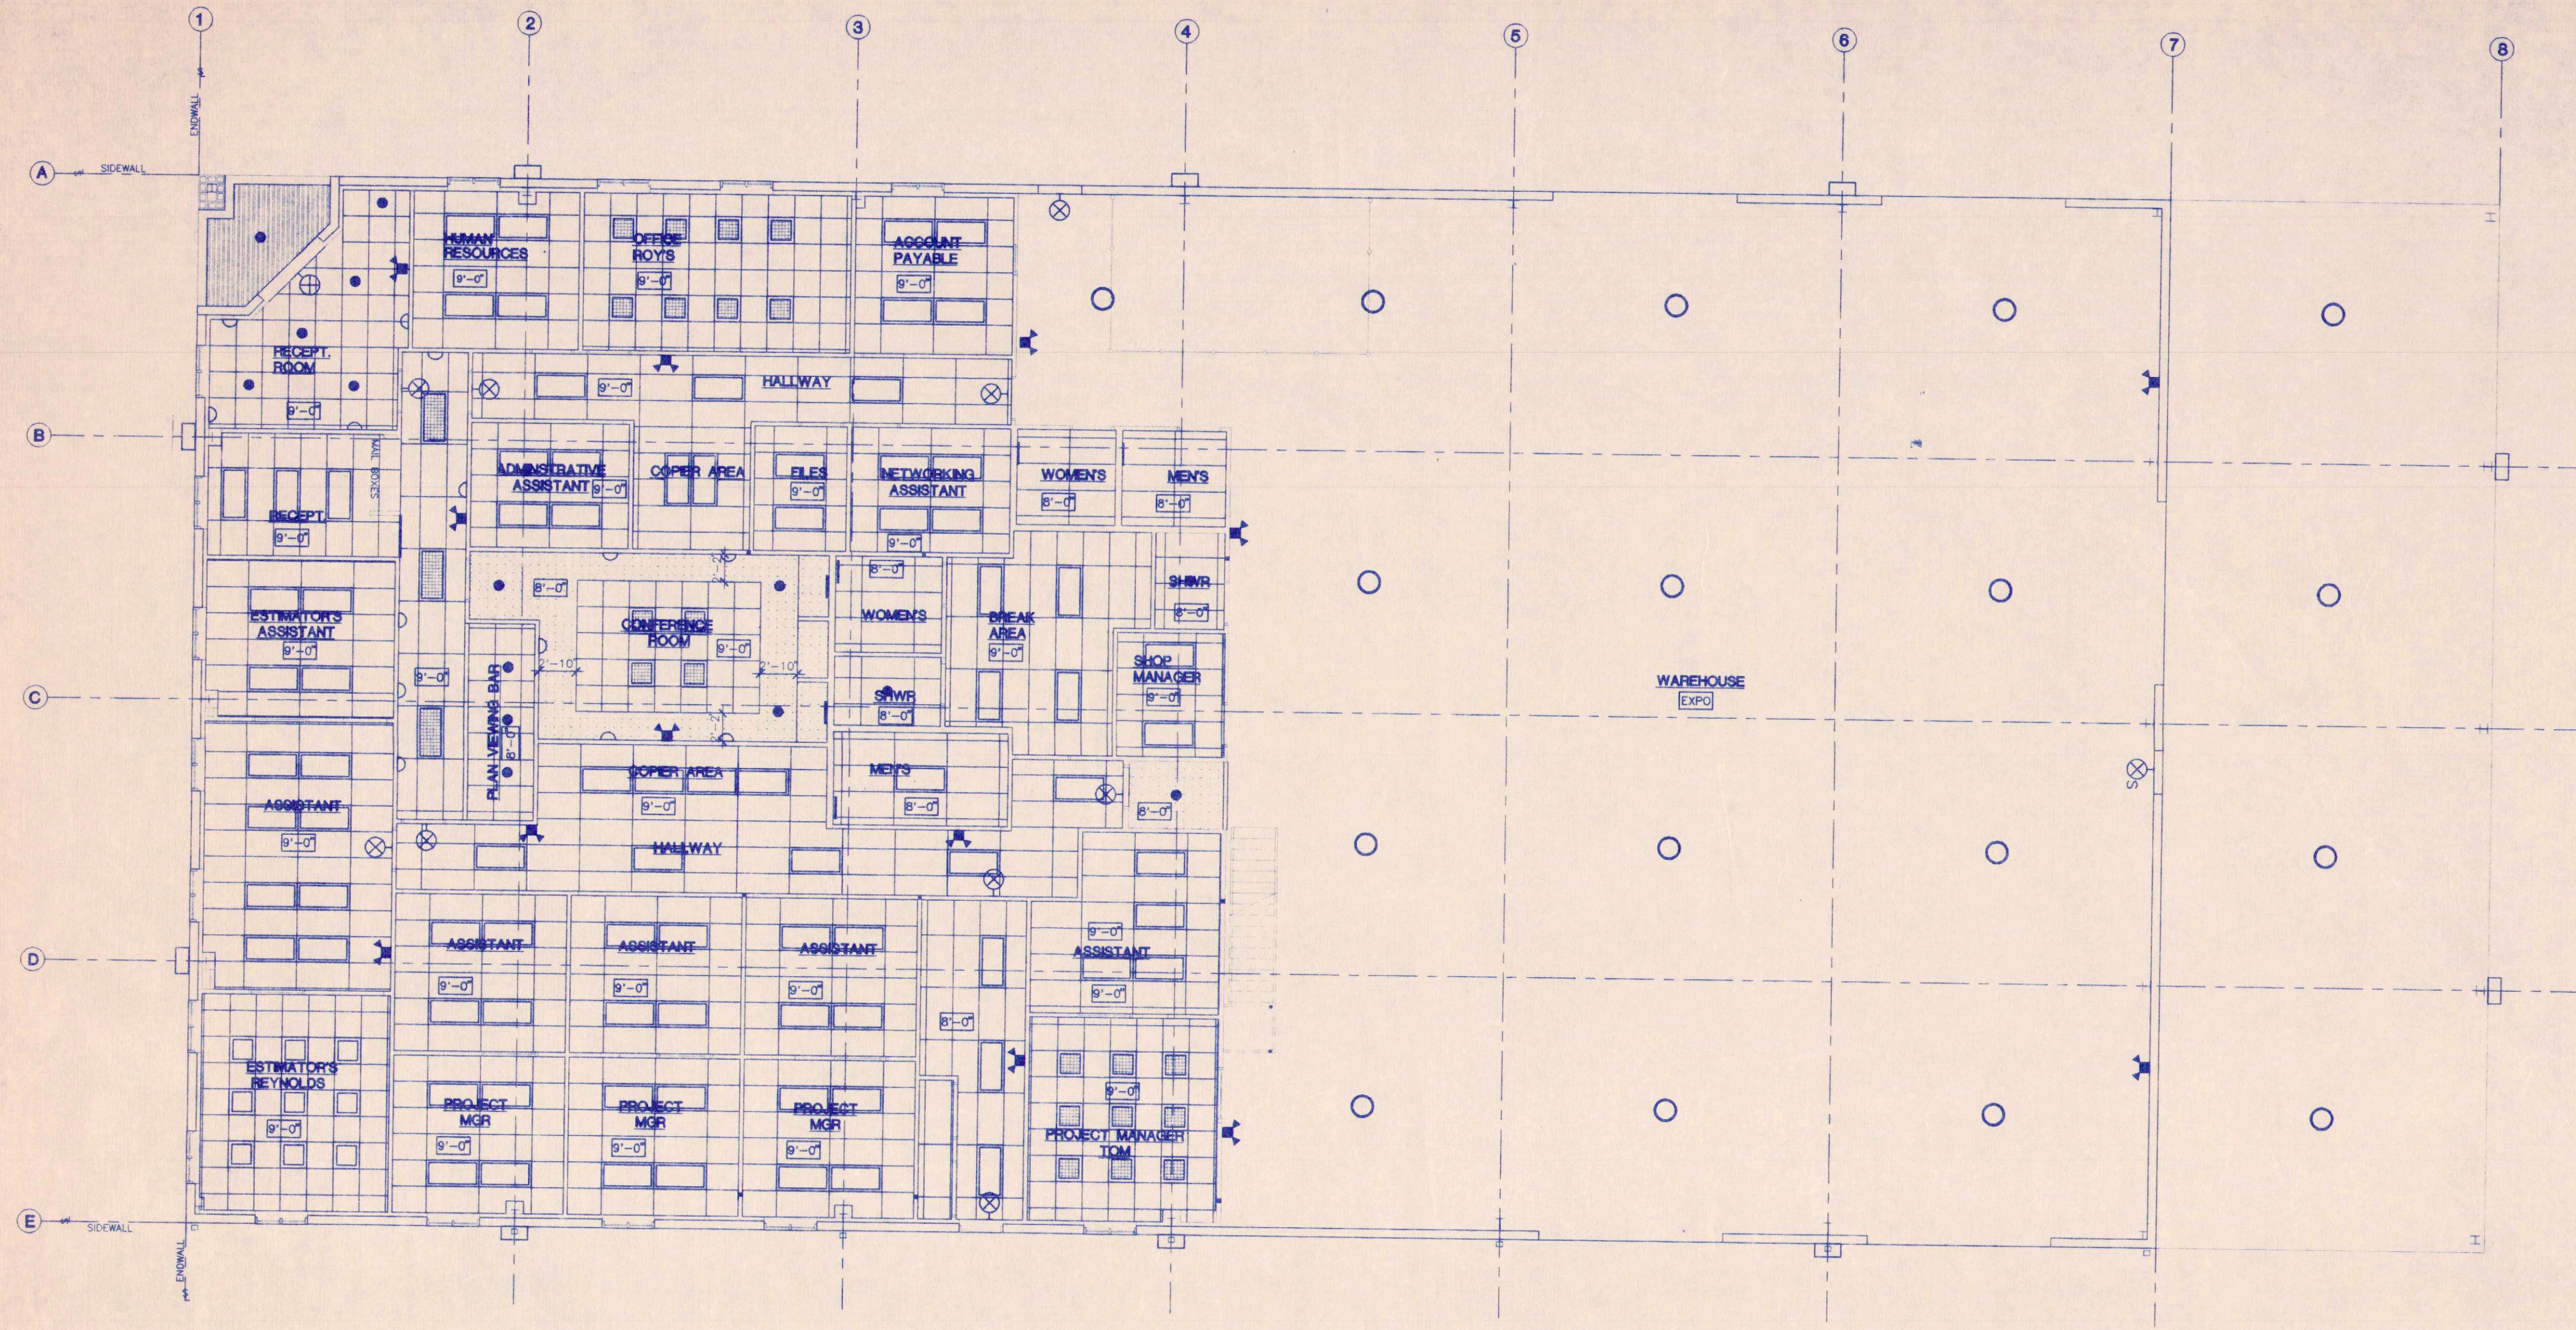

1
A3 REFLECTED CEILING PLAN
SCALE: 1/8" = 1'-0"




2
A3 MECH. MEZZANINE CEILING PLAN
SCALE: 1/8" = 1'-0"

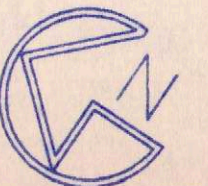

AS BUILT

RELEASED FOR

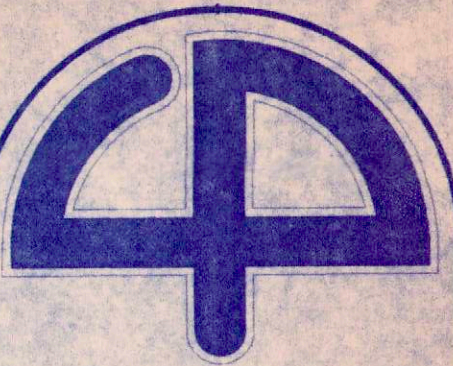


Cuhaci & Peterson
Architects

1220 Alden Road
Orlando, Florida 32803
Ph. 407 228 4220
Fax. 407 228 4219

© copyright
All reports, plans, specifications, computer files,
field notes, notes and other documents and
instruments prepared by Cuhaci & Peterson
Architects (C & P) as instruments of service
remain the property of C & P. C & P
shall retain all common law, statutory and other
reserved rights, including the copyright therein.
Any use or reproduction of this document with-
out written permission from C & P is a
violation of Federal copyright law.

- KEYED NOTES:
- ① MR "24" STANDING SEAM ROOF
BY BUTLER MFG. CO.
 - ② PRE-MOLDED GUTTER BY
BUTLER MFG. CO.
 - ③ PRE-MOLDED DOWNSPOUT BY
BUTLER MFG. CO.
 - ④ FASCIA SYSTEM BY BUTLER
MFG. CO.
 - ⑤ RAKE TRIM BY BUTLER MFG. CO.

AS BUILT

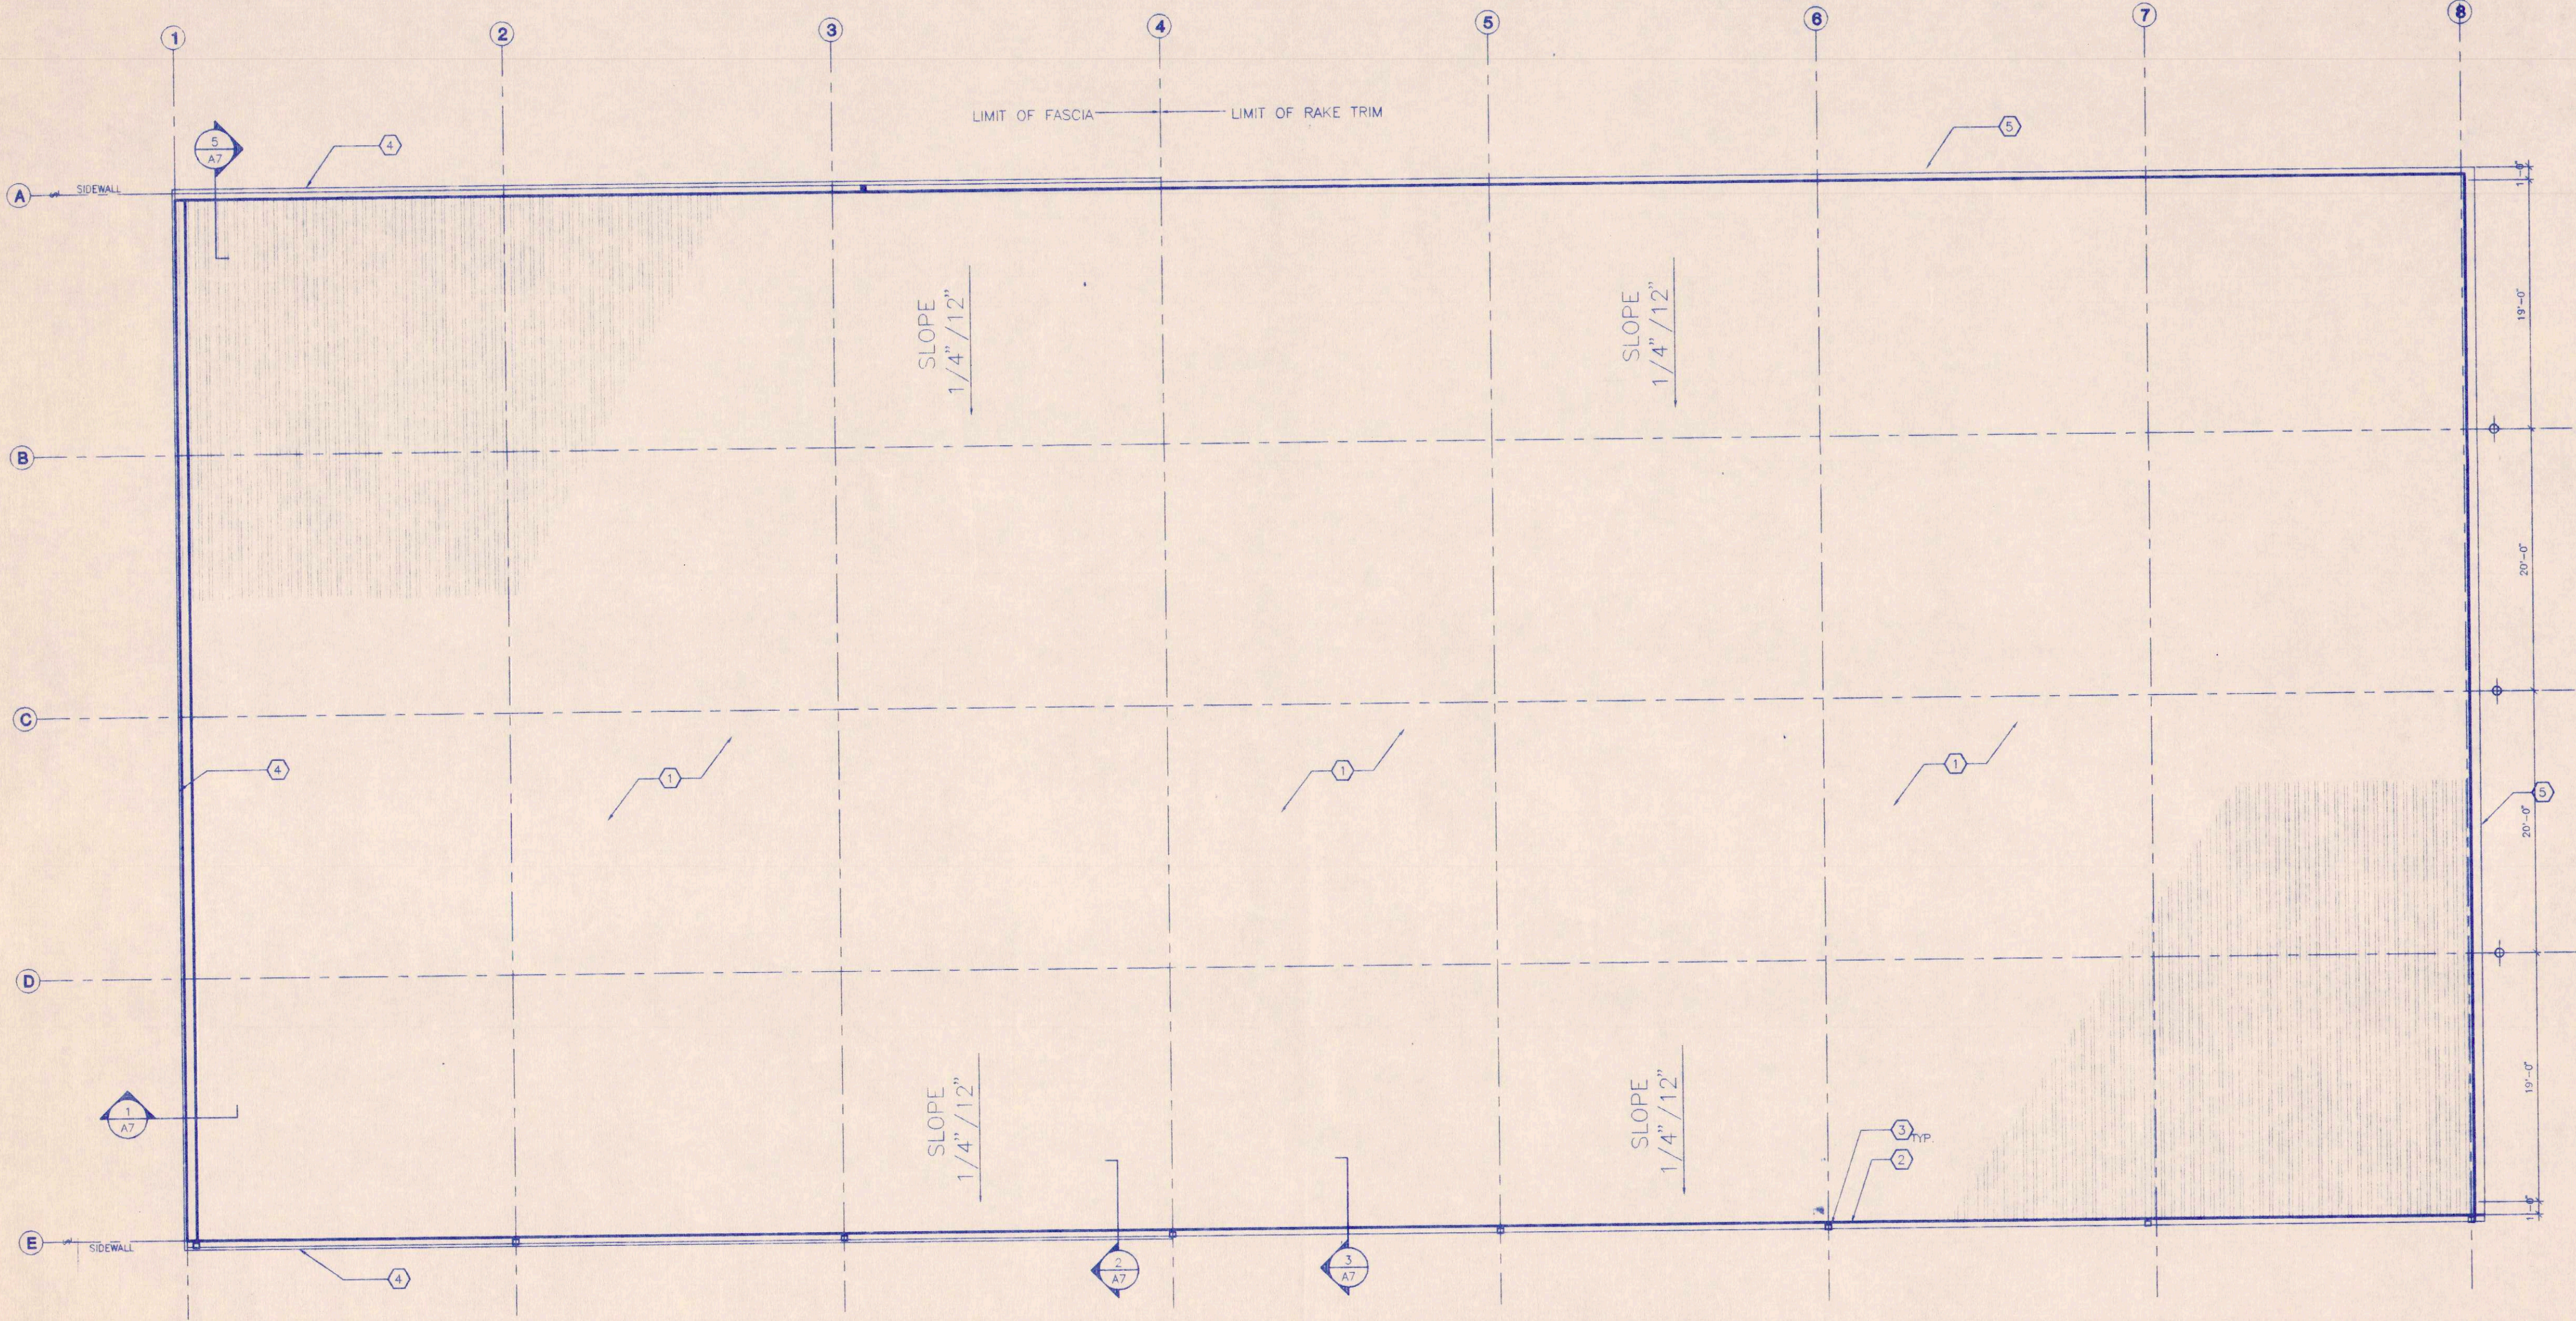

1 ROOF PLAN
A4 SCALE: 1/8" = 1'-0"



JOB TITLE

P.C.G. INC.

1000 JETSTREAM DRIVE

ORLANDO, FLORIDA

DRAWING TITLE

ROOF PLAN

REVISION :	
Δ 6/2/2000	Δ
Δ	Δ
Δ	Δ
Δ	Δ

JOB NO.	99228
SCALE	AS SHOWN
DATE	4/20/2000
DRAWN	CRW
CHECKED	JAF
DRAWING NO.	

A4



Cuhaci & Peterson
Architects
1220 Alden Road
Orlando, Florida 32803
Ph. 407 228 4220
Fax. 407 228 4219

© COPYRIGHT
All reports, plans, specifications, computer files,
field data, notes and other documents and
instruments prepared by Cuhaci & Peterson
Architects (C & P) as instruments of service
remain the property of C & P. C & P
shall retain all common law, statutory and other
reserved rights, including the copyright therein.
Any use or reproduction of this document with-
out written permission from C & P is a
violation of Federal copyright laws.

JOB TITLE
P.C.G. INC.
1000 JETSTREAM DRIVE
ORLANDO, FLORIDA

DRAWING TITLE
EXTERIOR ELEVATIONS
& DETAILS

REVISION	
1	4/27/00
2	6/2/2000
3	
4	

JOB NO. 99228
SCALE AS SHOWN
DATE 4/10/2000
DRAWN CRW
CHECKED JAF
DRAWING NO.


A5

KEY NOTES:


- 1 SIGN TO EQUAL PRIME CONSTRUCTION GROUP INC. LOGO
- 2 ENDWALL COUNTER FLASHING BEHIND FASCIA
- 3 TOP TRIM @ FASCIA
- 4 FASCIA PANEL - SHADOWLAY BY BUTLER MANUFACTURING COMPANY
- 5 CORNER TRIM BY BUTLER MANUFACTURING COMPANY
- 6 SHADOWLAY BY BUTLER MANUFACTURING COMPANY
- 7 (2) COURSES PAINTED & SEALED STANDARD CONCRETE MASONRY
- 8 1" INSULATED CLEAR GLASS W/INTERNAL COLONIAL MUNTINS IN ALUMINUM STOREFRONT SYSTEM
- 9 SPLIT FACE CONCRETE MASONRY
- 10 VERTICAL CONTROL JOINT @ ALL CENTERLINES OF PRE ENGINEERED COLUMNS
- 11 FLUTED SPLIT FACE CONCRETE MASONRY
- 12 ALUMINUM STOREFRONT BY OTHERS
- 13 MR-24 ROOF PANELS R13 BATT INSULATION
- 14 14' W. x 16' OVERHEAD DOORS
- 15 DOWNSPOUT BY BUTLER MANUFACTURING COMPANY
- 16 GUTTERING
- 17 3' x 7' MANDOR W/4"HEADER
- 18 WALL PACK EXTERIOR LIGHT RE: ELECTRICAL
- 19 CONCRETE FILLED 8" STEEL BOLLARD
- 20 MECHANICALLY OPERATED EXHAUST FAN(SEE MECH)
- 21 LOUVER W/ INSECT SCREEN(SEE MECH)

FINISH COLOR KEY


- C-1 BIRCH WHITE BUTLER-COTE, A FULL STRENGTH, 70% KYNAR 500 OR HYLAR 5000 FINISH
- C-2 BAY BLUE BUTLER-COTE, A FULL STRENGTH, 70% KYNAR 500 OR HYLAR 5000 FINISH
- C-3 BAY BLUE BUTLER-COTE COLOR PRIMED DOOR
- C-4 SMOOTH STANDARD CONCRETE MASONRY CHARCOAL GREY
- C-5 FLUTED SPLIT FACE BLOCK CHARCOAL GREY
- C-6 ICI 120 "CHERRY RED" THE BRIGHT PALETTE, USE A BLOCK SEALER PRIOR TO FINISH COLOR

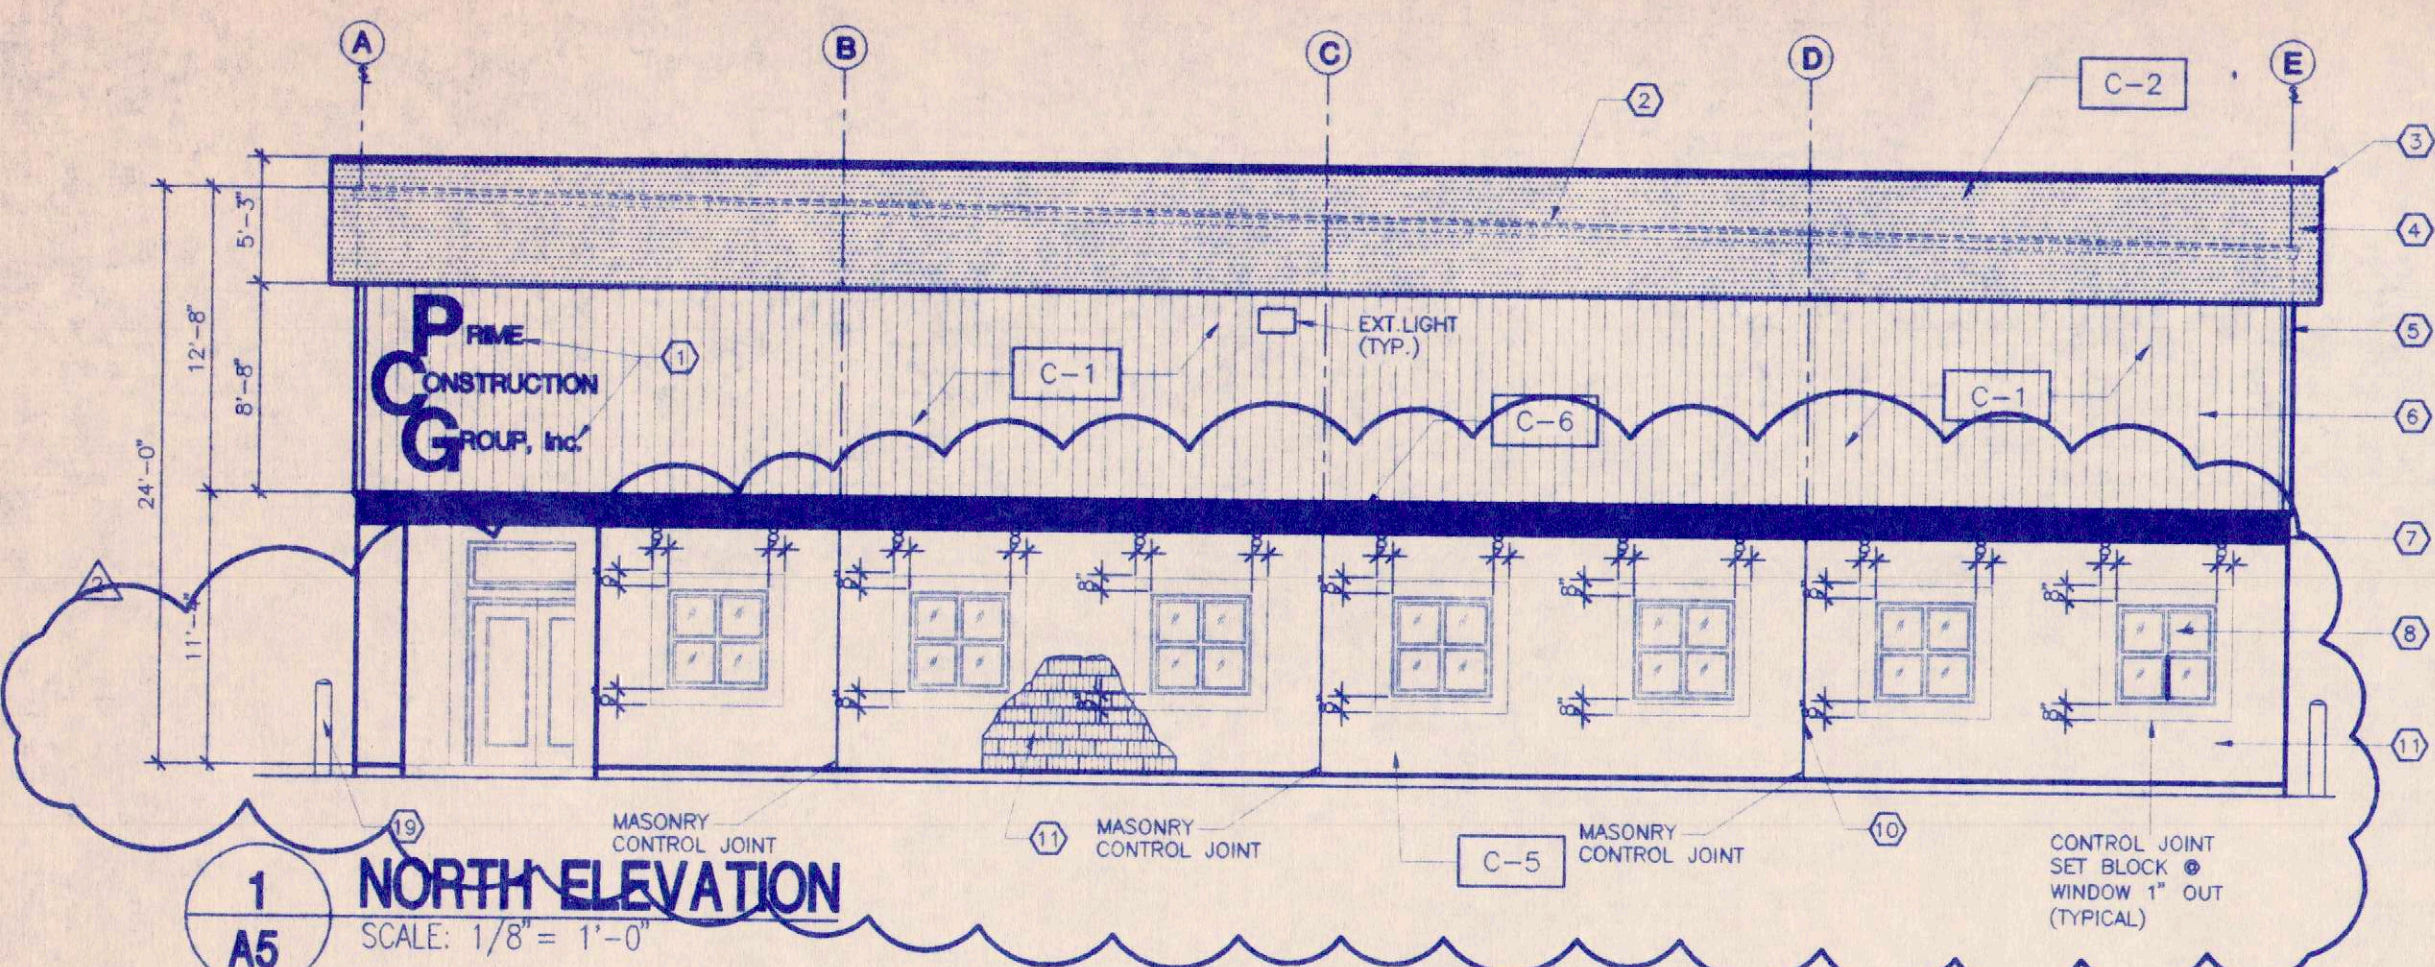


1 NORTH ELEVATION
SCALE: 1/8" = 1'-0"

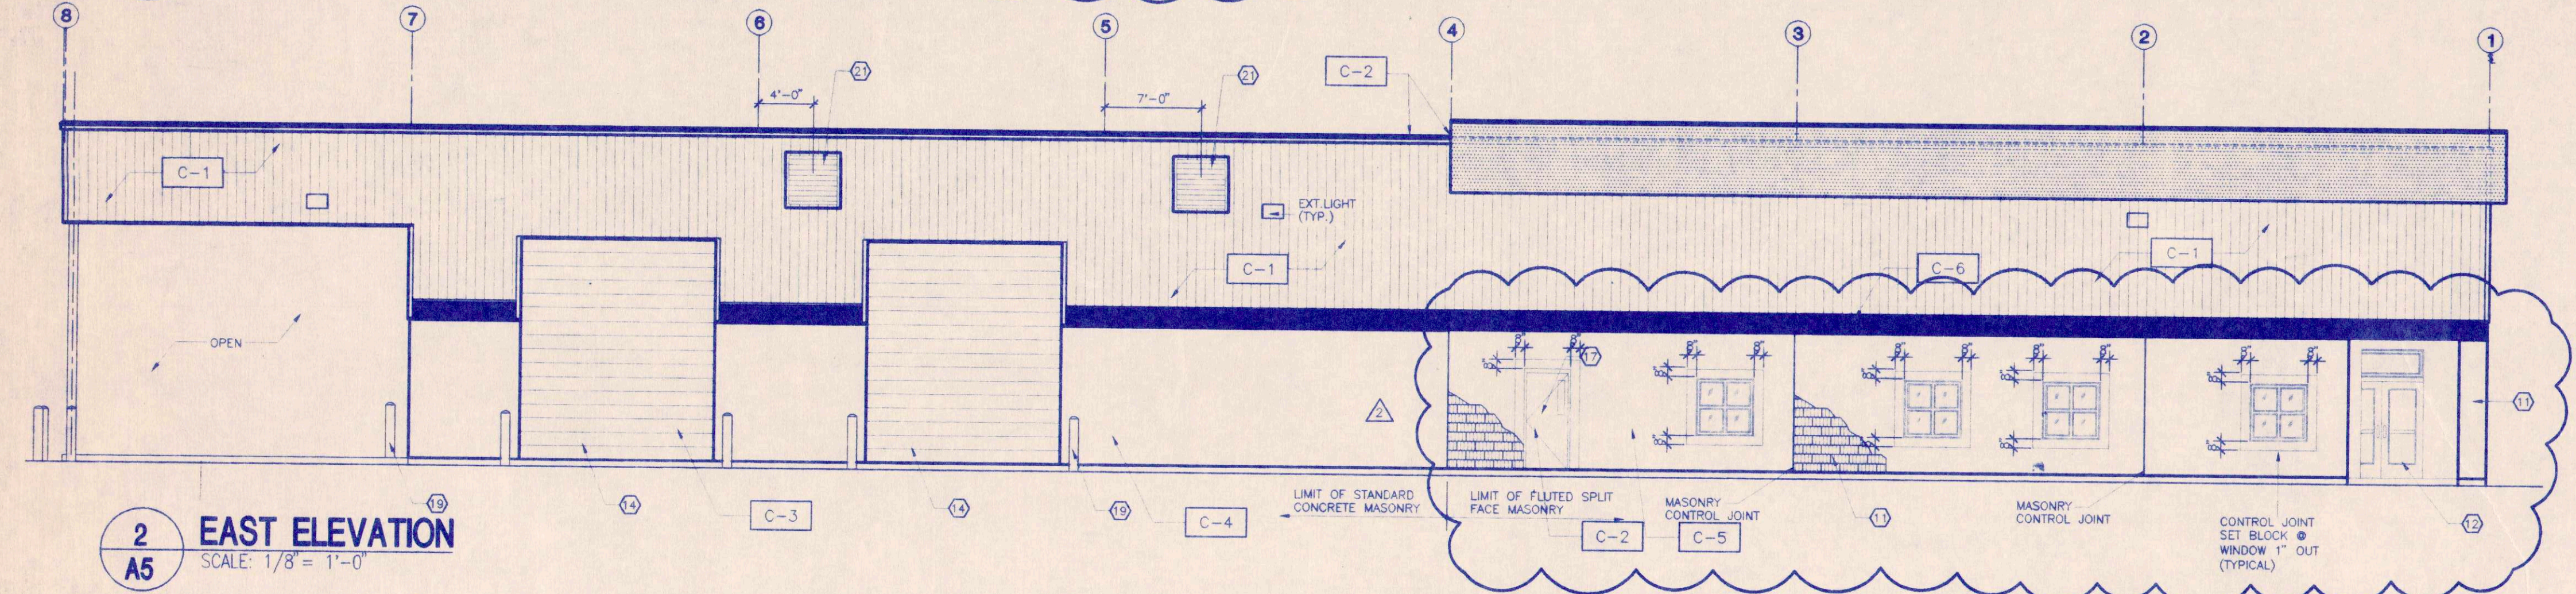


2 EAST ELEVATION
SCALE: 1/8" = 1'-0"

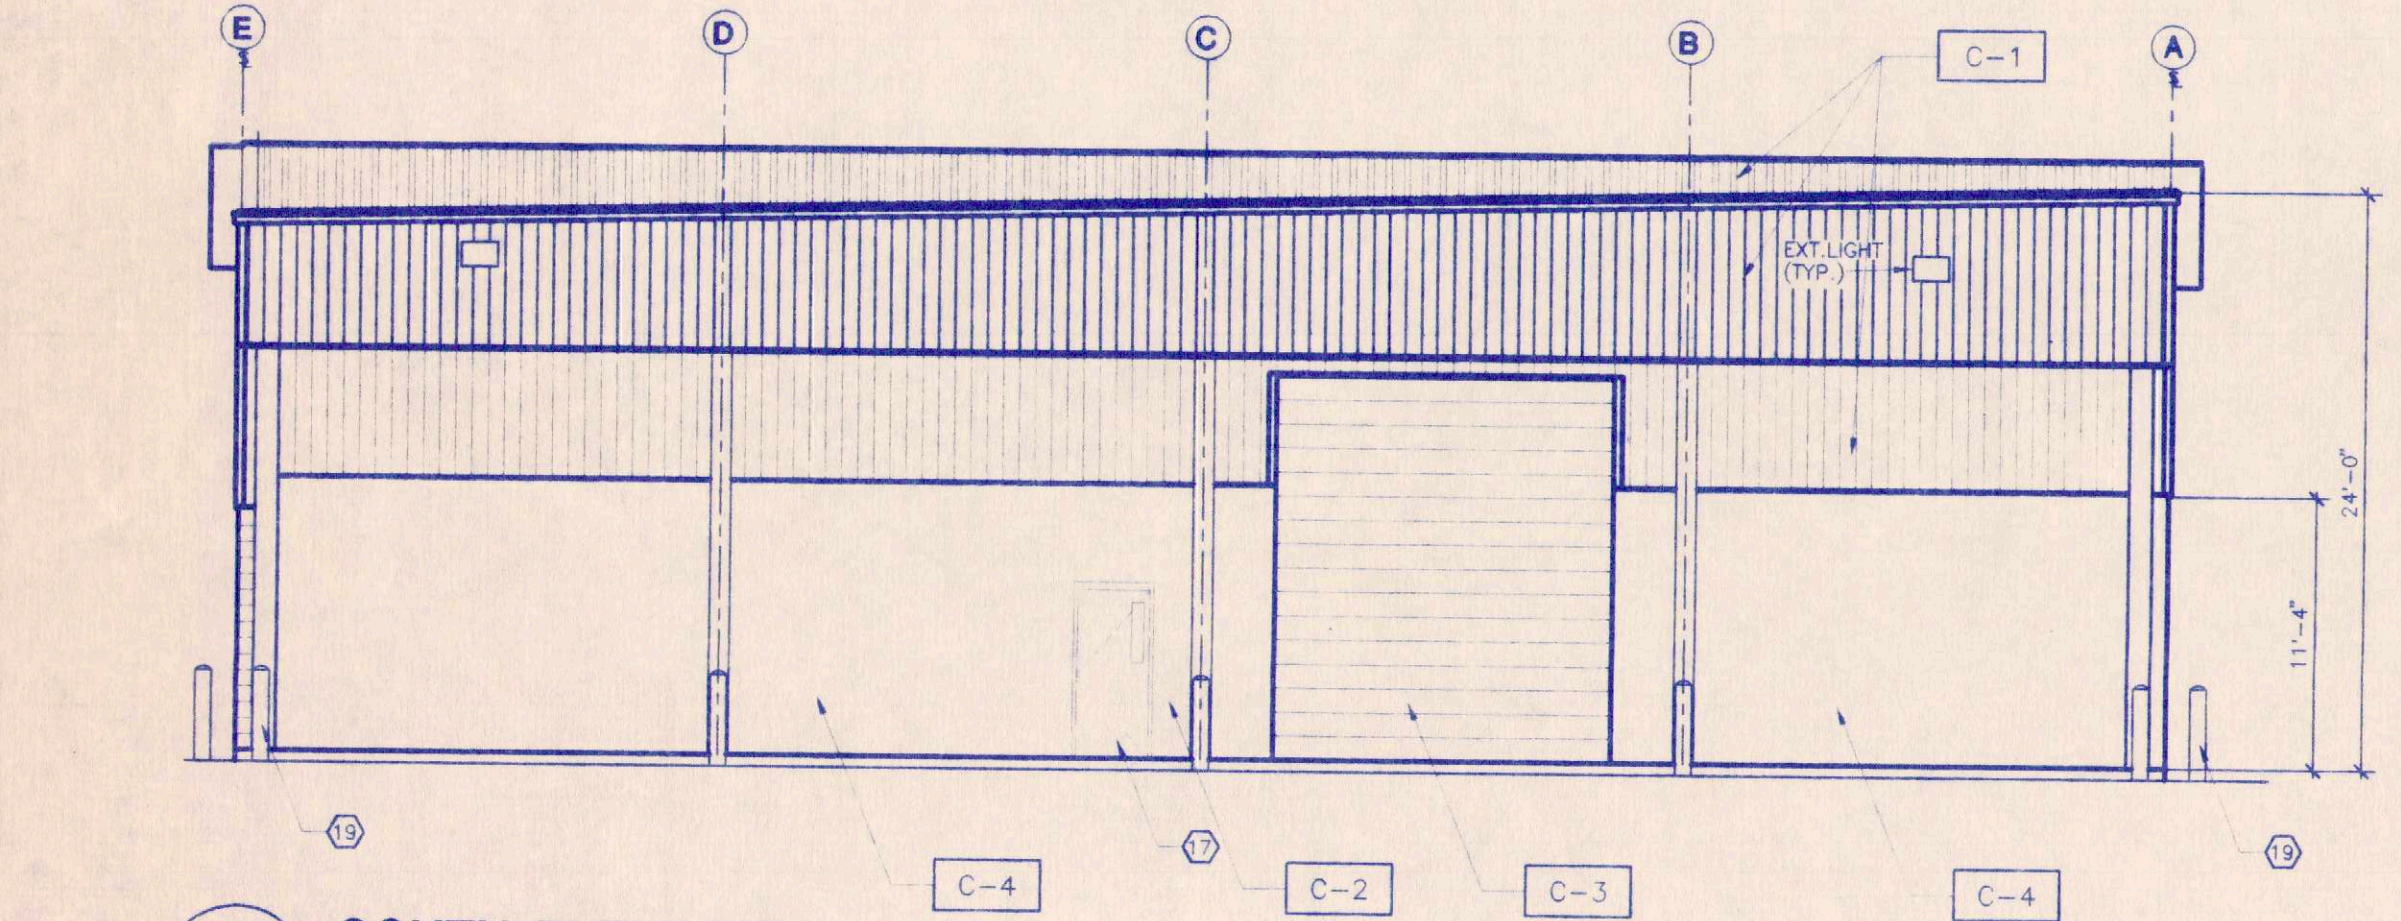


3 SOUTH ELEVATION
SCALE: 1/8" = 1'-0"

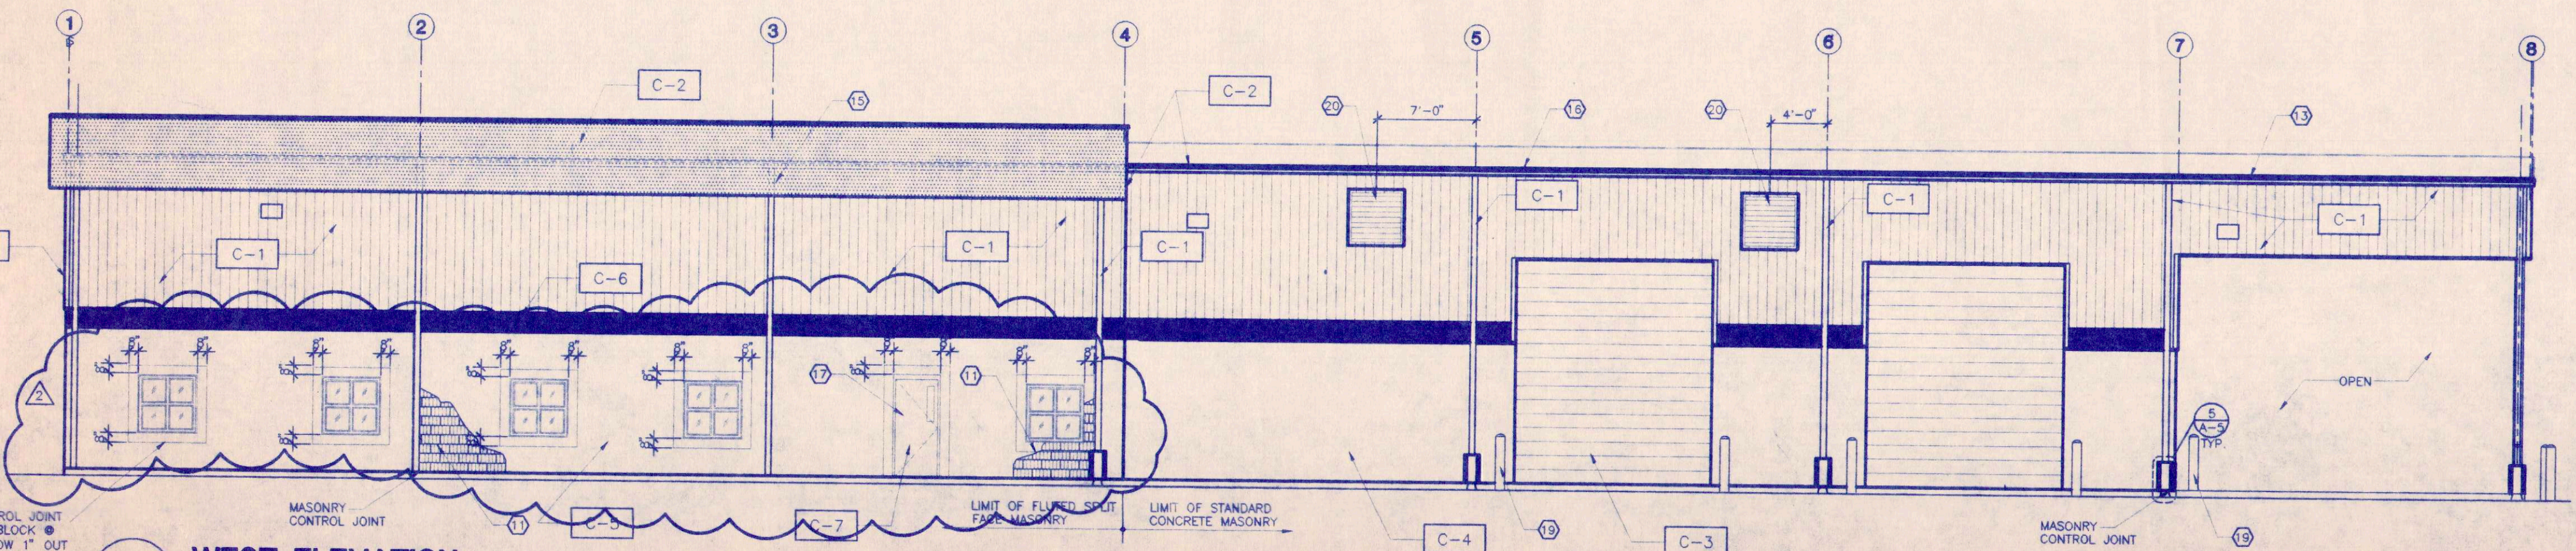


4 WEST ELEVATION
SCALE: 1/8" = 1'-0"

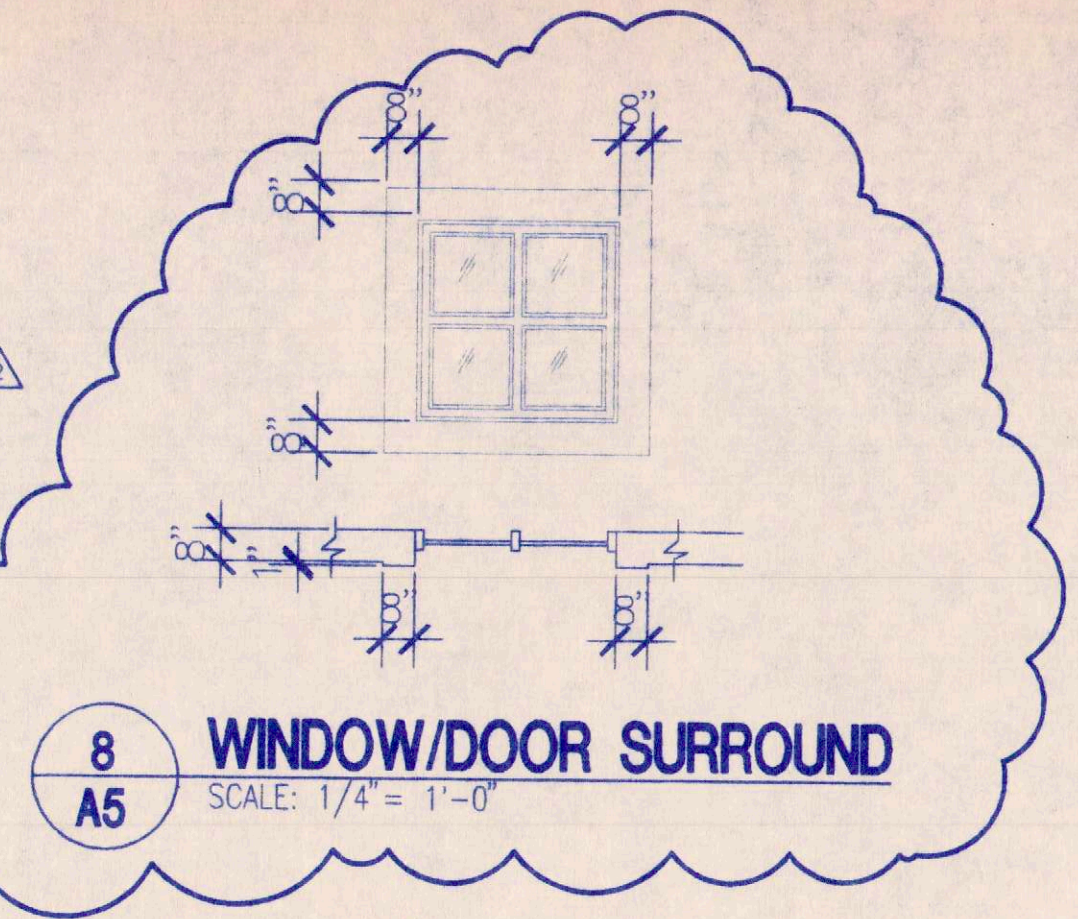



8 WINDOW/DOOR SURROUND
SCALE: 1/4" = 1'-0"

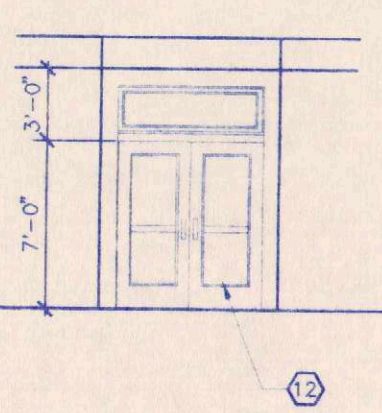

6 ENTRY DOORS
SCALE: 1/8" = 1'-0"

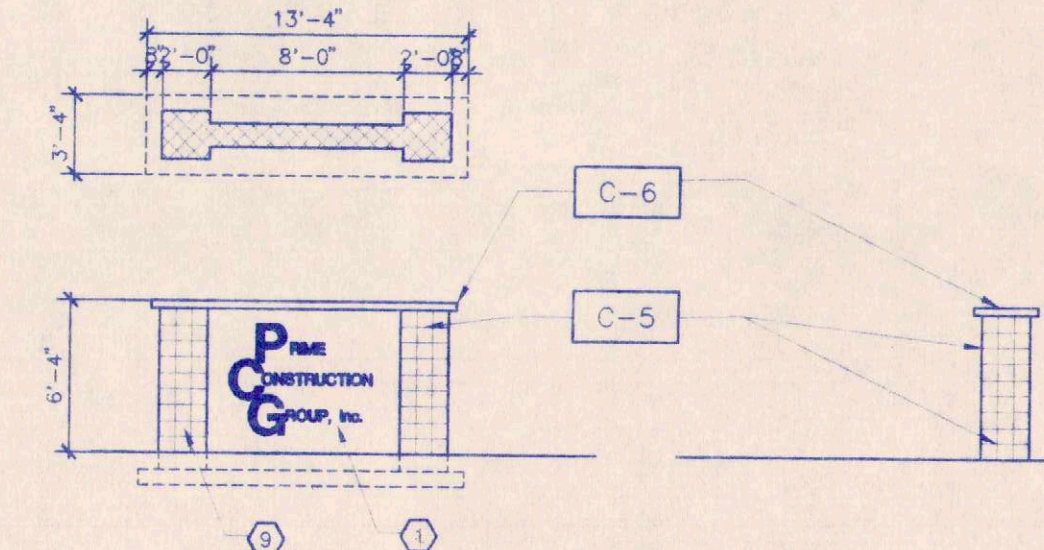


7 ENTRY SIGN DETAIL
SCALE: 1/8" = 1'-0"

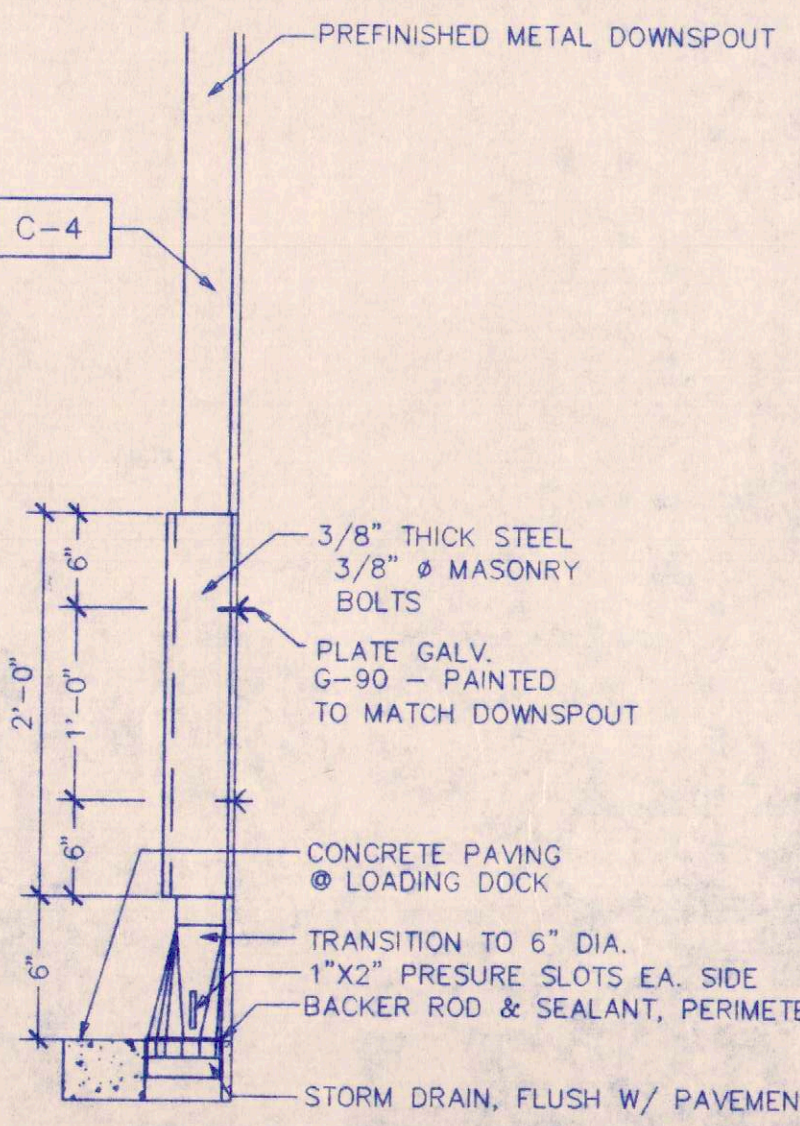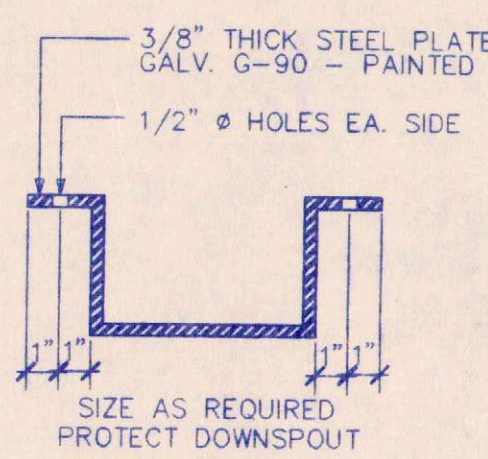

5 DOWNSPOUT GUARD DTL.
SCALE: 3/16" = 1'-0"

RELEASED FOR
CONSTRUCTION (DATE)

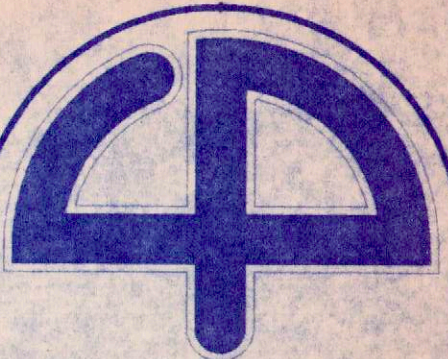

Cuhaci & Peterson
Architects

1220 Alden Road
Orlando, Florida 32803
Ph. 407 228 4220
Fax. 407 228 4219

© COPYRIGHT
All reports, plans, specifications, computer files,
field data, notes and other documents and
instruments prepared by Cuhaci & Peterson
Architects (C & P) as instruments of service
remain the property of C & P. C & P
shall retain all common law, statutory and other
reserved rights, including the copyright therein.
Any use or reproduction of this document with-
out written permission from C & P is a
violation of Federal copyright laws.

P.C.G. INC.
1000 JETPORT DRIVE
ORLANDO, FLORIDA

JOB TITLE

DRAWING TITLE



BUILDING SECTIONS
& SECTION DETAILS

REVISION:	
1	6/2/2000
2	
3	
4	


JOB NO.	99228
SCALE	AS SHOWN
DATE	4/20/2000
DRAWN	AJR
CHECKED	JAF

DRAWING NO.

A6

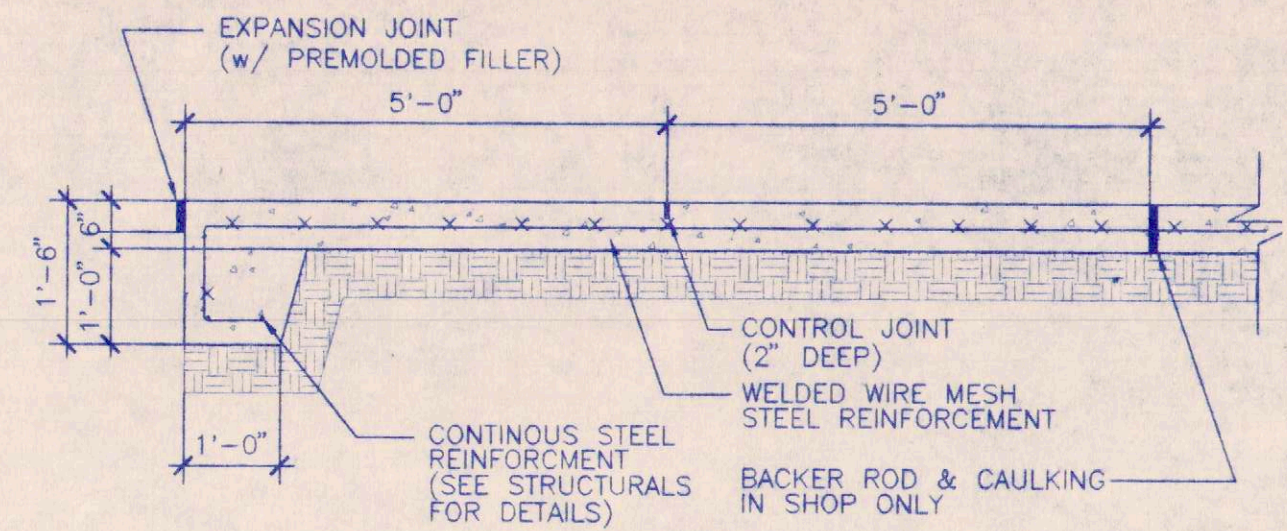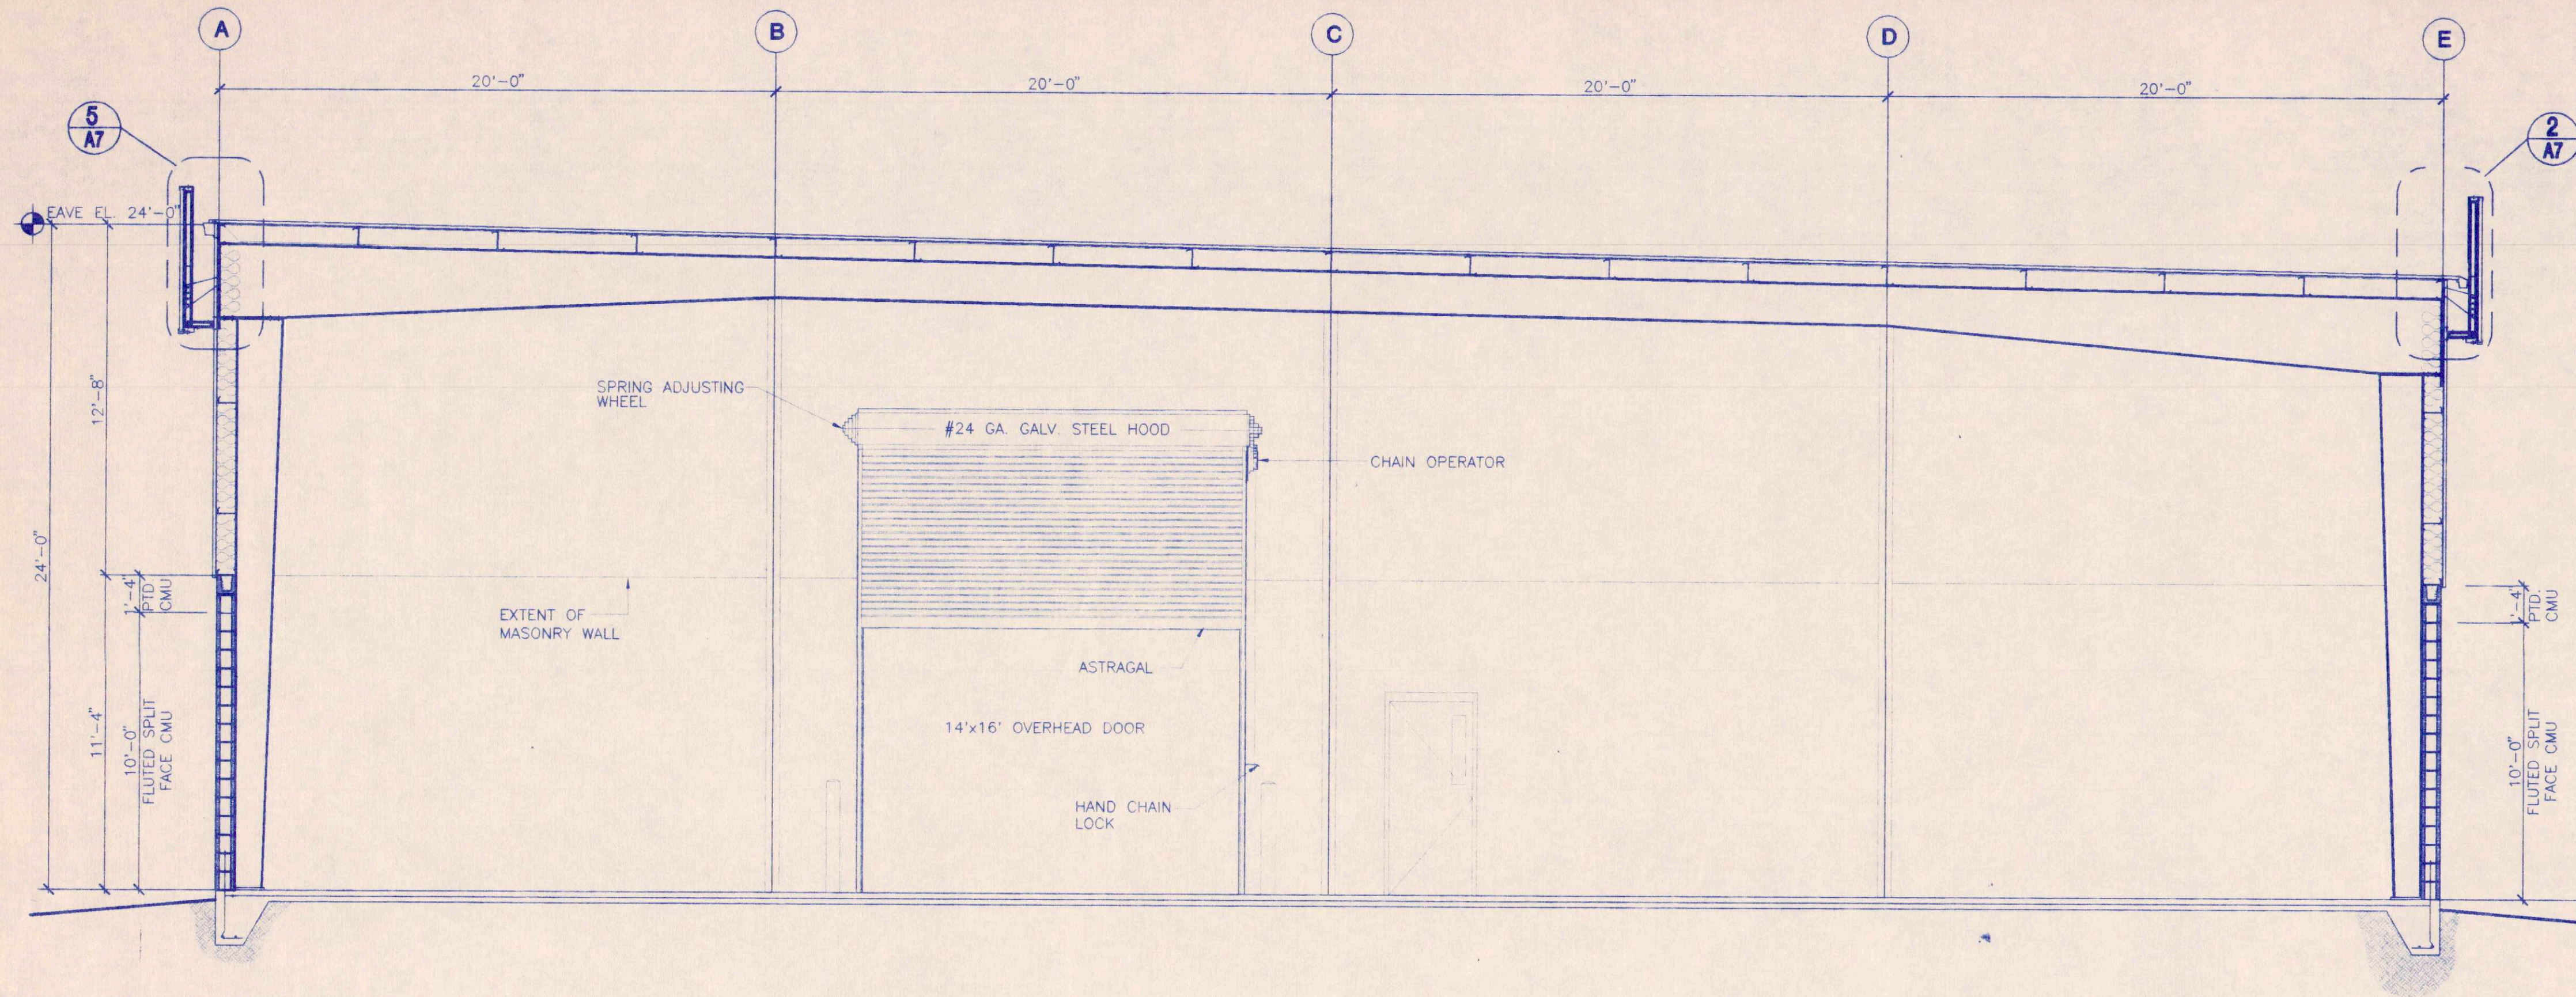


3 TYPICAL SECTION THRU CONCRETE
SCALE: 1/2" = 1'-0"

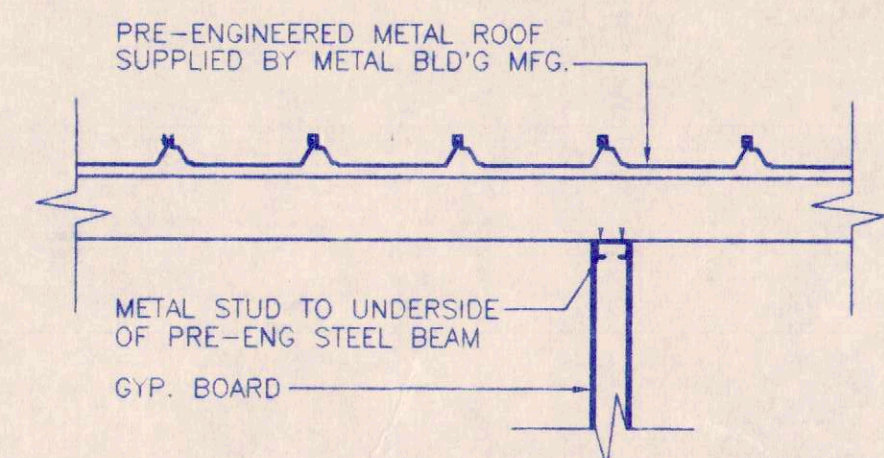

4 PARTITION SECTION DETAIL
SCALE: 1/2" = 1'-0"


1 BUILDING SECTIONS
SCALE: 1/4" = 1'-0"

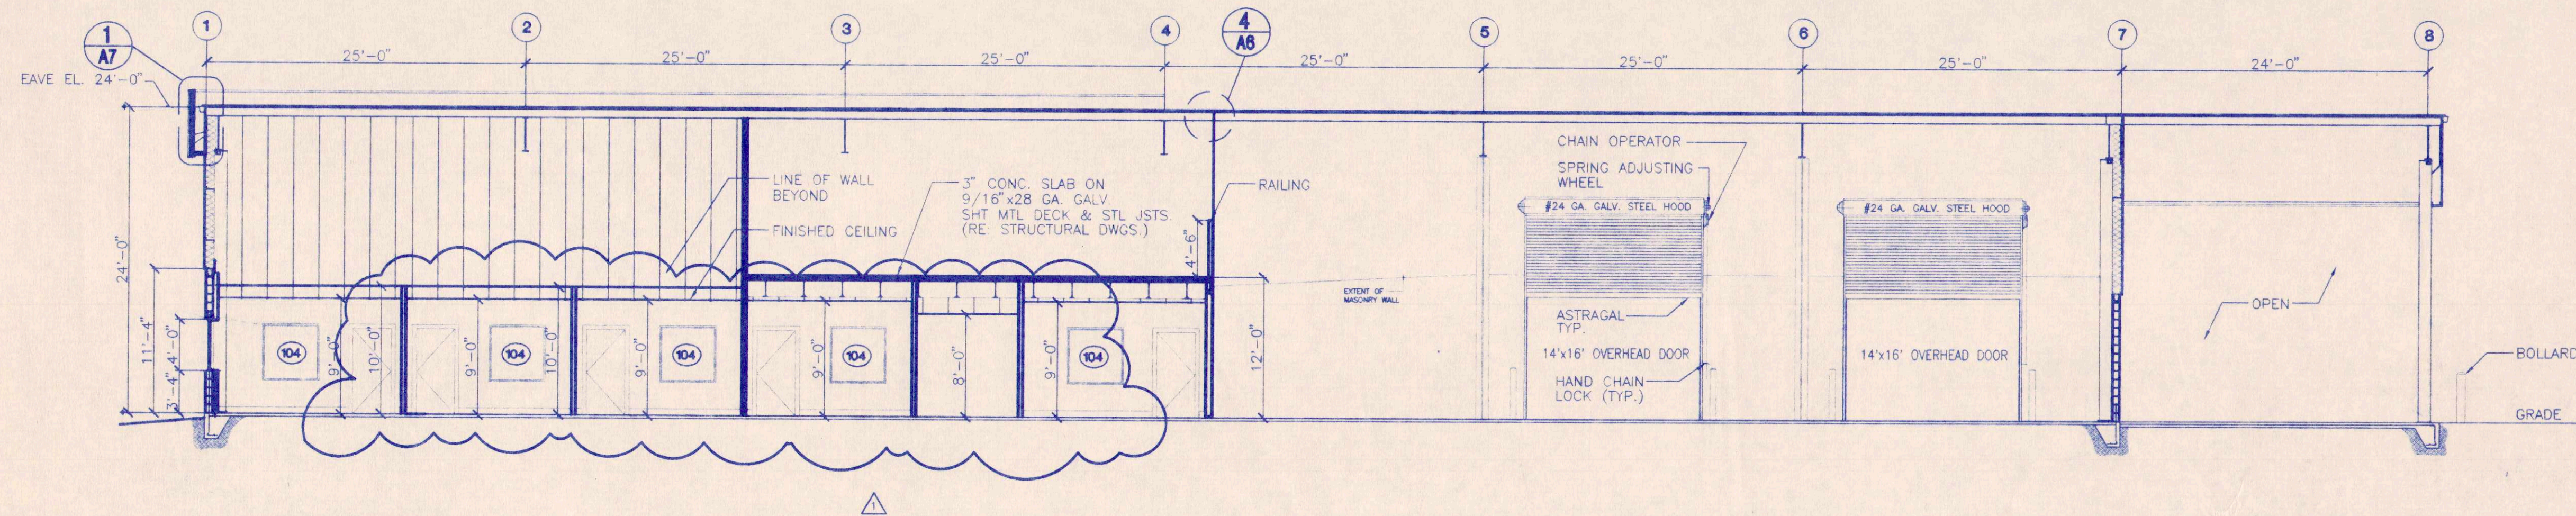

2 BUILDING CROSS SECTION
SCALE: 1/8" = 1'-0"

AS BUILT

CONSTRUCTION

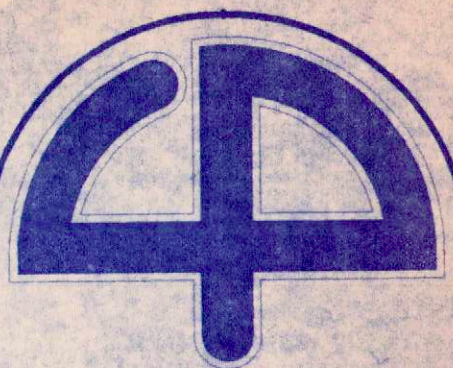

Cuhaci & Peterson
Architects

1220 Alden Road
Orlando, Florida 32803
Ph. 407 228 4220
Fax. 407 228 4219

© COPYRIGHT
All reports, plans, specifications, computer files,
field data, notes and other documents and
instruments prepared by Cuhaci & Peterson
Architects (C & P) are instruments of service
within the property of C & P. C & P
shall retain all common law, statutory and other
reserved rights, including the copyright, therein.
Any use or reproduction of any document with-
out written permission from C & P is a
violation of Federal copyright laws.

P.C.G. INC.
1000 JETSTREAM DRIVE
ORLANDO, FLORIDA

JOB TITLE


DRAWING TITLE

WALL SECTIONS
& MISC. DETAILS


REVISION	DATE	BY	CHKD
1	6/2/2000		
2			
3			
4			

JOB NO.	99228
SCALE	AS SHOWN
DATE	4/20/2000
DRAWN	AJR
CHECKED	JAF
DRAWING NO.	


A7

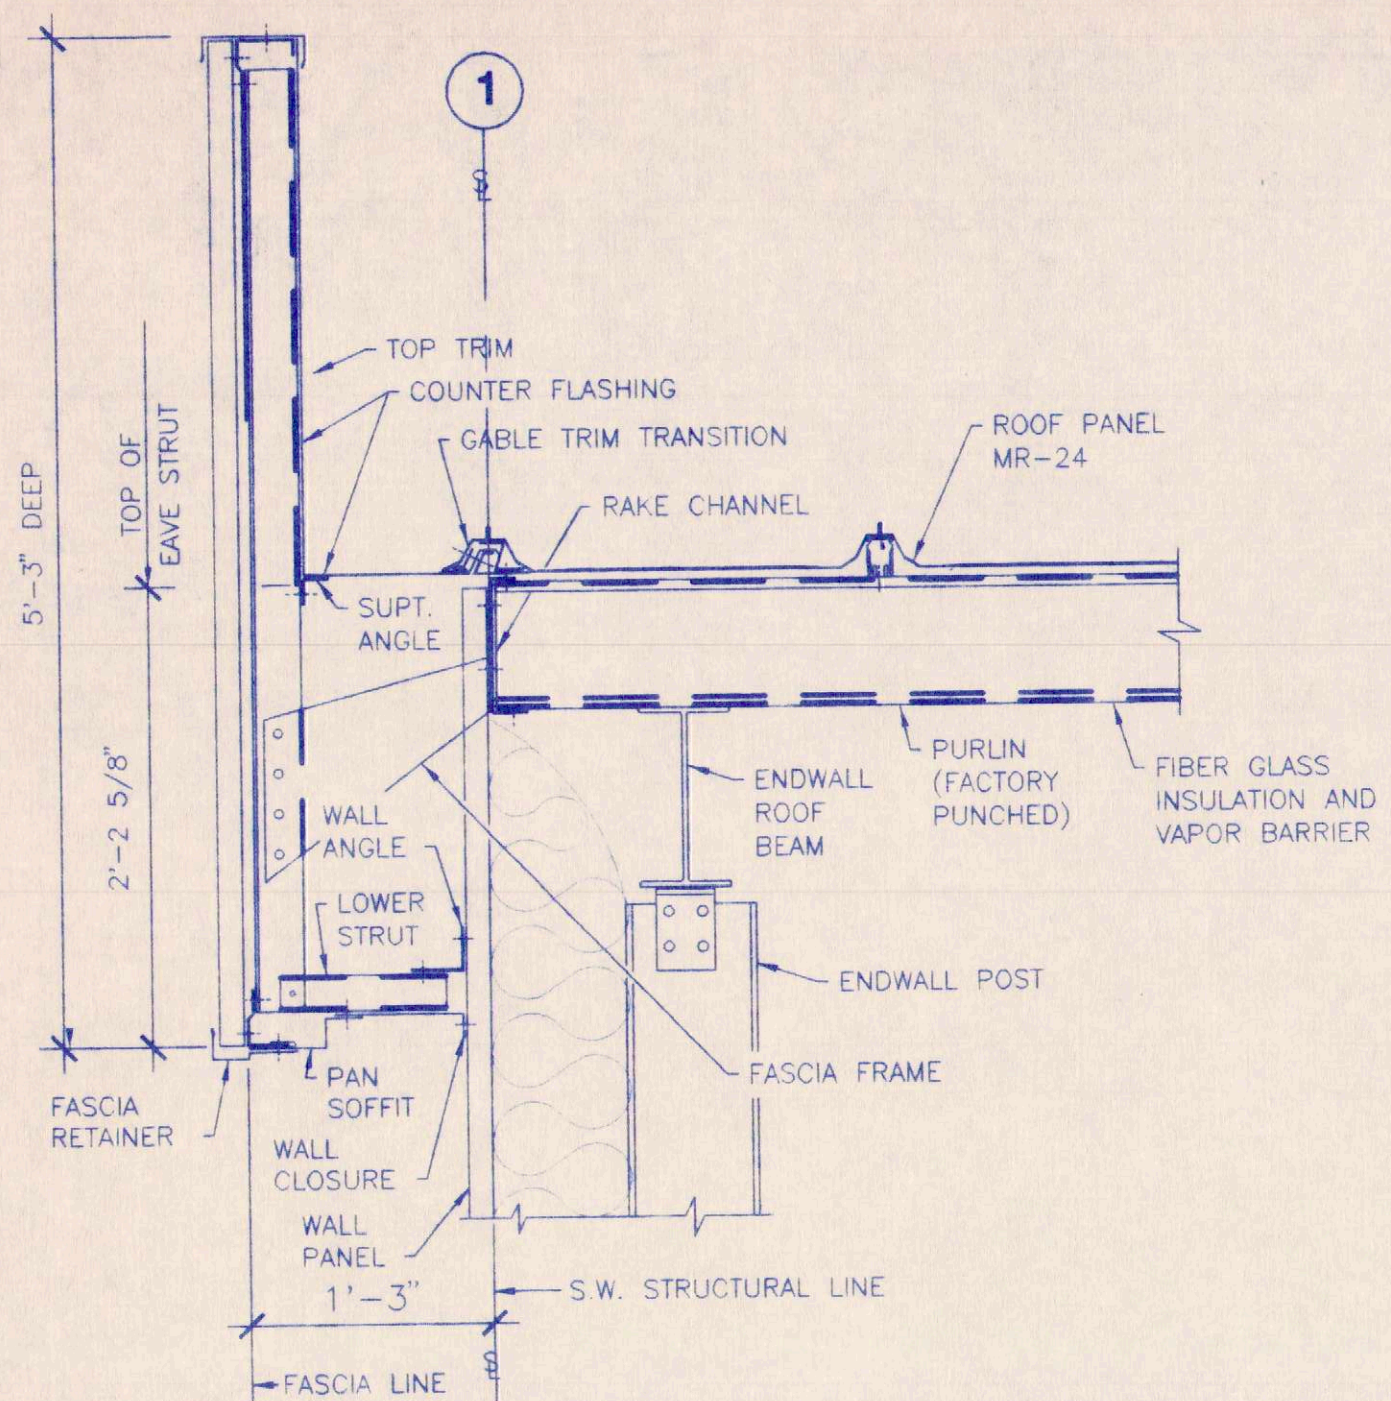


1
A7
FASCIA DETAIL @ ENDWALL
SCALE: 1" = 1'-0"

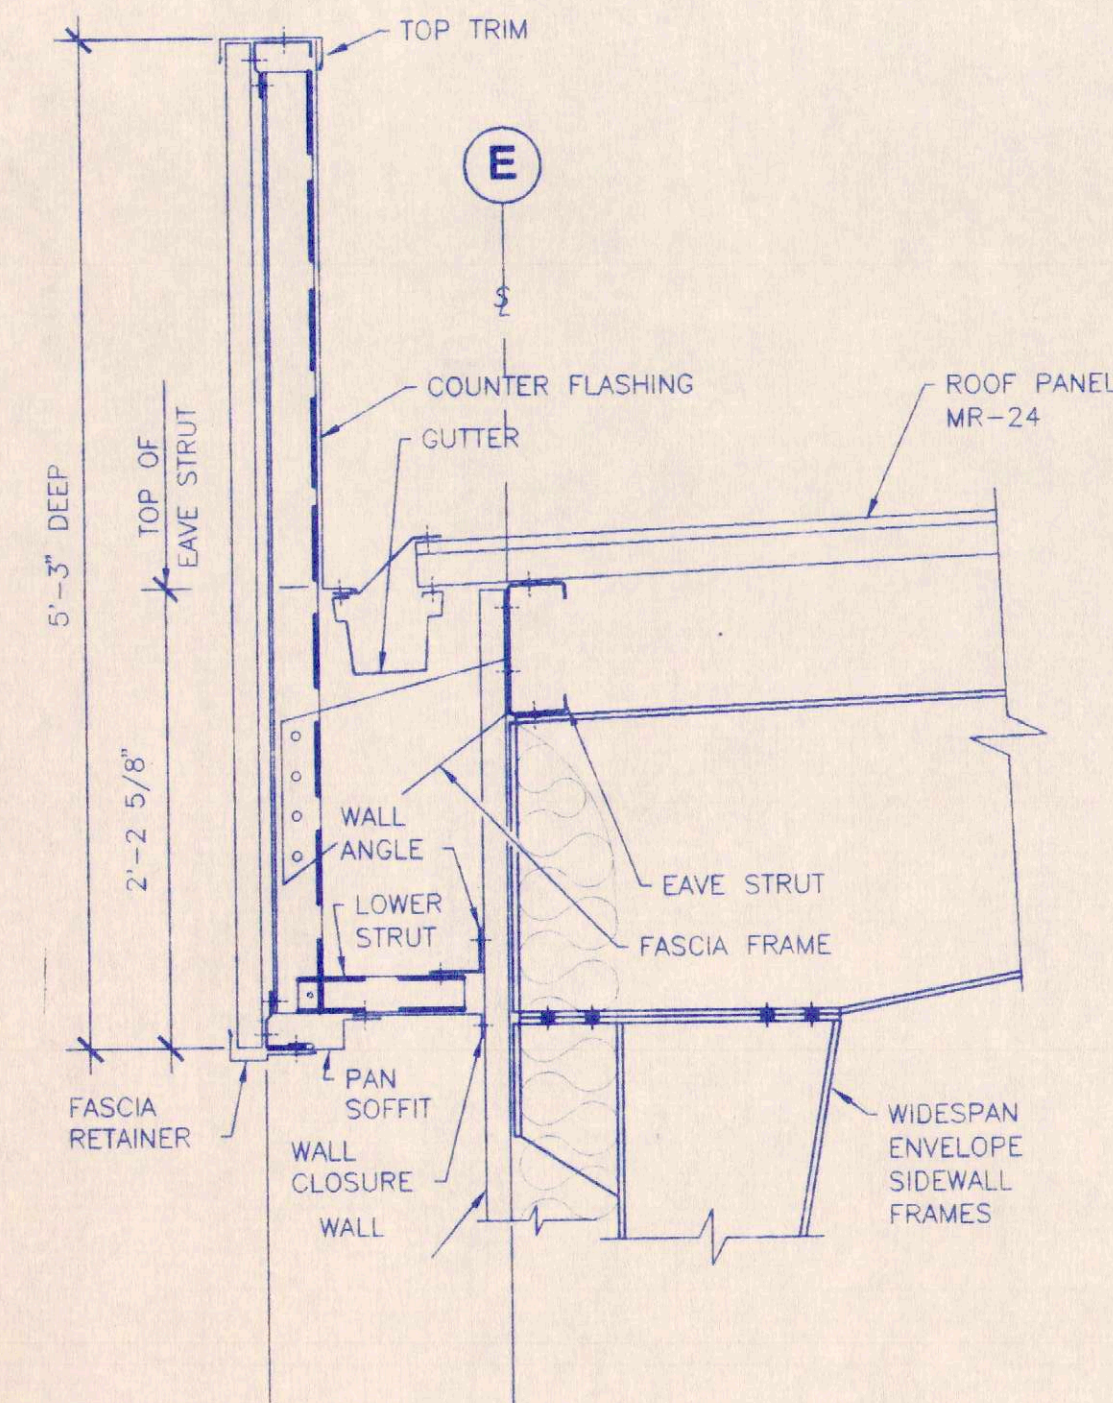


2
A7
FASCIA DETAIL @ SIDEWALL (LOW SIDE)
SCALE: 1" = 1'-0"

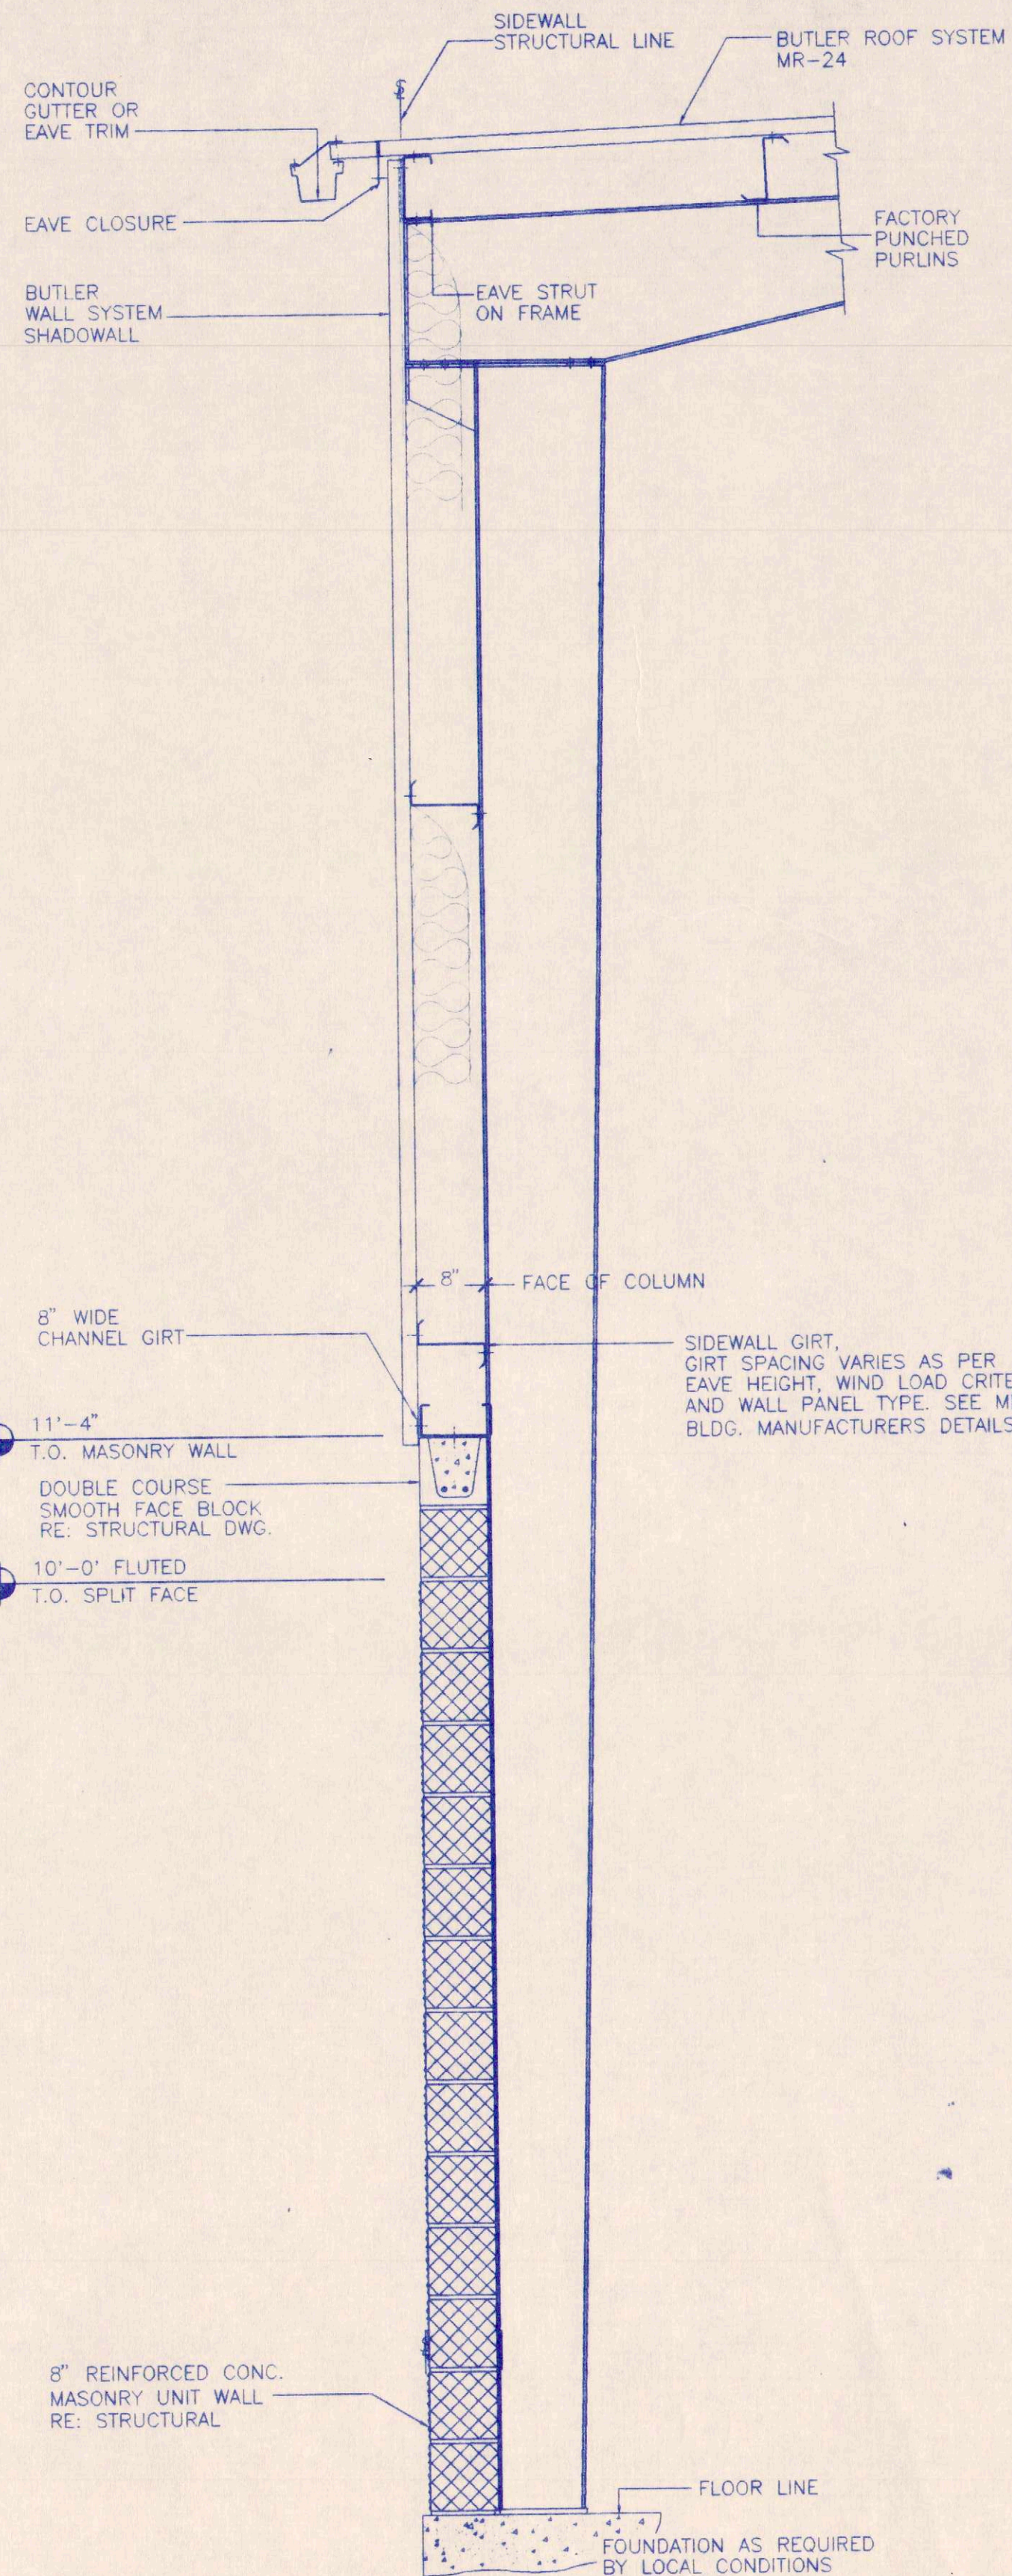

3
A7
WALL SECTION @ SIDEWALL (LOW SIDE)
SCALE: 3/4" = 1'-0"

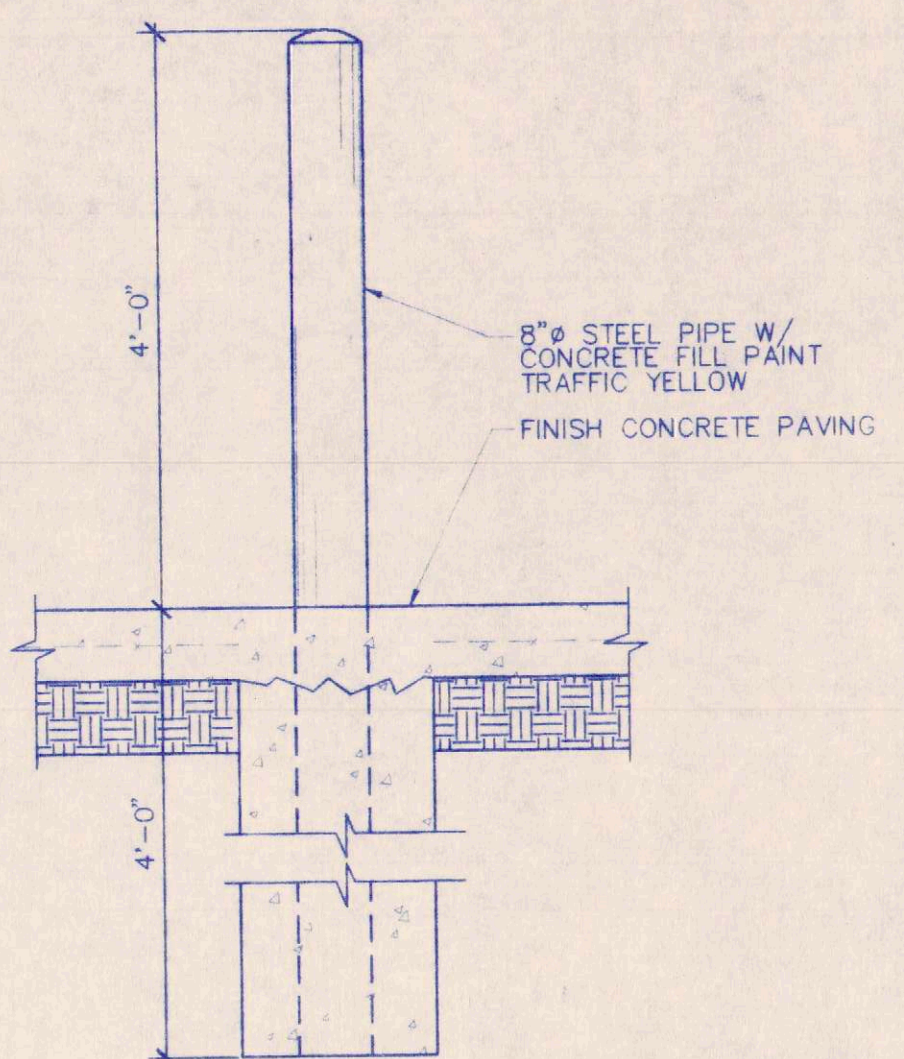


4
A7
STEEL BOLLARD DETAIL
SCALE: 3/4" = 1'-0"

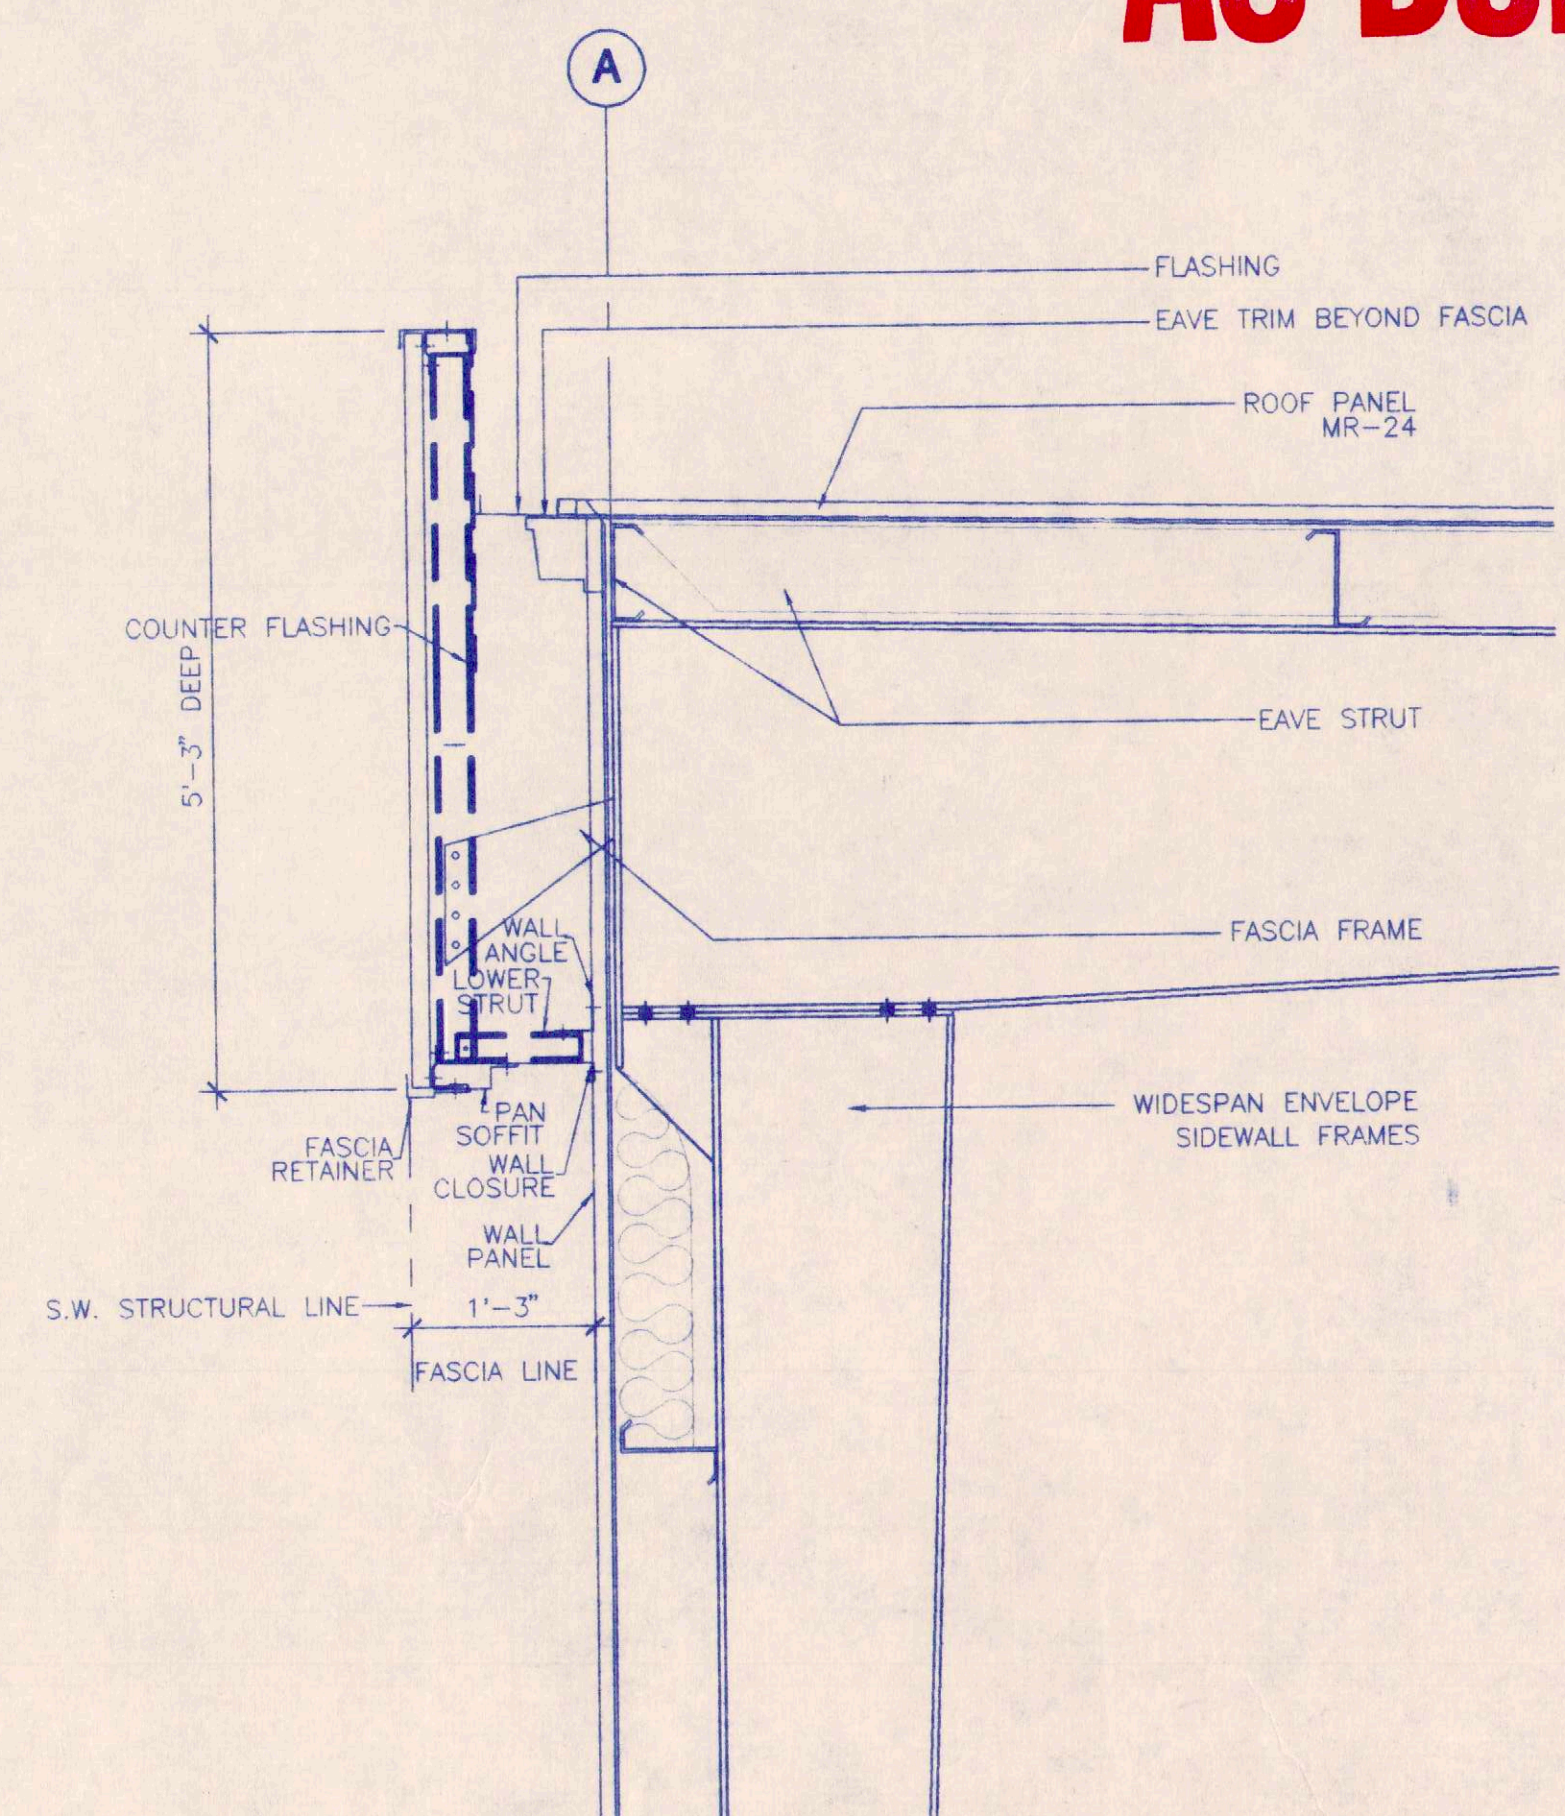

5
A7
FASCIA DETAIL @ SIDEWALL (HIGH SIDE)
SCALE: 3/4" = 1'-0"

RELEASED FOR
CONSTRUCTION

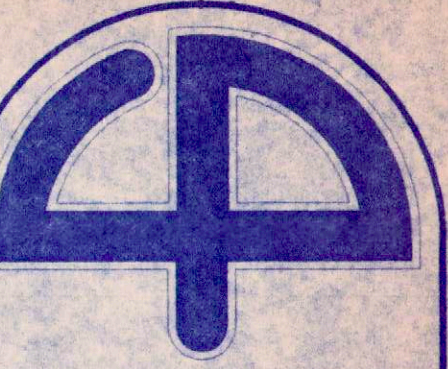


Cuhaci & Peterson
Architects

1220 Alden Road
Orlando, Florida 32803
Ph. 407 228 4220
Fax. 407 228 4219

© COPYRIGHT
All reports, plans, specifications, computer files,
field data, notes and other documents and
instruments prepared by Cuhaci & Peterson
Architects (C & P) as instruments of service
remain the property of C & P. C & P
shall retain all common law, statutory and other
reserved rights, including the copyright therein.
Any use or reproduction of this document with-
out written permission from C & P is a
violation of Federal copyright laws.

JOB TITLE
P.C.G., INC
1000 JETSTREAM DRIVE
ORLANDO, FLORIDA


DRAWING TITLE
INTERIOR ELEVATIONS
AND DETAILS

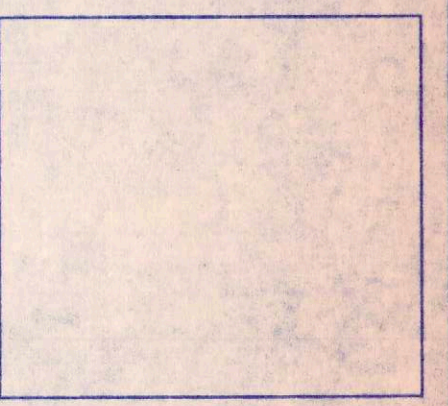


REVISION:	1
1/6/2/2000	2
1/6/5/2000	3
1/6/5/2000	4
1/6/5/2000	5

JOB NO.	99228
SCALE	AS SHOWN
DATE	4/20/2000
DRAWN	AJR
CHECKED	JAF
DRAWING NO.	


A8

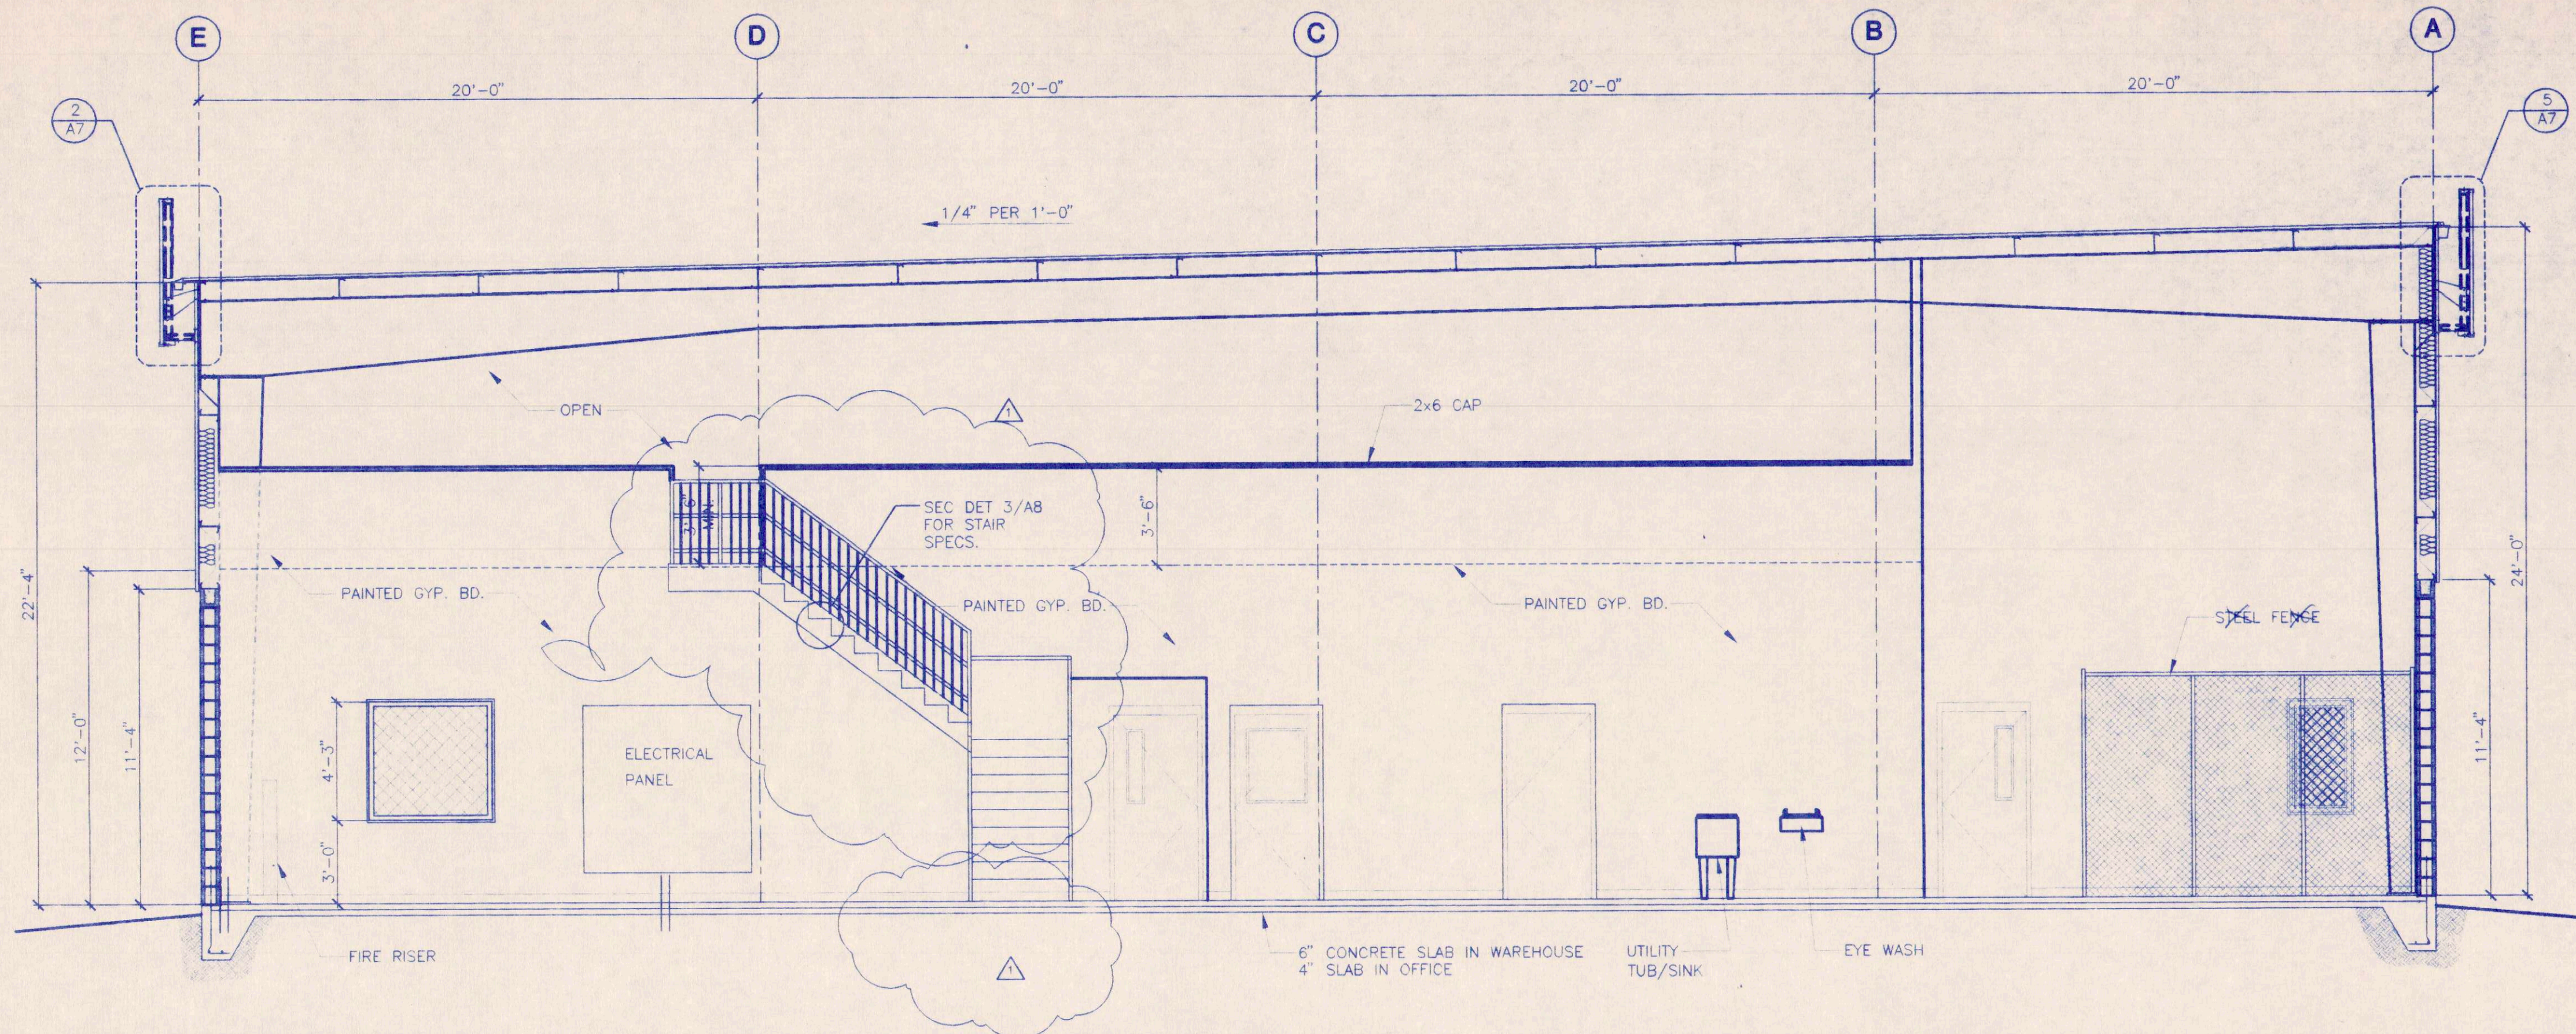


1
A8 **INTERIOR ELEVATION**
SCALE: 1/4" = 1'-0"

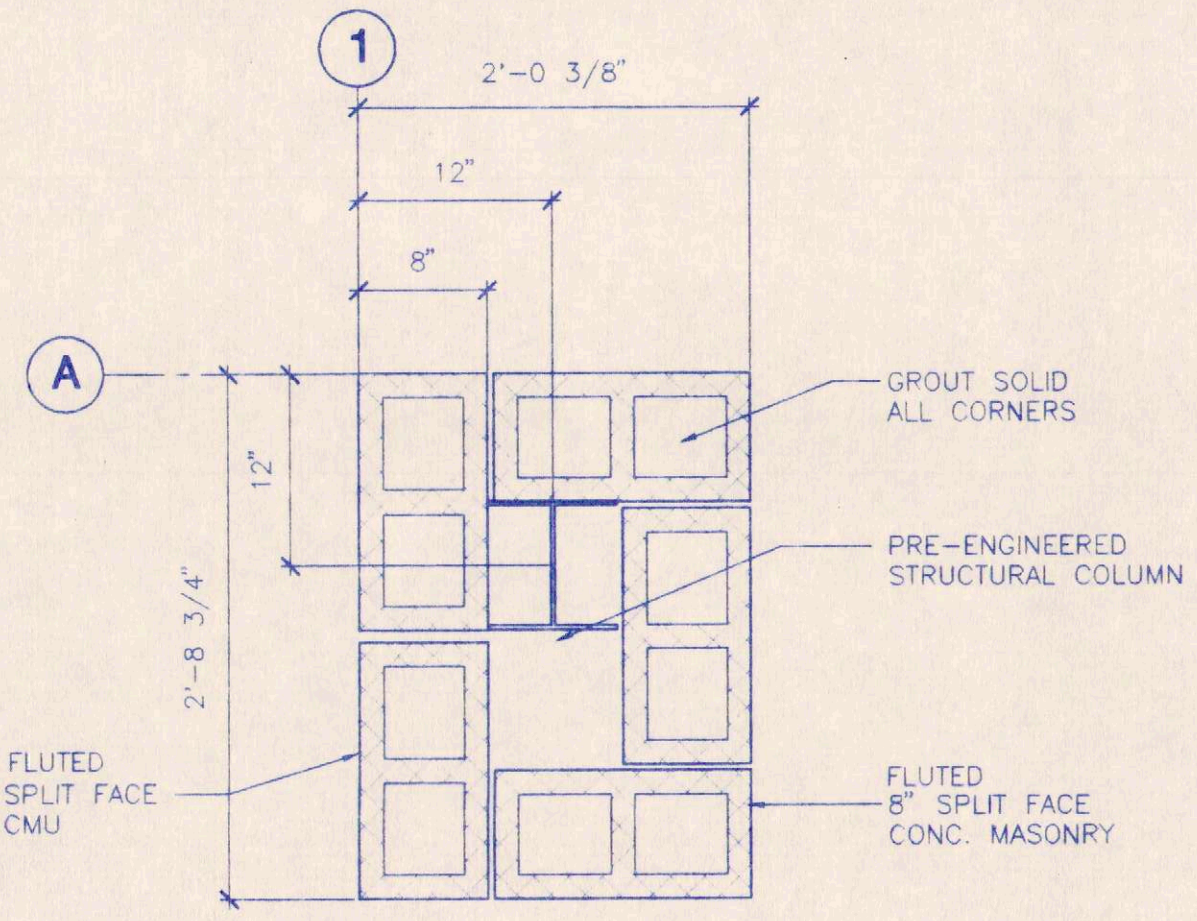

4
A8 **COLUMN DETAIL**
SCALE: 1" = 1'-0"

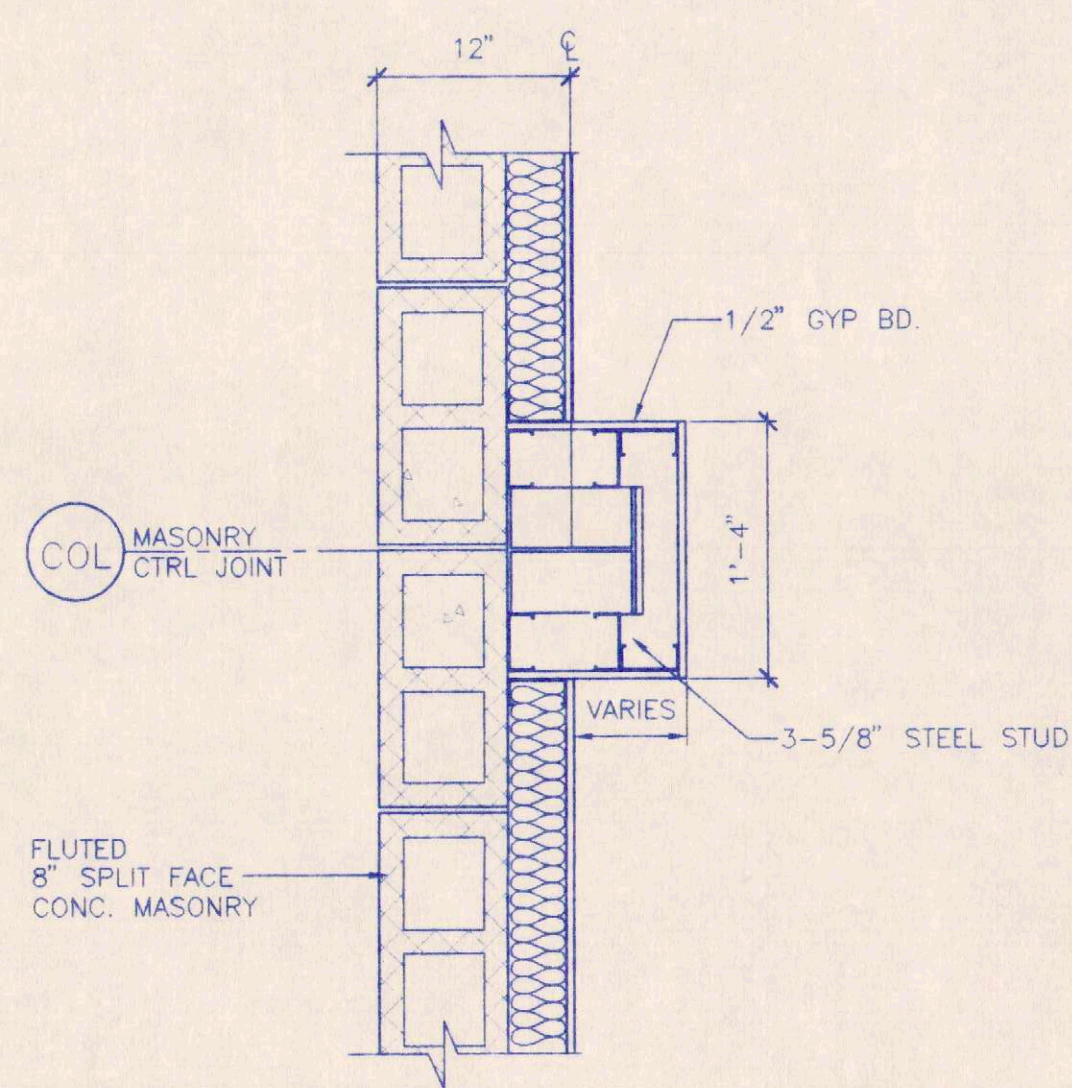


5
A8 **COLUMN DETAIL**
SCALE: 1" = 1'-0"

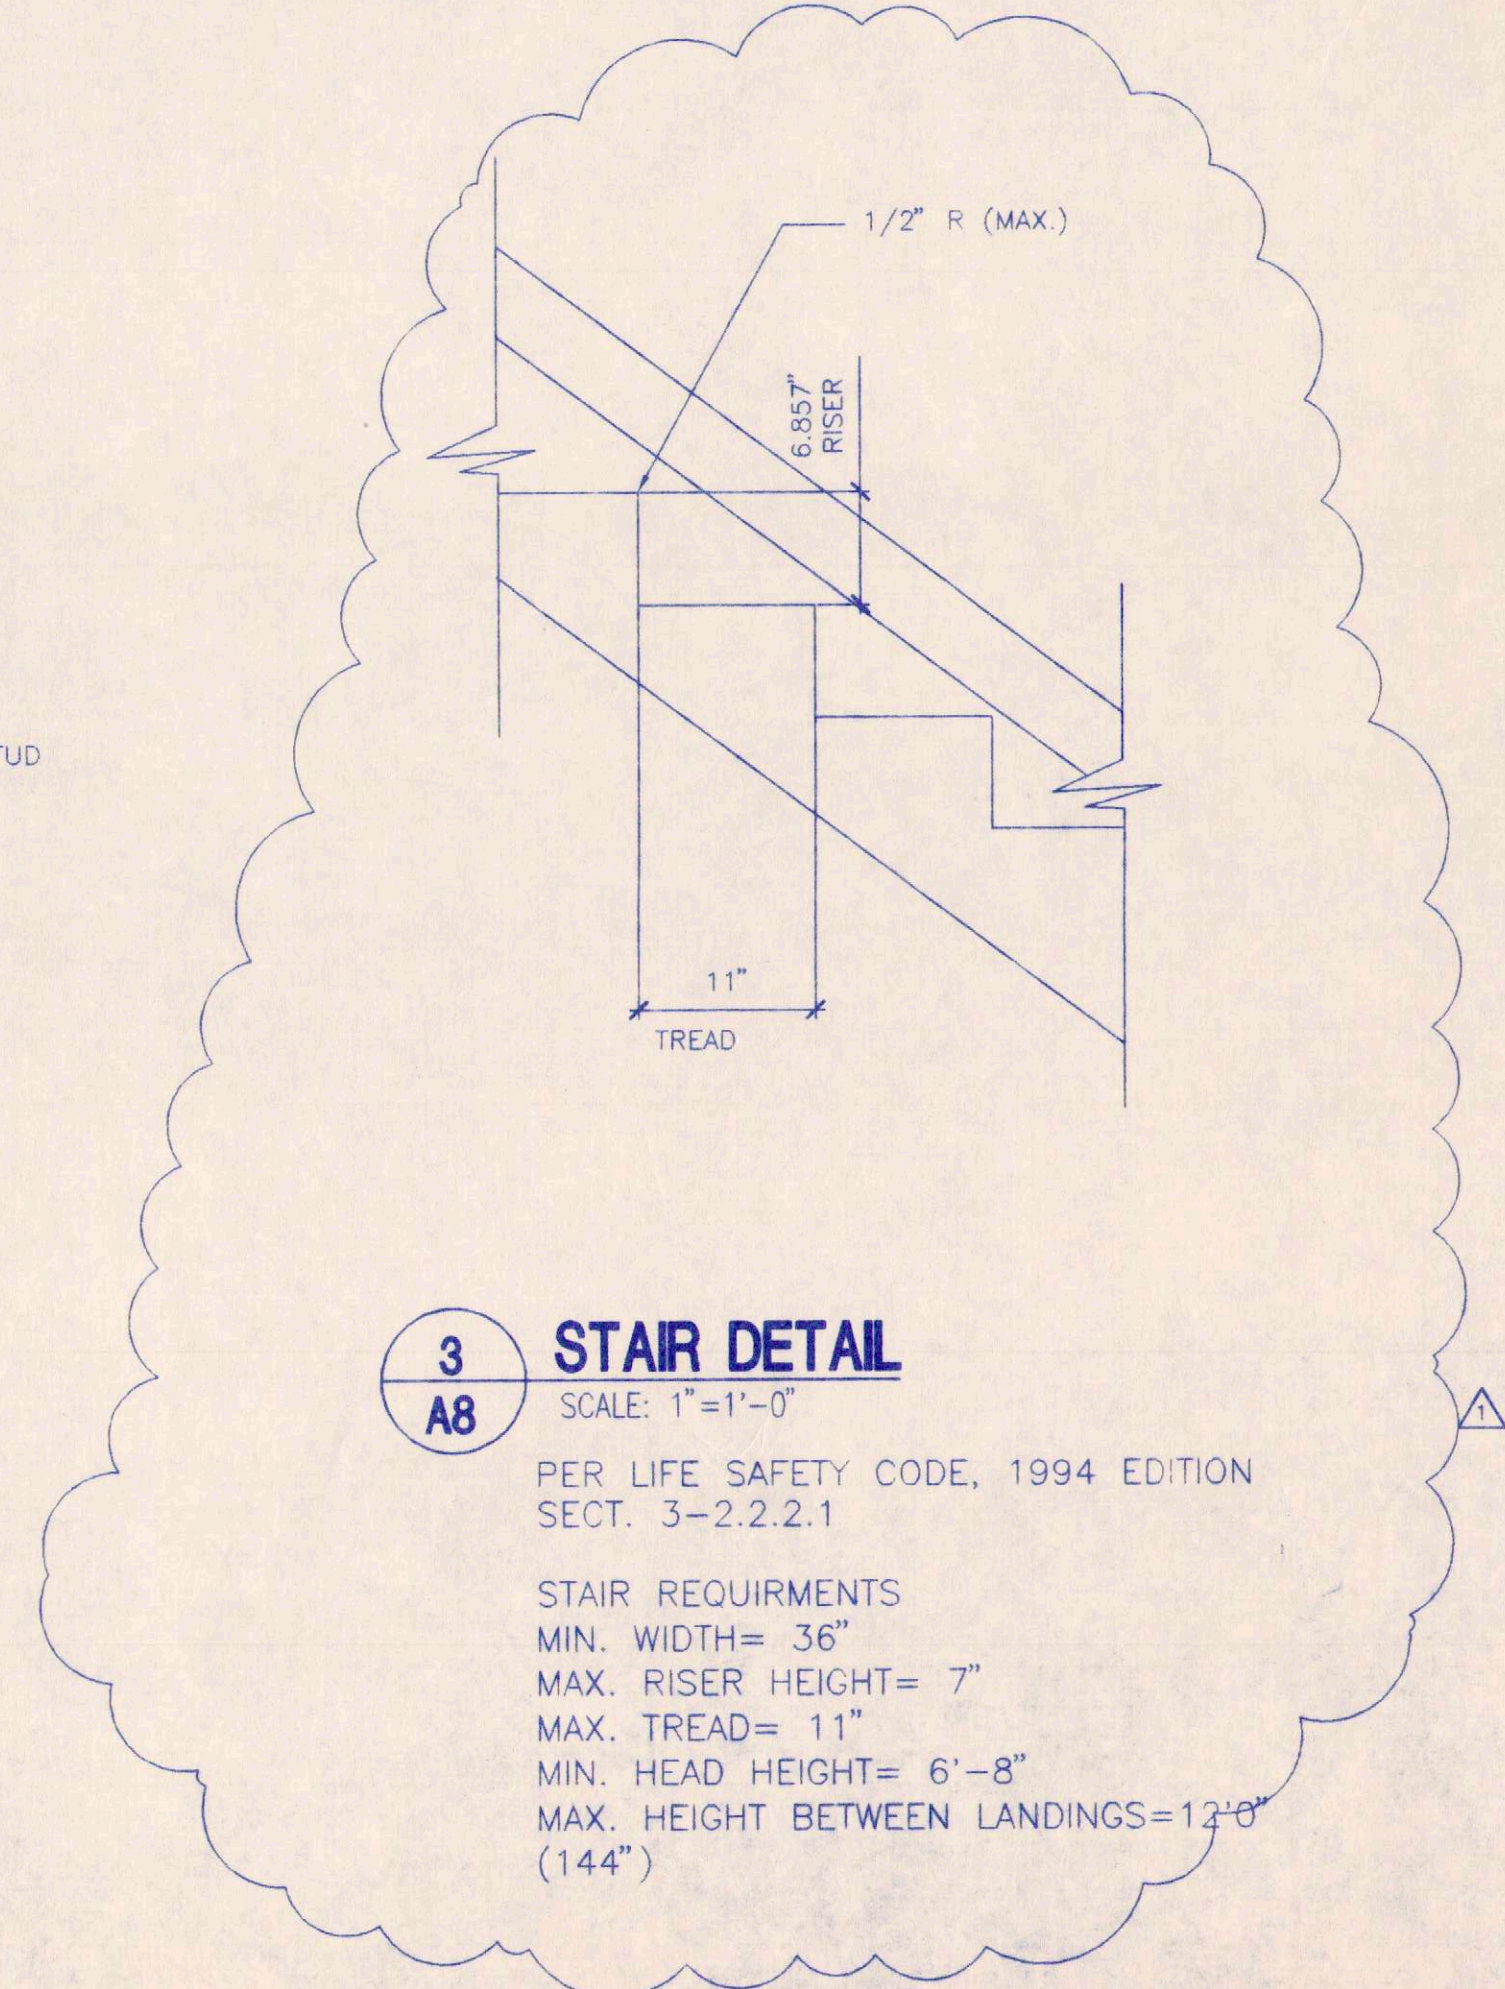

3
A8 **STAIR DETAIL**
SCALE: 1" = 1'-0"
PER LIFE SAFETY CODE, 1994 EDITION
SECT. 3-2.2.2.1
STAIR REQUIREMENTS
MIN. WIDTH= 36"
MAX. RISER HEIGHT= 7"
MAX. TREAD= 11"
MIN. HEAD HEIGHT= 6'-8"
MAX. HEIGHT BETWEEN LANDINGS=12'-0"
(144")

AS BUILT

BASED FOR
CONSTRUCTION

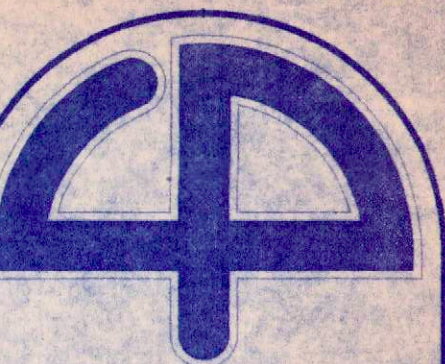

Cuhaci & Peterson
Architects

1220 Alden Road
Orlando, Florida 32803
Ph. 407 228 4220
Fax. 407 228 4219

© COPYRIGHT
All reports, plans, specifications, computer files, field data, notes and other documents and instruments prepared by Cuhaci & Peterson Architects (C & P) are instruments of service and the property of C & P. C & P shall retain all common law, statutory and other rights, including the copyright therein. Any use or reproduction of this document without written permission from C & P is a violation of Federal copyright laws.

P.C.G., INC
1000 JETSTREAM DRIVE
ORLANDO, FLORIDA

JOB TITLE

DOOR/WINDOW
FIN. SCHED'S/DETAIL

DRAWING TITLE

REVISION	1
2	3
4	5
6	7
8	9

JOB NO.	99228
SCALE	AS SHOWN
DATE	4/10/2000
DRAWN	CRW
CHECKED	JAF
DRAWING NO.	

A9

HARDWARE SETS	
NOTES: 1. PROVIDE ALL WEATHERSTRIPPING & THRESHOLDS. 2. ALL OFFICES, FILE ROOMS, STORAGE ROOMS, ENTRANCES, UTILITY ROOMS SHALL BE SECURED. 3. PROVIDE A MASTER KEY SYSTEM w/ SUB-DIVISIONS AS REQ'D	
1. ALUMINUM ENTRY 2 SCHLAGE MORTISE CYLINDER X 26D NOTE: BALANCE OF HARDWARE BY ALUMINUM DOOR SUPPLIER	6. WAREHOUSE SET 3 HAGER HINGES BB1279 4.5" X 4.5" NRP X 26D 1 SCHLAGE ALS3PD SATURN LEVER KEYLOCK X 626 1 DORMA DOOR CLOSER #7601 X ALUM. 1 PEMKO DOOR BOTTOM #217AV X 36" X ALUM. 1 PEMKO THRESHOLD #270A X 1/4" FLAT SADDLE X 17" X ALUM. 1 PEMKO WEATHERSTRIPPING #303AV X 17" X ALUM.
2. RECEPTION ROOM 3 HAGER HINGES BB1279 4.5" X 4.5" NRP X 26D 1 SCHLAGE ALS3PD SATURN LEVER KEYLOCK X 626 1 DORMA DOOR CLOSER #7601 X ALUM. 1 IVE'S WALL STOP X 26D 3 IVE'S DOOR SILENCERS #20 X GRAY	7. RESTROOMS/SHOWERS (WAREHOUSE) 3 HAGER HINGES BB1279 4.5" X 4.5" NRP X 26D 1 SCHLAGE ALS3PD SATURN LEVER KEYLOCK X 626 1 DORMA DOOR CLOSER #7601 X ALUM. 1 PEMKO DOOR BOTTOM #217AV X 36" X ALUM. 1 PEMKO THRESHOLD #270A X 1/4" FLAT SADDLE X 17" X ALUM. 1 PEMKO WEATHERSTRIPPING #303AV X 17" X ALUM.
3. PASSAGE SET 3 HAGER HINGES BB1279 4.5" X 4.5" NRP X 26D 1 SCHLAGE ALS3PD SATURN LEVER KEYLOCK X 626 1 DORMA DOOR CLOSER #7601 X ALUM. 1 IVE'S WALL STOP X 26D 3 IVE'S DOOR SILENCERS #20 X GRAY	8. EXTERIOR DOORS 3 HAGER HINGES BB1279 4.5" X 4.5" NRP X 26D 1 SCHLAGE ALS3PD SATURN LEVER KEYLOCK X 626 1 IVE'S SECURITY LATCH GUARD #180X32D (STAINLESS STEEL) 1 DORMA DOOR CLOSER #7601 X ALUM. 1 PEMKO THRESHOLD #2005AV X 36" X ALUM. 1 PEMKO DOOR BOTTOM #217AV X 36" X ALUM. 1 PEMKO WEATHERSTRIPPING #303AV X 17" X ALUM. 1 PEMKO RAIN DRIP CAP #345C X 40" X ALUM.
4. OFFICE SET 3 HAGER HINGES BB1279 4.5" X 4.5" NRP X 26D 1 SCHLAGE ALS3PD SATURN LEVER KEYLOCK X 626 1 IVE'S WALL STOP X 26D 3 IVE'S DOOR SILENCERS #20 X GRAY	9. CLOSETS NOTE: ALL HARDWARE BY DOOR SUPPLIER
5. RESTROOMS/SHOWERS (OFFICE) 3 HAGER HINGES BB1279 4.5" X 4.5" NRP X 26D 1 SCHLAGE ALS3PD SATURN LEVER KEYLOCK X 626 1 DORMA DOOR CLOSER #7601 X ALUM. 1 IVE'S WALL STOP X 26D 3 IVE'S DOOR SILENCERS #20 X GRAY	10. METAL ROLL-UP DOORS OVERHEAD DOOR COMPANY OF ORLANDO SERIES 600 DOOR - ORANGE COUNTY APPROVED AND MASTERFILED



GENERAL NOTES:

- HEAD & JAMB: #12 TEK SCREW BE PLACED ON EACH SIDE OF EACH VERTICAL AND ANCHOR W/SAME AT 16" O.C.



KEYED NOTES

- | | | | |
|---|---|---|---|
| 1 | 3 5/8" ST20 METAL STUD FRAMING | 7 | BI-FOLD DOOR TRACK |
| 2 | 1/2" GYP. WALL BD | 8 | PREFINISHED ALUM. STOREFRONT |
| 3 | METAL FRAME SET ANCHORS PER MANUFACTURERS RECOMMENDATIONS | 9 | EXTERIOR GLAZING SEALANT-COLOR TO MATCH FRAME |
| 4 | INTERIOR PAINTABLE CAULK | | |
| 5 | VERTICAL DOUBLE STEEL STUD. | | |
| 6 | EXT. FLASHING TO MATCH STOREFRONT | | |




WINDOW SCHEDULE					
CLEAR ANODIZED FINISH FOR INTERIOR WINDOWS "VISTAWALL" OR APPROVED EQUAL - BLACK ANODIZED FINISH FOR EXTERIOR WINDOWS & DOORS.					
WINDOW #	FRAME SIZE	MATERIAL	FINISH	REMARKS	GLAZING
101	8'-0" X 4'-0" X 1 1/4"	ALUM.	PRE-FINISHED	SLIDER w/ RUBBER STOPS	1/4" SAFETY CLEAR
102	4'-0" X 4'-0" X 1 1/4"	ALUM.	PRE-FINISHED	INTERNAL COLONIAL MUNTINS IN ALUM. STOREFRONT	1" INSULATED TINTED GLASS
103	2'-4" X 4'-0" X 1 1/4"	ALUM.	PRE-FINISHED	SLIDER w/ RUBBER STOPS	1/4" SAFETY CLEAR
104	4'-3" X 4'-0" X 1 1/4"	ALUM.	PRE-FINISHED	SINGLE PANE	1/4" WIRE GLASS
105	4'-3" X 4'-0" X 1 1/4"	ALUM.	PRE-FINISHED	SINGLE PANE w/ WIRE MESH	1/4" WIRE GLASS

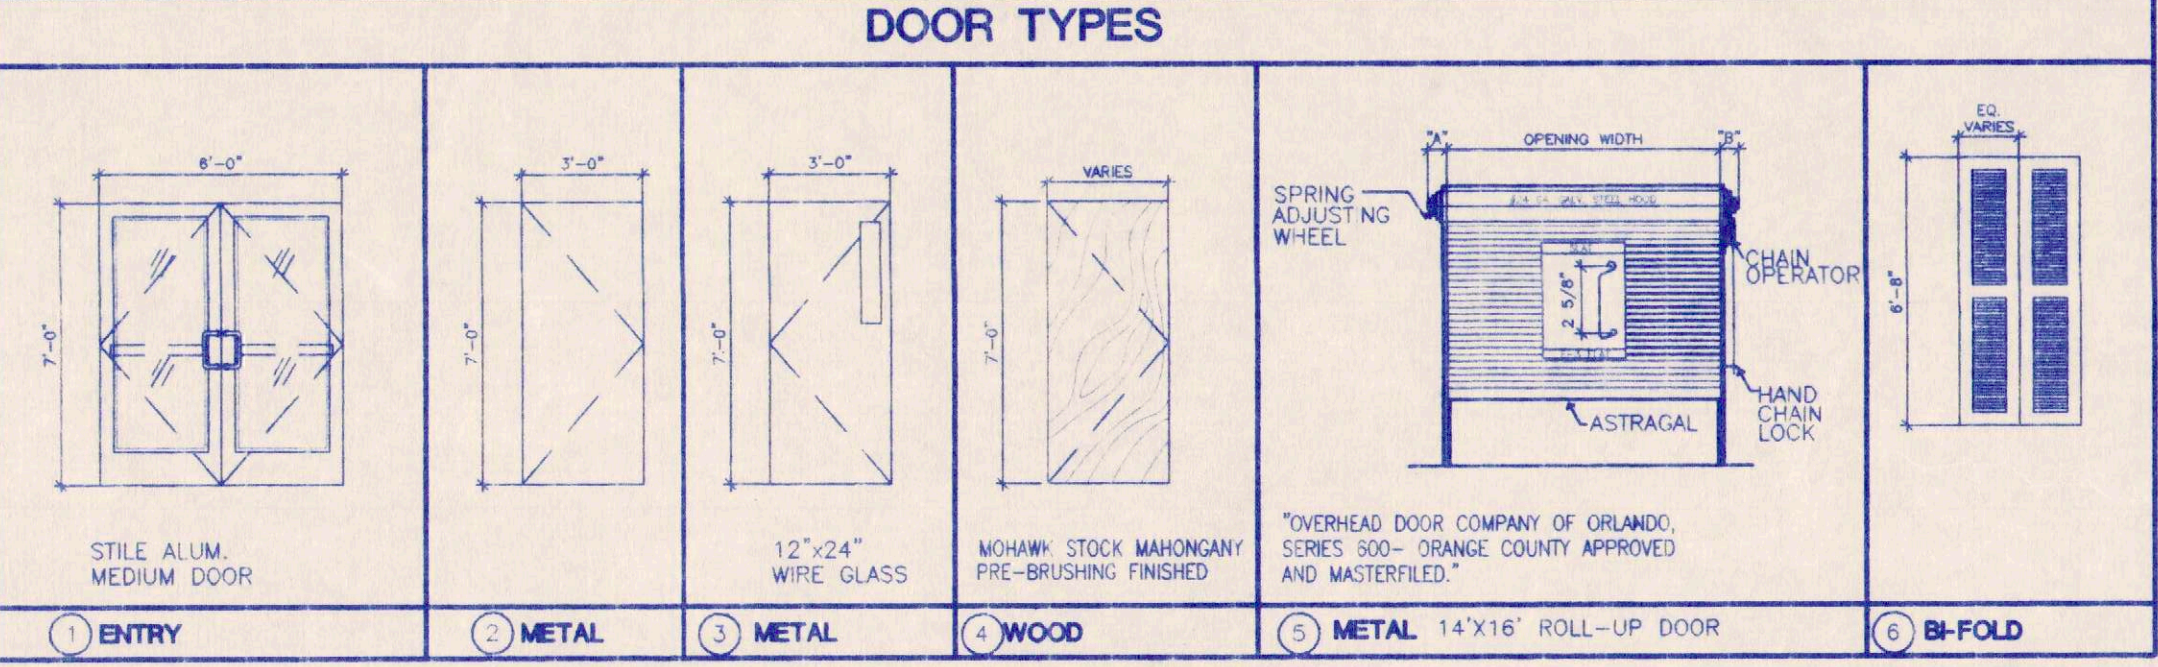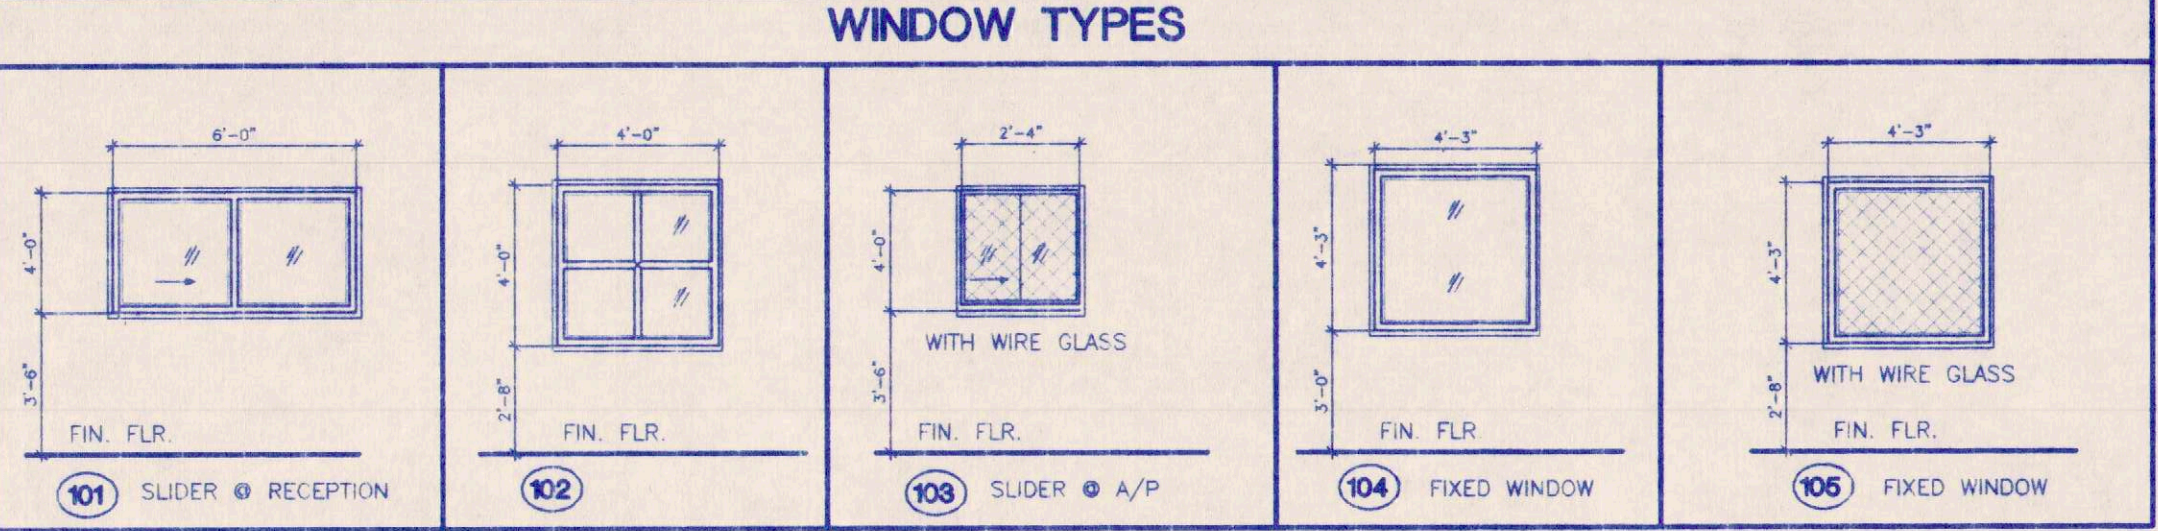


DOOR SCHEDULE											
DOOR#	DOOR TYPE	DOOR SIZE	MATERIAL	FINISH	HOWE	REMARKS	FRAME TYPE	FRAME MATERIAL	FINISH	REMARKS	
10	1	3'-0" 7'-0" (PR)	ALUM.	PRE-FINISHED	1	TRANSOM	A	ALUM.	PRE-FINISHED	BLACK ANODIZED FINISH	
11	4	3'-0" 7'-0" X 1 3/4"	S.C. WOOD	PRE-FINISHED	2		B	METAL	PAINT	ELECTRONIC LOCK	
12	4	3'-0" 7'-0" X 1 3/4"	S.C. WOOD	PRE-FINISHED	4		B	METAL	PAINT		
13	4	3'-0" 7'-0" X 1 3/4"	S.C. WOOD	PRE-FINISHED	3	8"x30" VISION CLEAR TEMPERED	B	METAL	PAINT		
14	4	3'-0" 7'-0" X 1 3/4"	S.C. WOOD	PRE-FINISHED	4		B	METAL	PAINT		
15	4	3'-0" 7'-0" X 1 3/4"	S.C. WOOD	PRE-FINISHED	4		B	METAL	PAINT		
16	4	3'-0" 7'-0" X 1 3/4"	S.C. WOOD	PRE-FINISHED	4		B	METAL	PAINT		
17	4	3'-0" 7'-0" X 1 3/4"	S.C. WOOD	PRE-FINISHED	4		B	METAL	PAINT		
18	4	3'-0" 7'-0" X 1 3/4"	S.C. WOOD	PRE-FINISHED	4		B	METAL	PAINT		
19	4	3'-0" 7'-0" X 1 3/4"	S.C. WOOD	PRE-FINISHED	4		B	METAL	PAINT		
20	4	3'-0" 7'-0" X 1 3/4"	S.C. WOOD	PRE-FINISHED	4		B	METAL	PAINT		
21	4	2'-8" 7'-0" X 1 3/4"	S.C. WOOD	PRE-FINISHED	4		B	METAL	PAINT		
22	3	3'-0" 7'-0" X 1 3/4"	H/METAL	PRE-PRIMED	8	6"x30" VISION	C	METAL	PAINT	WITH 4" HEAD	
23	4	3'-0" 7'-0" X 1 3/4"	S.C. WOOD	PRE-FINISHED	4		B	METAL	PAINT		
24	4	3'-0" 7'-0" X 1 3/4"	S.C. WOOD	PRE-FINISHED	4		B	METAL	PAINT		
25	3 SIM	3'-0" 7'-0" X 1 3/4"	H/METAL	PRE-PRIMED	6	24"x30" VISION	B	METAL	PAINT		
26	2	3'-0" 7'-0" X 1 3/4"	H/METAL	PRE-PRIMED	6	6"x30" VISION	B	METAL	PAINT		
27	2	3'-0" 7'-0" X 1 3/4"	H/METAL	PRE-PRIMED	7		B	METAL	PAINT		
28	2	3'-0" 7'-0" X 1 3/4"	H/METAL	PRE-PRIMED	7		B	METAL	PAINT		
29	3	3'-0" 7'-0"	H/METAL	PRE-PRIMED	6	6"x30" VISION	B	METAL	PAINT		
30	3	3'-0" 7'-0"	H/METAL	PRE-PRIMED	8	6"x30" VISION	C	METAL	PAINT	WITH 4" HEAD	
31	4	3'-0" 7'-0" X 1 3/4"	S.C. WOOD	PRE-FINISHED	4		B	METAL	PAINT		
32	4	3'-0" 7'-0" X 1 3/4"	S.C. WOOD	PRE-FINISHED	4		B	METAL	PAINT		
33	4	3'-0" 7'-0" X 1 3/4"	S.C. WOOD	PRE-FINISHED	4		B	METAL	PAINT		
34	4	3'-0" 7'-0" X 1 3/4"	S.C. WOOD	PRE-FINISHED	3	8"x30" VISION CLEAR TEMPERED	B	METAL	PAINT		
35	4	3'-0" 7'-0" X 1 3/4"	S.C. WOOD	PRE-FINISHED	3	8"x30" VISION W/ WIRE GLASS	B	METAL	PAINT		
36	4	3'-0" 7'-0" X 1 3/4"	S.C. WOOD	PRE-FINISHED	4		B	METAL	PAINT		
37	4	3'-0" 7'-0" X 1 3/4"	S.C. WOOD	PRE-FINISHED	4		B	METAL	PAINT		
38	4	3'-0" 7'-0" X 1 3/4"	S.C. WOOD	PRE-FINISHED	4		B	METAL	PAINT		
39	4	3'-0" 7'-0" X 1 3/4"	S.C. WOOD	PRE-FINISHED	5		B	METAL	PAINT		
40	4	3'-0" 7'-0" X 1 3/4"	S.C. WOOD	PRE-FINISHED	5		B	METAL	PAINT		
41	4	3'-0" 7'-0" X 1 3/4"	S.C. WOOD	PRE-FINISHED	5		B	METAL	PAINT		
42	2	3'-0" 7'-0" X 1 3/4"	H/METAL	PRE-PRIMED	7		B	METAL	PAINT		
43	5	14'-0" 16'-0"	ROLL-UP	PRE-PRIMED	10		-	METAL	PAINT		
44	3	3'-0" 7'-0" X 1 3/4"	H/METAL	PRE-PRIMED	8	6"x30" VISION	C	METAL	PAINT	WITH 4" HEAD	
45	6	4'-0" 6'-8" BI-FOLD	S.C. WOOD	PAINT	9	PROVIDE PULLS	-	GWB	PAINT	W/ LOUVERS/DETAIL 2/5 THIS	

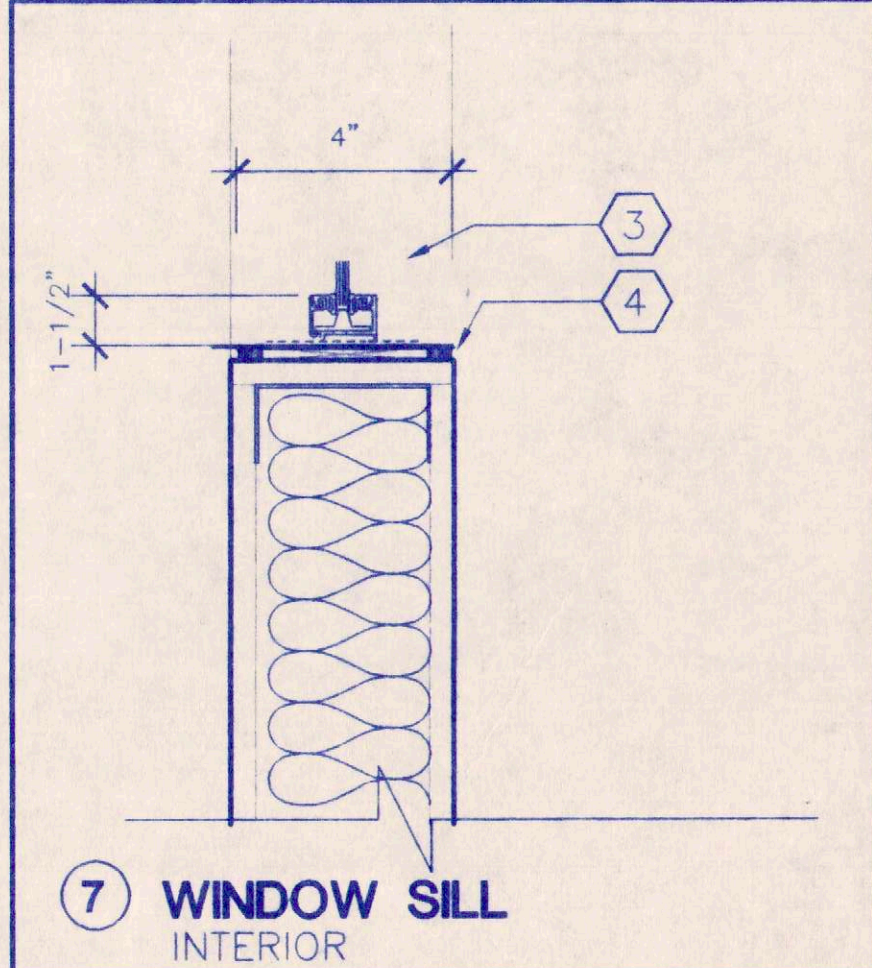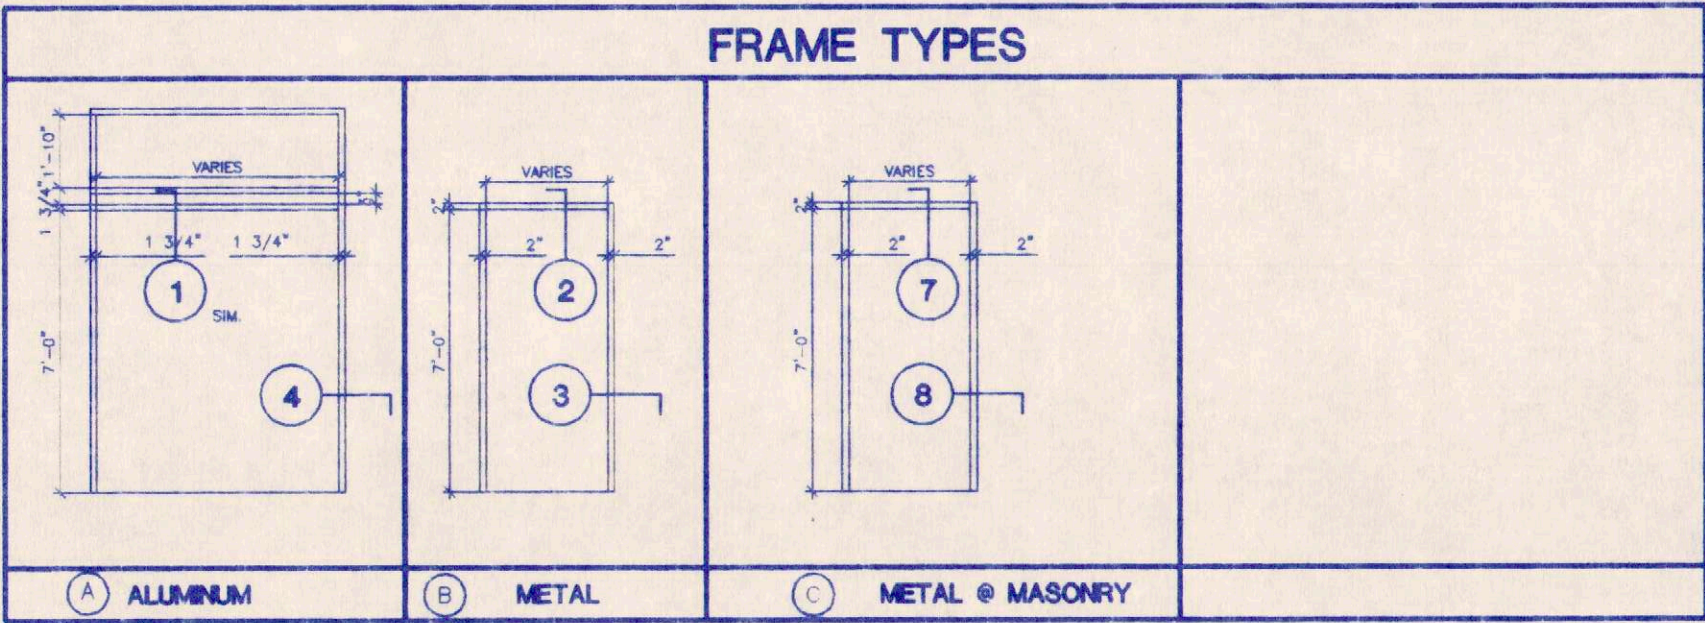

AS BUILT

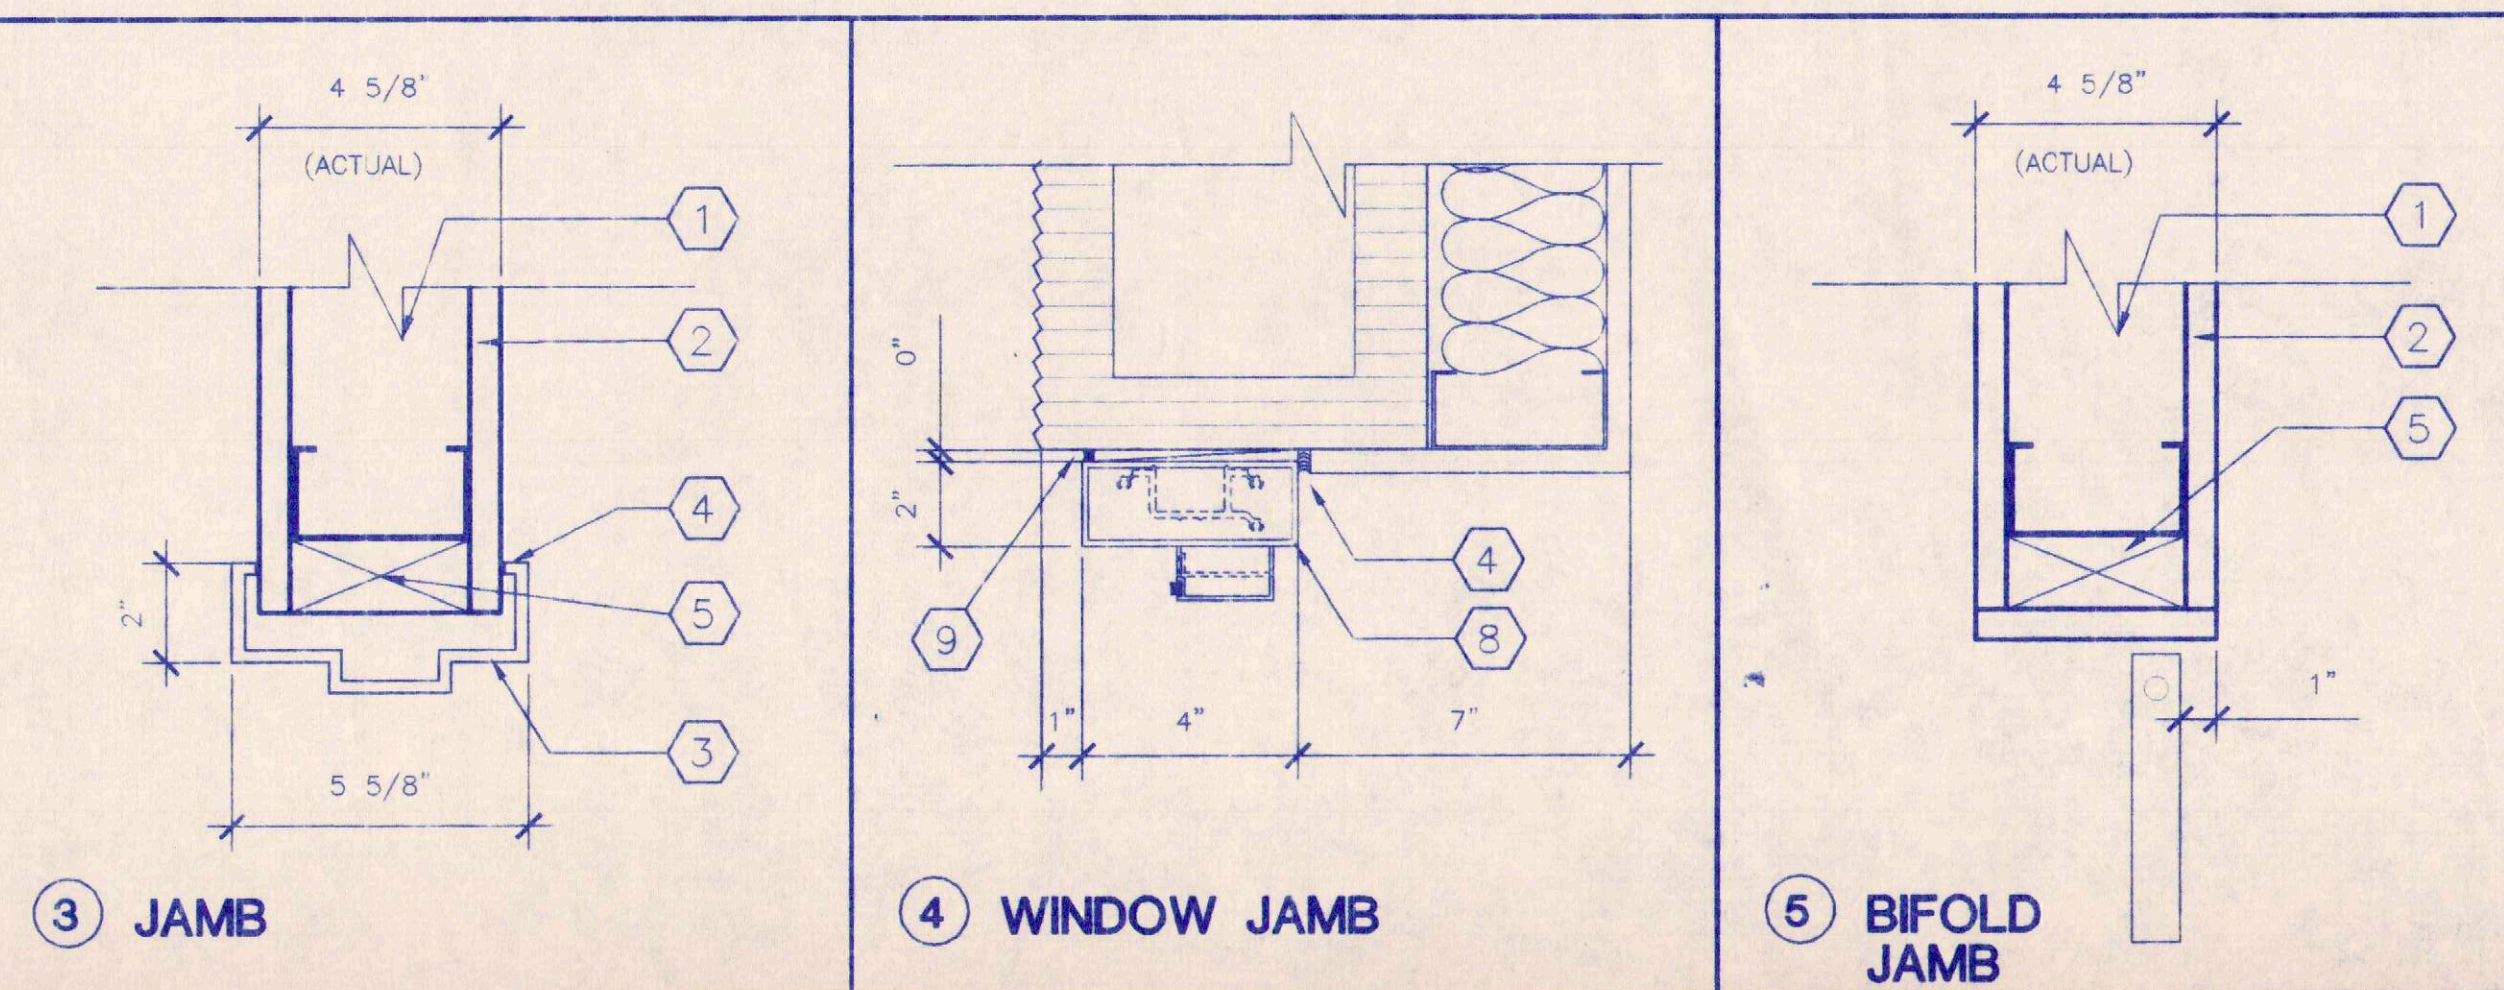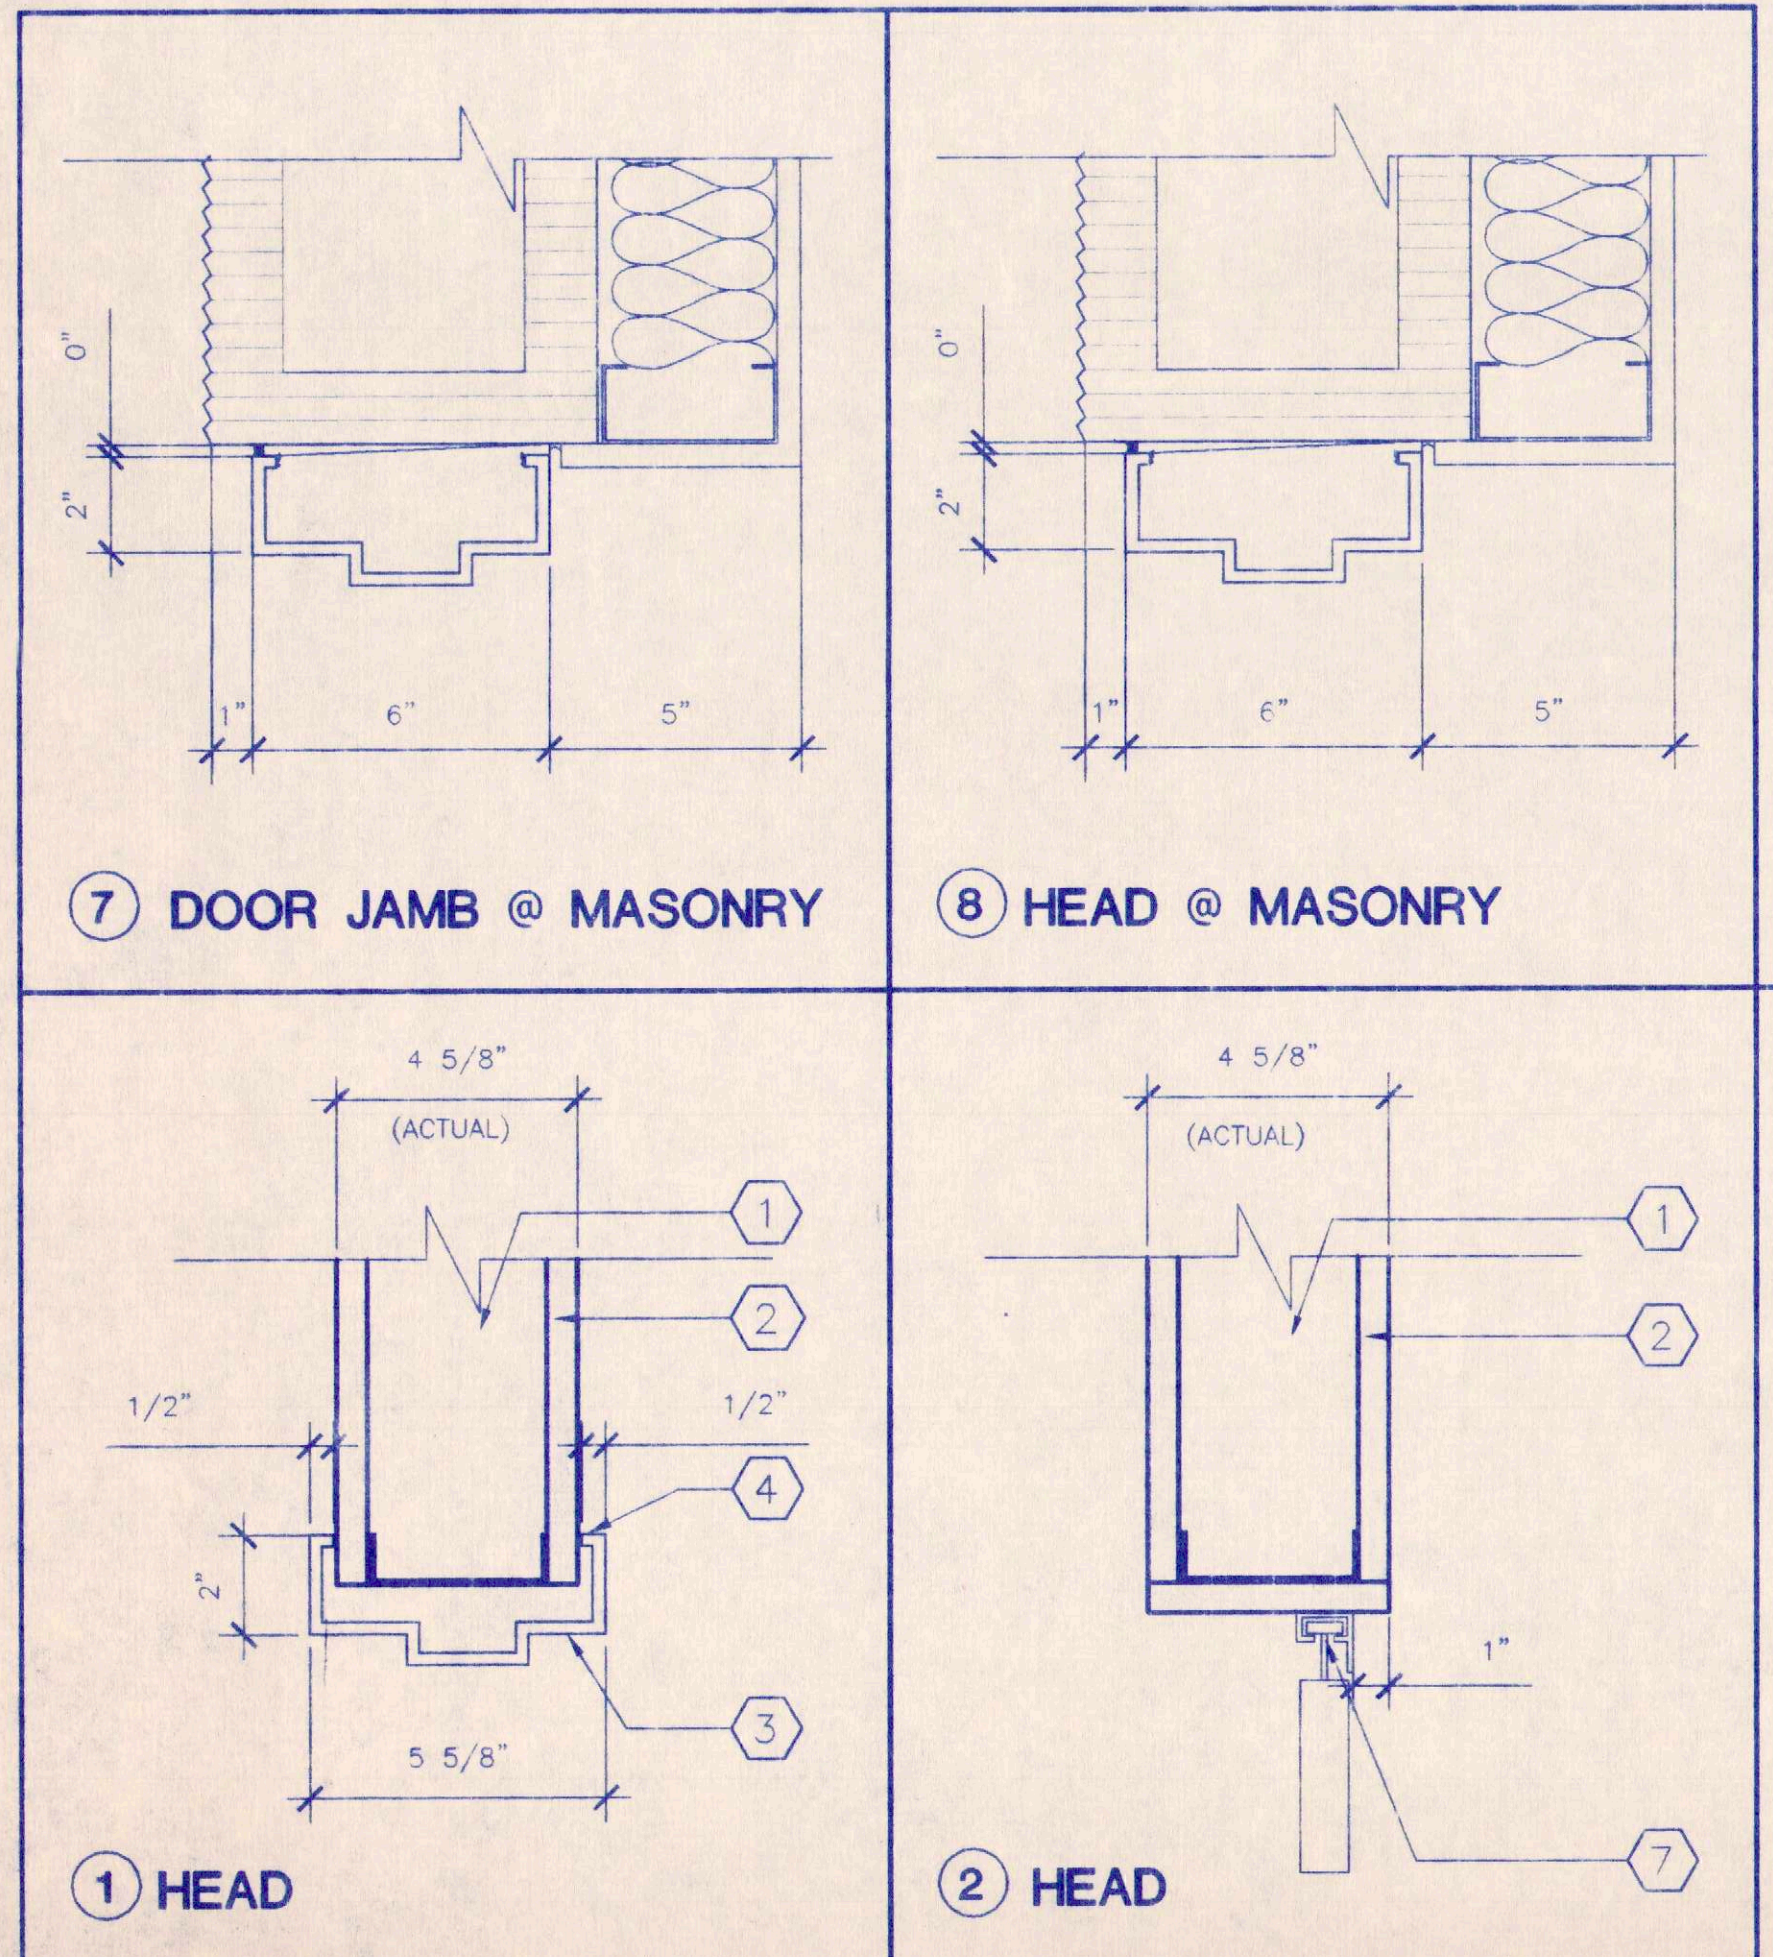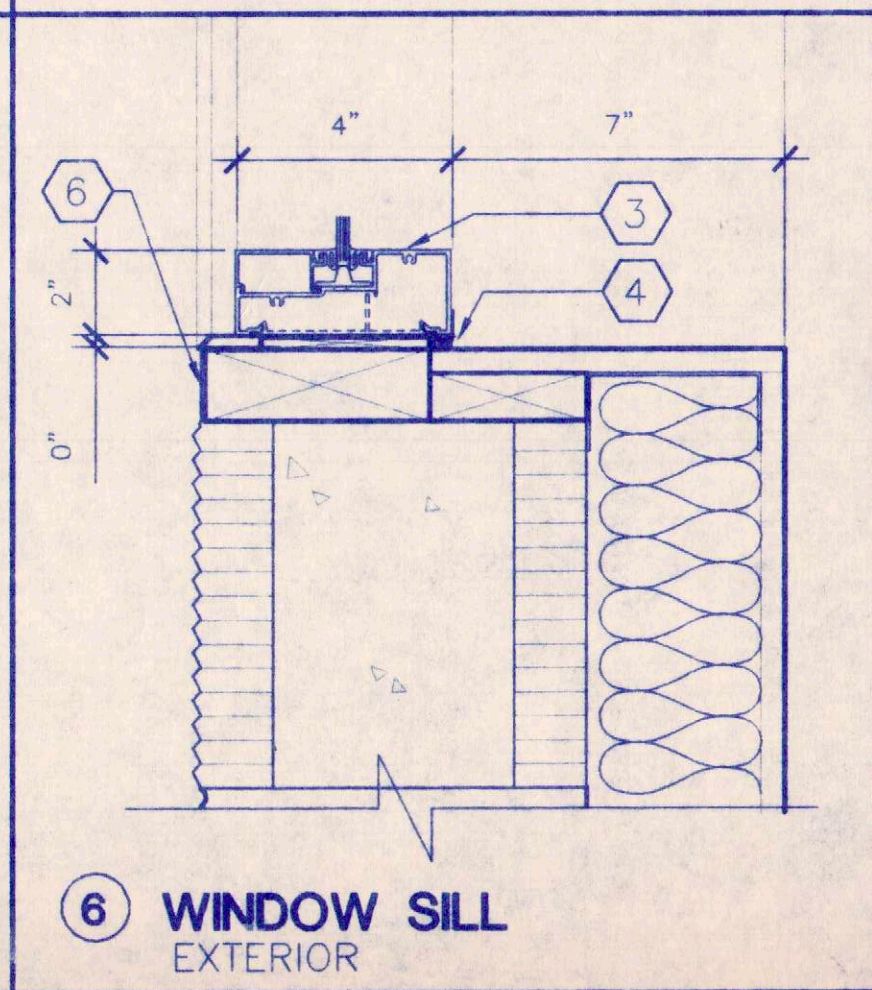

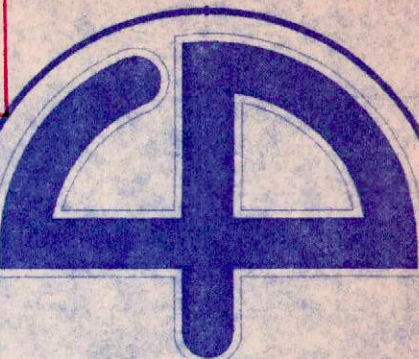

Cuhaci & Peterson
Architects

1220 Alden Road
Orlando, Florida 32803
Ph. 407 228 4220
Fax. 407 228 4219

© COPYRIGHT
All reports, plans, specifications, computer files,
field data, notes and other documents and
instruments prepared by Cuhaci & Peterson
Architects (C & P) or instruments of service
remain the property of C & P. C & P
shall retain all rights in the design and other
reserved rights, including the copyright therein.
Any use or reproduction of this document with-
out written permission from C & P is a
violation of Federal copyright laws.

JOB TITLE
P.C.G., INC
1000 JETSTREAM DRIVE
ORLANDO, FLORIDA

DRAWING TITLE
RESTROOM PLANS
& INT. ELEVATIONS

REVISION:	5
6/5/2000	6
	7
	8
	9


JOB NO.	99228
SCALE	AS SHOWN
DATE	4/10/2000
DRAWN	MCL
CHECKED	JAF
DRAWING NO.	

A10


TOILET ROOM ACCESSORIES			
MARK	ITEM	MANUF.	ID. # DESCRIPTION
R-1	GRAB BAR	BOBRICK	#B-6106 1 1/2" DIA. EXPOSED MOUNTING, SATIN FINISH
R-2	24" TOWEL BAR	BOBRICK	#B-673 STAINLESS STEEL
R-3	MIRROR	BOBRICK	#B-165 24x36 STAINLESS STEEL, FRAMED MIRROR
R-4	SOAP DISPENSER	BOBRICK	#B-2111 SATIN FINISH, STAINLESS STEEL CONTAINER VANDAL-RESISTENT LID, STAINLESS STEEL LATHER VALVE, CAPACITY: 40 FL. OZ. (WALL MOUNTED)
R-5	TOILET PAPER DISP	BOBRICK	#B-4288 MULTI-ROOL (SURFACE MOUNT), SATIN FINISH
R-6	RECESSED PAPER TOWEL DISPENSER AND WASTE RECEPTACLE	BOBRICK	#B-3944 STAINLESS STEEL
R-7	60" SHOWER ROD	BOBRICK	#B-6047 STAINLESS STEEL
R-8	SANT. NAPKIN. DISPENSER	BOBRICK	#B-270 STAINLESS STEEL, SATIN FINISH (WOMENS ONLY)

RESTROOM KEYED NOTES


- TOILET STALL, PARTITION, URINAL SCREEN - 18" X 42"
- GRAB BARS IN EACH TOILET ROOM. MOUNT 3'-0" A.F.F. PROVIDE BLOCKING FOR GRAB BARS.
- TOILET TISSUE DISPENSER, MOUNT TOP AT 2'-4" A.F.F. FURNISHED AND INSTALLED BY G.C.
- FEMININE NAPKIN DISPOSAL: MOUNT TOP BETWEEN 25" - 30"
- MIRROR (AT EACH LAVATORY) MOUNT BOTTOM AT 3'-4" A.F.F.
- PROVIDE BLOCKING AS REQUIRED FOR WALL HUNG CABINETRY
- 5'-0" DIAMETER WHEEL CHAIR SPACE ALLOWANCE.
- NOT USED
- COUNTER BACKSPLASH 4" HIGH
- LAVATORY SINK W/PROTECTIVE JACKET AROUND PIPES
- CABINETRY BY G.C.
- TOILET PARTITION ENCLOSURE

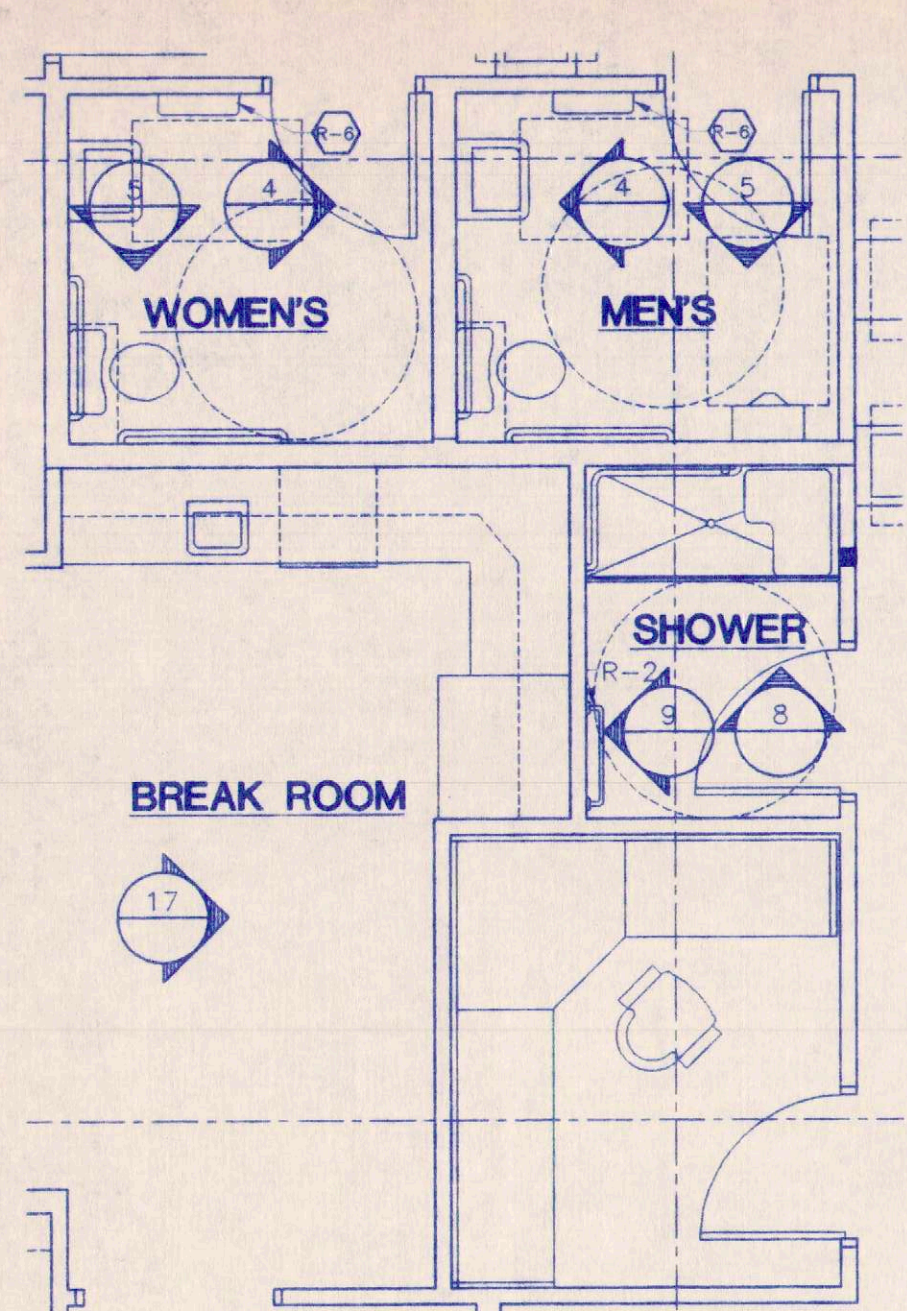


1 RESTROOM & SHOWER PLANS
SCALE: 1/4" = 1'-0"

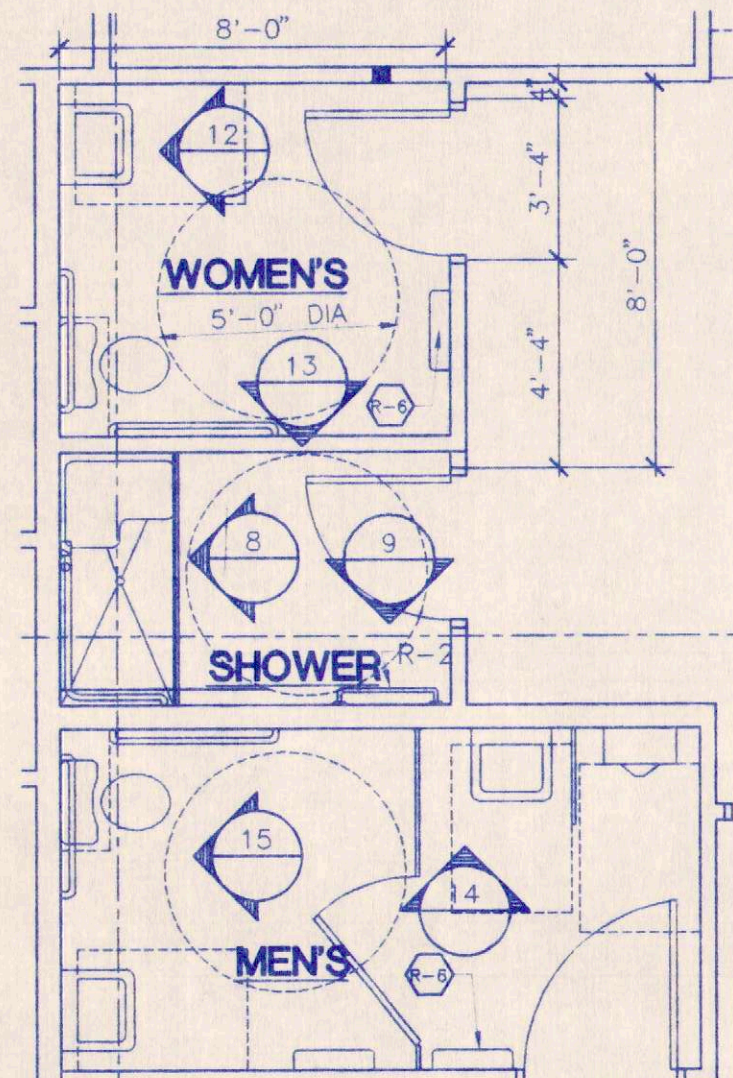


2 RESTROOM & SHOWER PLANS
SCALE: 1/4" = 1'-0"

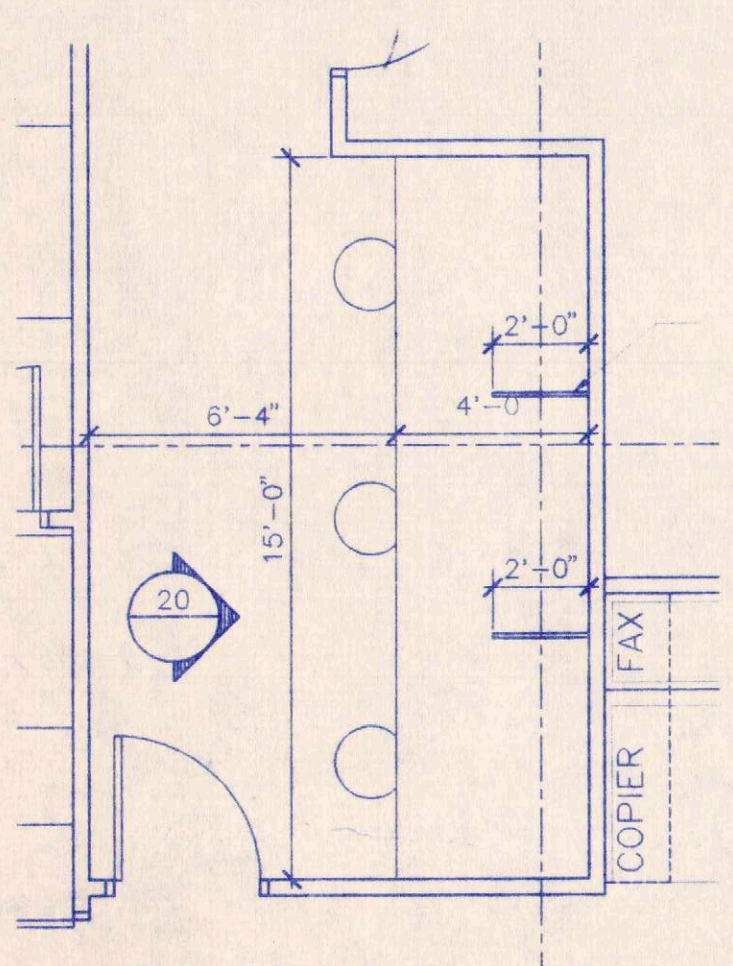

3 PLAN VIEW OF BAR
SCALE: 1/4" = 1'-0"

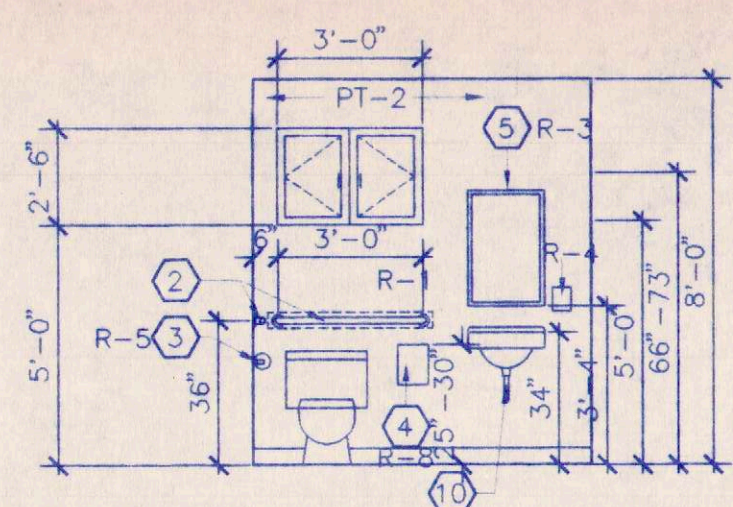


4 WAREHOUSE RESTROOM ELEVATIONS
SCALE: 1/4" = 1'-0"

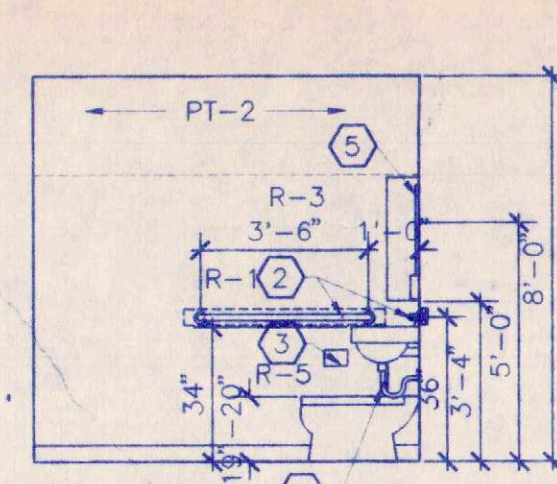


5 WAREHOUSE RESTROOM ELEVATIONS
SCALE: 1/4" = 1'-0"

6 NOT USED
SCALE: 1/4" = 1'-0"

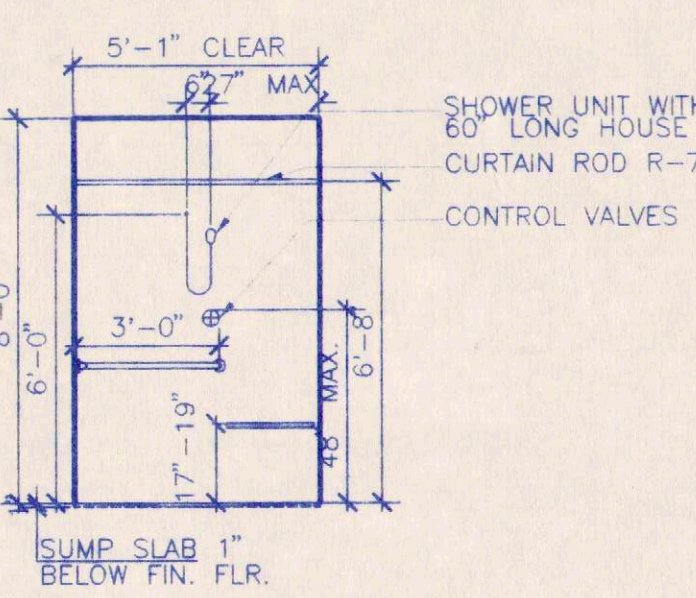


8 SHOWER ROOM ELEVATION
SCALE: 1/4" = 1'-0"

7 NOT USED
SCALE: 1/4" = 1'-0"

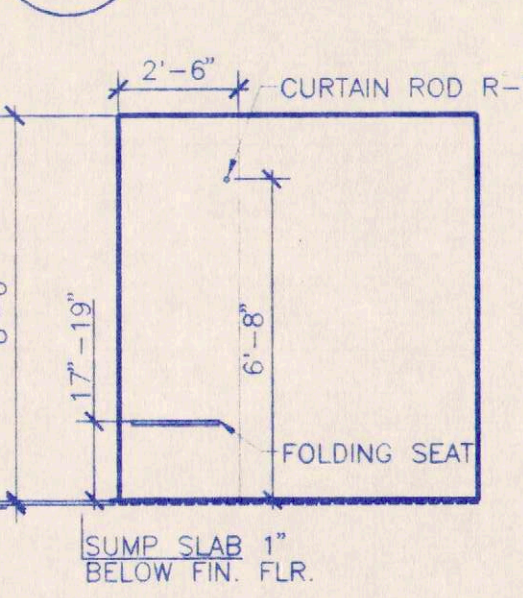


9 SHOWER ROOM ELEVATION
SCALE: 1/4" = 1'-0"

16 NOT USED
SCALE: 3" = 1'-0"

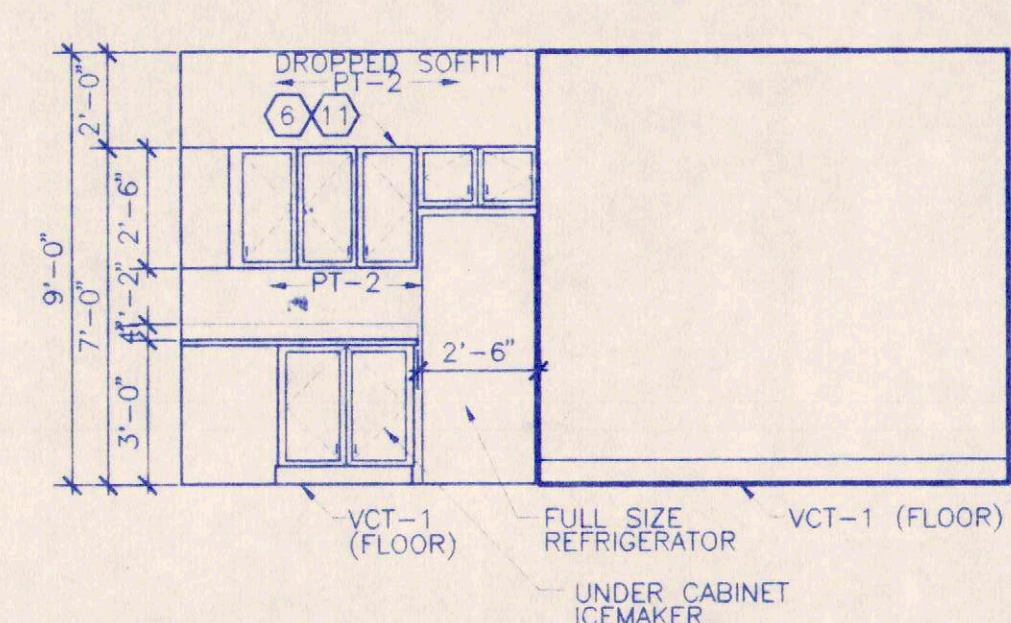


18 BREAK ROOM ELEVATION
SCALE: 1/4" = 1'-0"

17 NOT USED
SCALE: 3" = 1'-0"

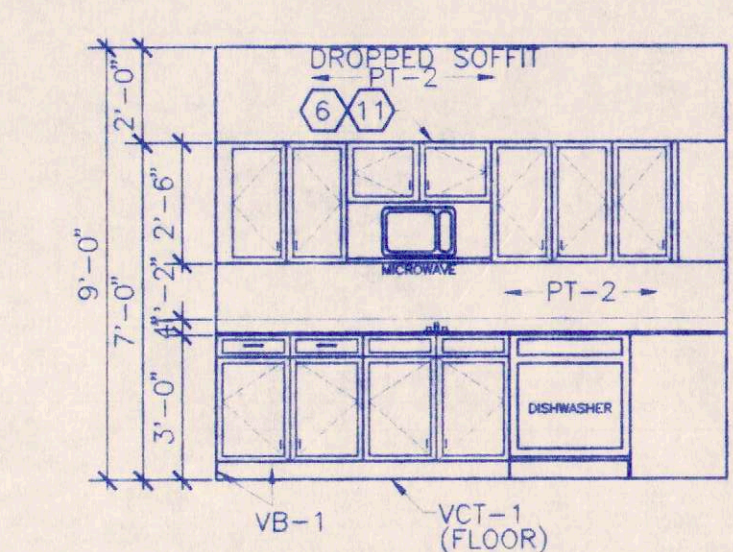


19 BREAK ROOM ELEVATION
SCALE: 1/4" = 1'-0"

10 NOT USED
SCALE: 1/4" = 1'-0"

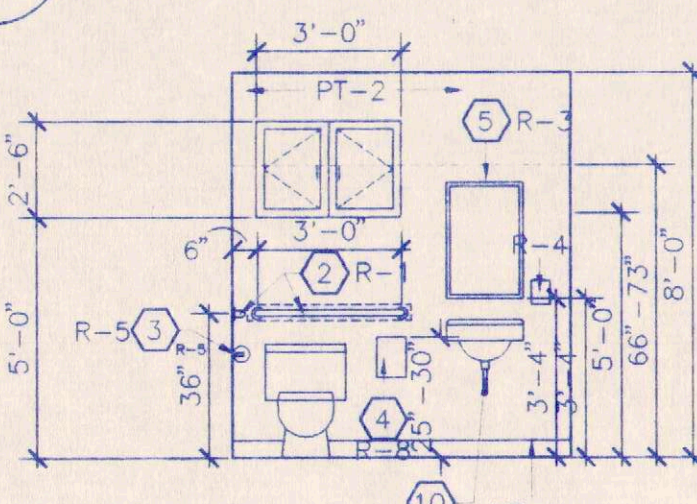


12 WOMEN'S RESTROOM ELEVATION
SCALE: 1/4" = 1'-0"


11 NOT USED
SCALE: 1/4" = 1'-0"

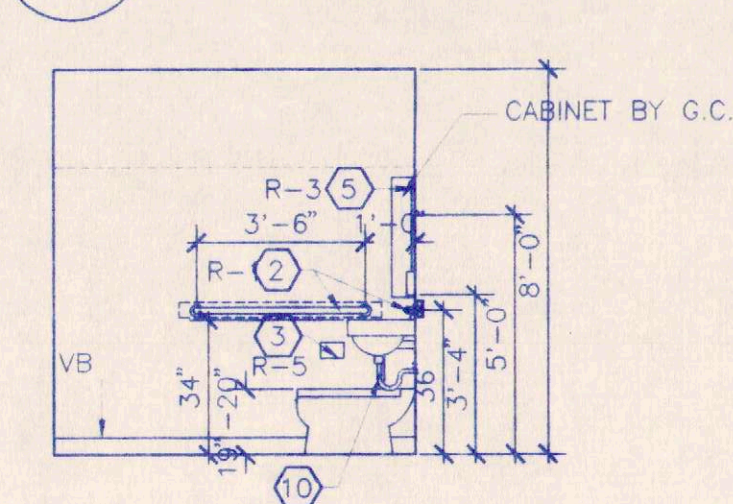


13 WOMEN'S RESTROOM ELEVATION
SCALE: 1/4" = 1'-0"

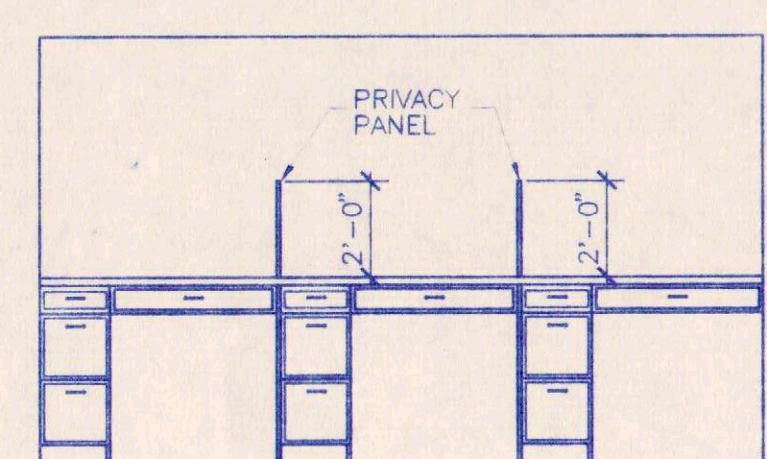

20 PLAN VIEWING BAR ELEVATION
SCALE: 1/4" = 1'-0"

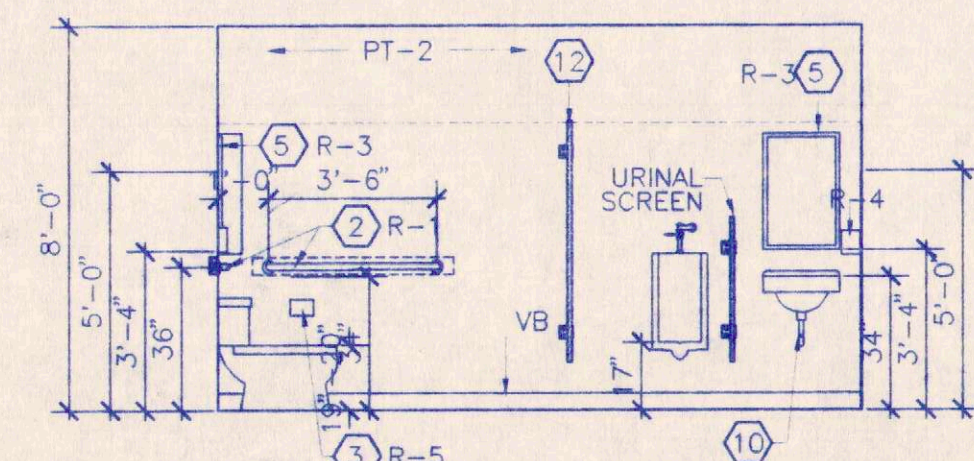

14 MEN'S RESTROOM ELEVATION
SCALE: 1/4" = 1'-0"

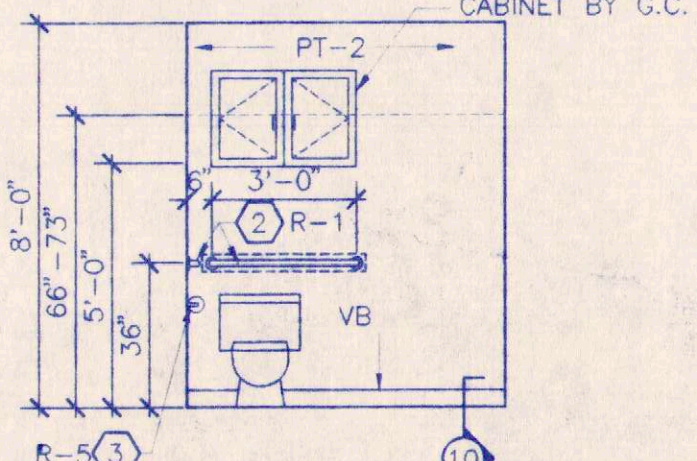


15 MEN'S RESTROOM ELEVATION
SCALE: 1/4" = 1'-0"

21 NOT USED
SCALE:

*ALL CABINETRY BY OTHERS

RELEASED FOR
CONSTRUCTION

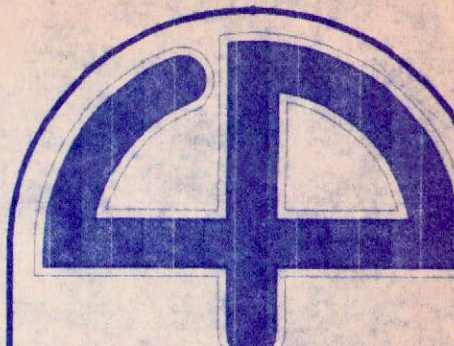

Cuhaci & Peterson
Architects

1220 Alden Road
Orlando, Florida 32803
Ph: 407 228 4220
Fax: 407 228 4219

© COPYRIGHT
All reports, plans, specifications, computer files,
field data, notes and other documents and
instruments prepared by Cuhaci & Peterson
Architects (C & P) are judgments of service
remain the property of C & P. C & P
shall retain all common law, statutory and other
reserved rights, including the copyright therein.
Any use or reproduction of this document with-
out written permission from C & P is a
violation of Federal copyright law.

P.C.G., INC
1000 JETSTREAM DRIVE
ORLANDO, FLORIDA

AS BUILT


FOUNDATION /
FRAMING PLAN

DRAWING TITLE

REVISION:	
1/4/18/00	
2/6/5/2000	

JOB NO.	HB-99-261
SCALE	AS SHOWN
DATE	4/10/2000
DRAWN	SRT
CHECKED	SB
DRAWING NO.	

S1

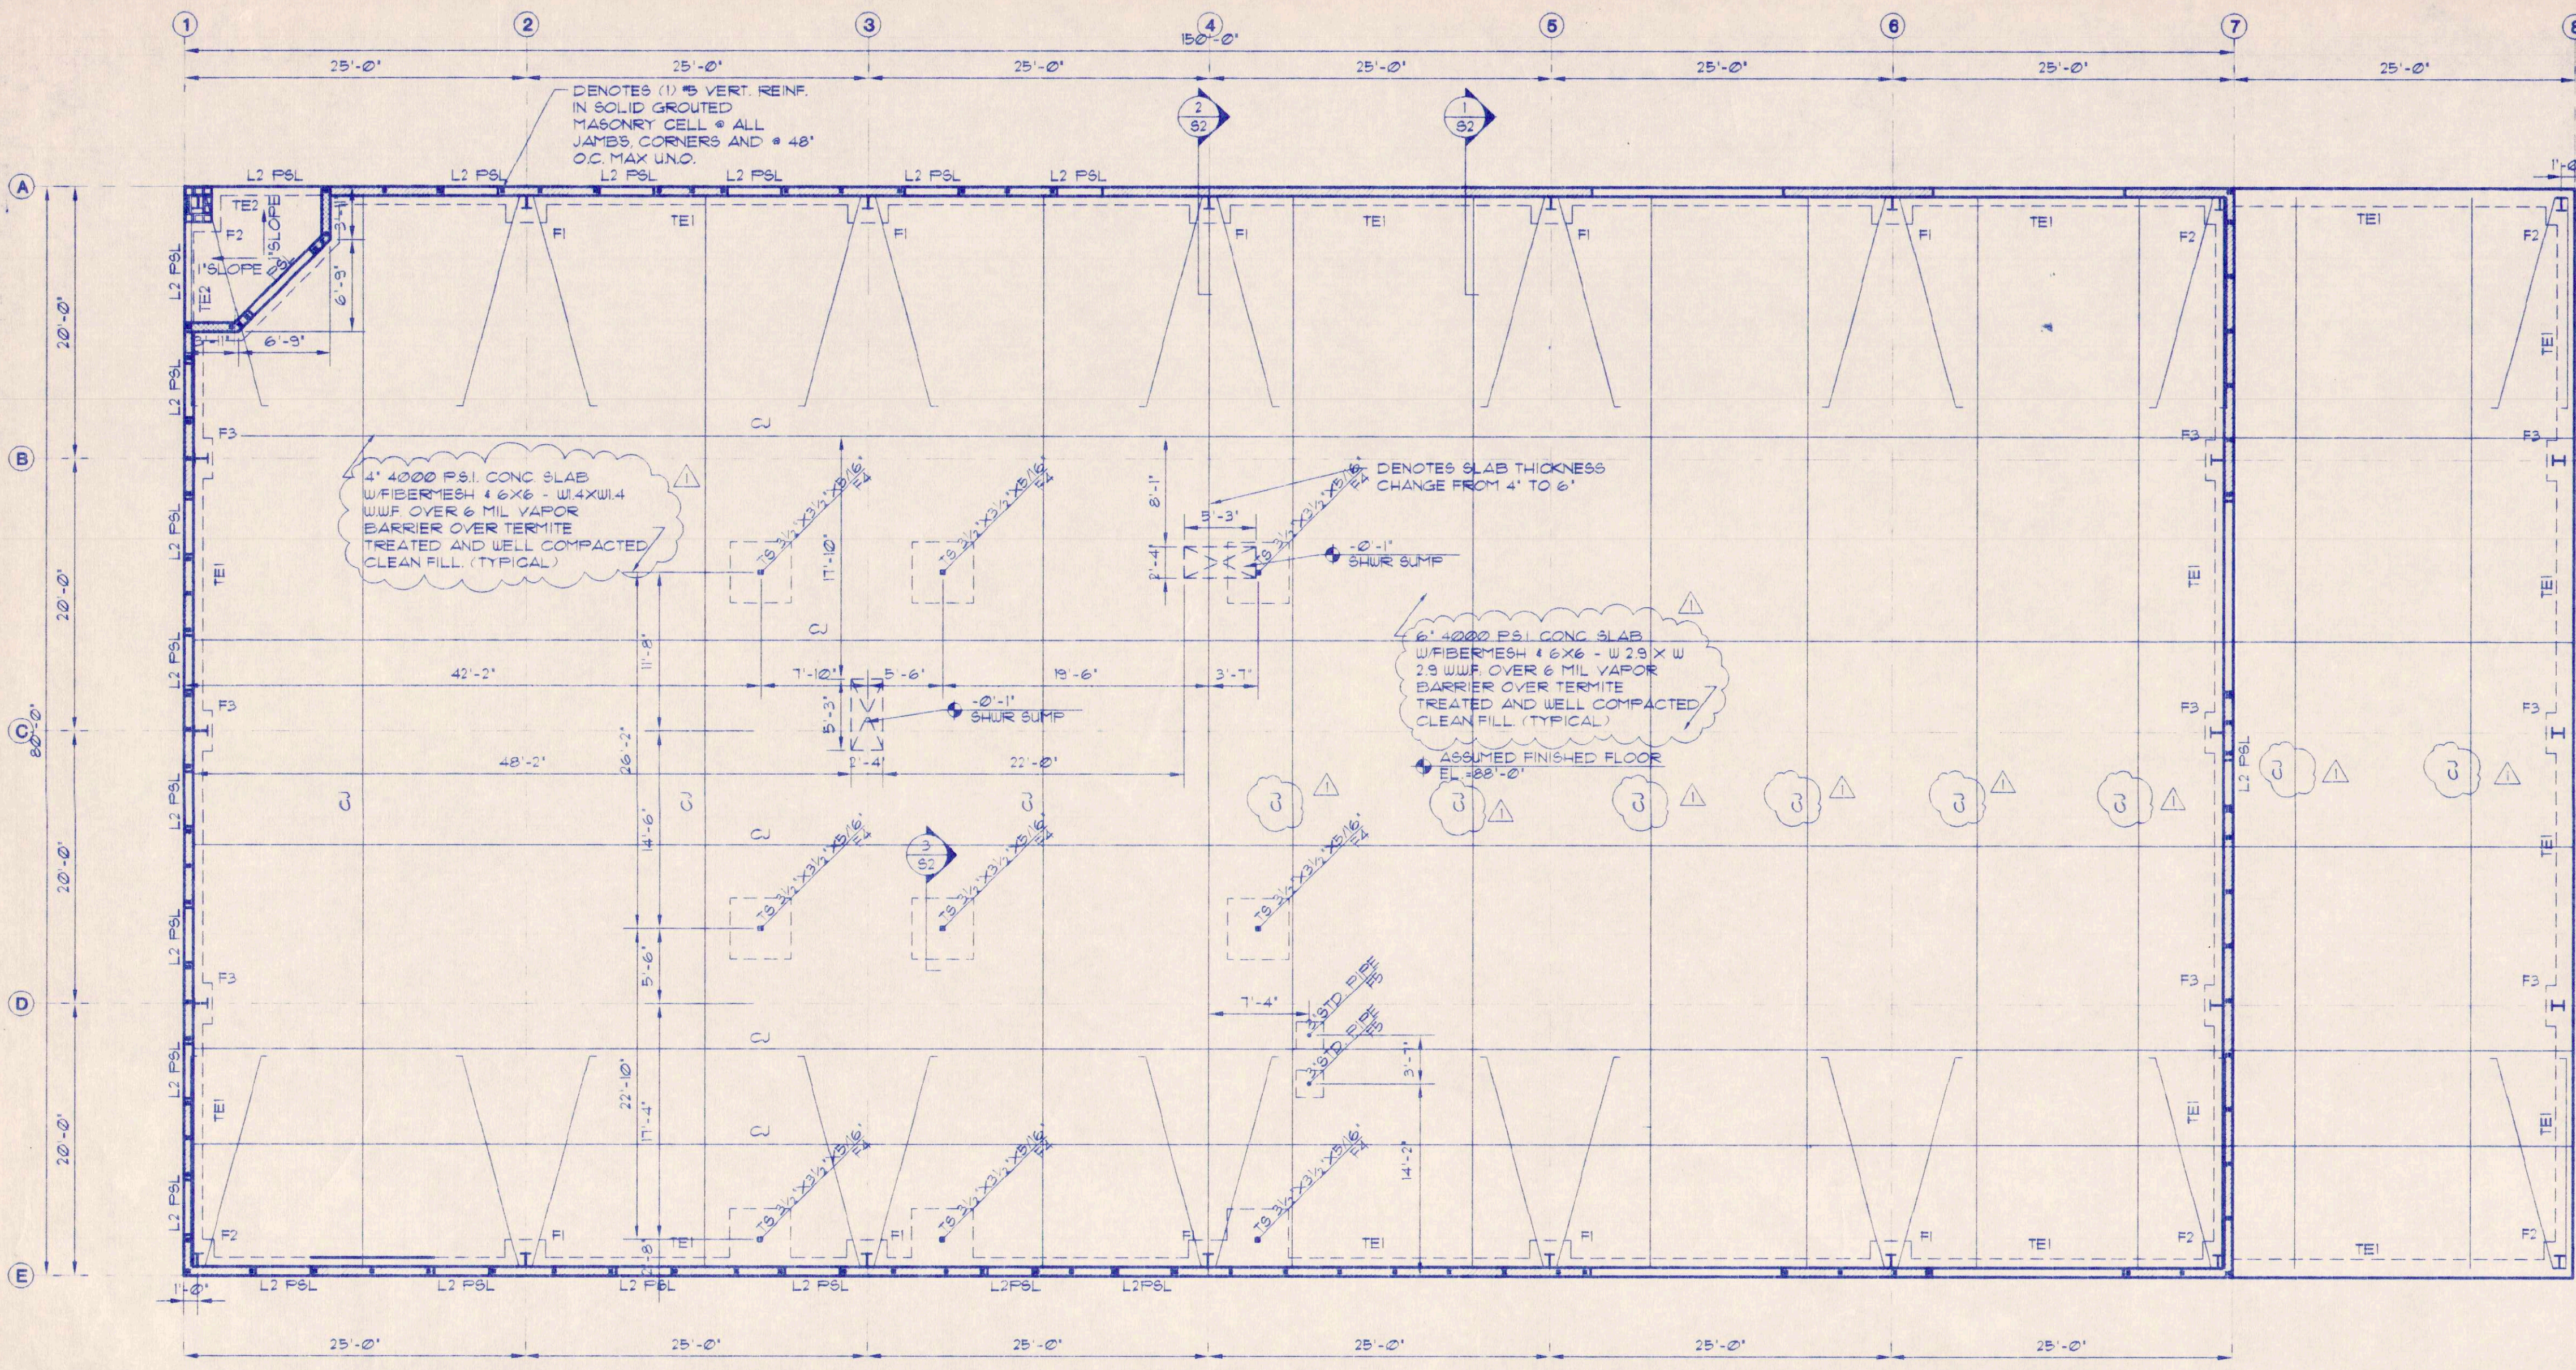

STRUCTURAL DESIGN CRITERIA

GOVERNING CODES AND SPECIFICATIONS

- Standard Building Code, 1997 Edition.
- Load and Resistance Factor Design Specification for Structural Steel Buildings.
- Specifications for Structural Steel Buildings, Allowable Stress Design and Plastic Design, June 1, 1989.
- Building Code Requirements for Reinforced Concrete, ACI 318-89.
- Minimum Design Loads for Buildings and Other Structures, ASCE 7-88.
- Standard Specifications for Open Web Steel Joists, K-Series, September 1, 1994.

VERTICAL DESIGN LOADS

- Mezzanine Dead Load 50 PSF
- Mezzanine Live Load 125 PSF LIVE LOAD PER TABLE 1604.1

LATERAL DESIGN LOADS

- Wind Load: Basic Pressure 120 MPH Region 23.0 PSF Use coefficients from SBC Chapter 16.

GENERAL STRUCTURAL NOTES

FOUNDATION

- Foundation design is based on an allowable soil bearing pressure of 2000 PSF and on recommendations made by Andreyev Engineering, Inc. within soils report # RGT-99-246 for PCG Properties, Inc., dated November 30, 1999.
- Refer to the above referenced soils reports for recommendations regarding soil conditions, temporary groundwater control, general site preparation, fill placement and compaction requirements.
- Contractor shall provide complete reports, prepared by a Florida Registered Geotechnical Engineer, of all monitoring and testing performed to bring the foundation strata within conformance of design recommendations. Monitoring and testing shall be performed in accordance with the project specifications.
- Provide 6 mil vapor barrier over compacted subgrade for slab on grade. Vapor barrier shall be lapped a minimum of 6 inches in direction of concrete pour. Care shall be exercised to prevent damage or rupture of barrier. Where columns, pipe conduit, etc. penetrate membrane, cut around projection and seal with joint tape.

CONCRETE

- All concrete work shall be accomplished in accordance with 'Specifications for Structural Concrete for Buildings' ACI 301-89.
- All concrete shall have a specified minimum compressive strength of 4000 PSI w/ min. flyash content of 10% except mezzanine slab which shall be 3000 PSI at 28 days, w/ min. flyash content of 10%.
- Concrete aggregate shall be 3/4"-in. accordance with ASTM C33.
- Submit mix design for review prior to concrete pour.
- Fibermesh shall be 100% virgin polypropylene, fibrillated fibers containing no reprocessed olefin materials and specifically manufactured to an optimum gradation for use as concrete secondary reinforcement. Volume per cubic yard shall equal a minimum of 0.1% (15 pounds).
- Contractor shall follow ACI recommendations for curing of slabs to minimize random cracking.

REINFORCEMENT

- Reinforcing steel shall be in accordance with ASTM A615, Grade 60.
- Masonry joint reinforcement shall be hot-dip galvanized steel wire in accordance with ASTM A82.
- Welded wire fabric shall be in accordance with ASTM A185 and shall be placed in the upper 1/3 of the slab.

STEEL JOISTS

- Design of steel joists shall be in accordance with Standard Specifications for Open Web Steel Joist, K-Series.
- The manufacturer shall design the roof joists and joists with exterior exposure to resist the net uplift as specified on the plans. Allowable stresses may be increased by 1/3 only under the guidelines of the AISI Specification Section A5.2.
- The joist manufacturer shall be a member of the Steel Joist Institute.

PRE-ENGINEERED METAL BUILDING

- All structural mill sections and welded plate sections shall be designed in accordance with the AISI Specification for Structural Steel Buildings.
- All cold-formed steel structural members shall be designed in accordance with the AISI Specification for the Design of Cold-Formed Steel Structural Members.
- The contractor shall submit complete engineering design analysis and erection drawings for the proper identification and assembly of all building components for review prior to fabrication. These drawings shall indicate bolt patterns, transverse cross sections, sidewall elevations, endwall and roof framing, wind bracing and accessory installation details.
- The engineering design analysis and erection drawings shall bear the seal of a Florida registered engineer.
- Pre-engineered metal buildings shall be engineered and fabricated to meet the AISI certification standard for Category MB.

STEEL JOISTS

- Design of steel joists shall be in accordance with Standard Specifications for Open Web Steel Joist, K-Series.
- The manufacturer shall design the roof joists and joists with exterior exposure to resist the net uplift as specified on the plans. Allowable stresses may be increased by 1/3 only under the guidelines of the AISI Specification Section A5.2.
- The joist manufacturer shall be a member of the Steel Joist Institute.

MASONRY


- All concrete masonry work shall be in accordance with 'Specifications for Concrete Masonry Structures' ACI 301-89.
- Concrete masonry units shall be in accordance with ASTM C90, Grade N, Type II and shall be of a type such that the cores line up vertically.
- Compressive strength of masonry assembly shall be 1500 PSI minimum.
- Masonry mortar shall be in accordance with ASTM C270, Type S or M.
- GROUT for masonry work shall be in accordance with ASTM C416, Coarse Type, and shall attain a compressive strength of 2000 PSI at 28 days.
- Provide 9 gauge ladder type joint reinforcing at 16" on center vertically in all masonry construction. Lap joint reinforcement a minimum of 6" and discontinue at all wall joints.
- Submit manufacturer's test data of masonry units and assembly for review prior to construction.
- Provide cleanup at the base of all grouted masonry cells. Clean masonry void to be grouted of all debris and mortar protrusions.
- Provide masonry precast lintel with minimum 8" bearing over all masonry openings.
- Provide air-wall at 8" o.c. instead of 16" o.c. at stack bond split face masonry units.

MISCELLANEOUS

- Contractor shall brace all construction against gravity, lateral and uplift loads until structure is complete.
- Coordinate structural work with architectural plans and all other trades.
- All construction shall be in accordance with the Standard Building Code, 1997 Edition.


FOUNDATION PLAN

SCALE: 1/8"=1'-0"

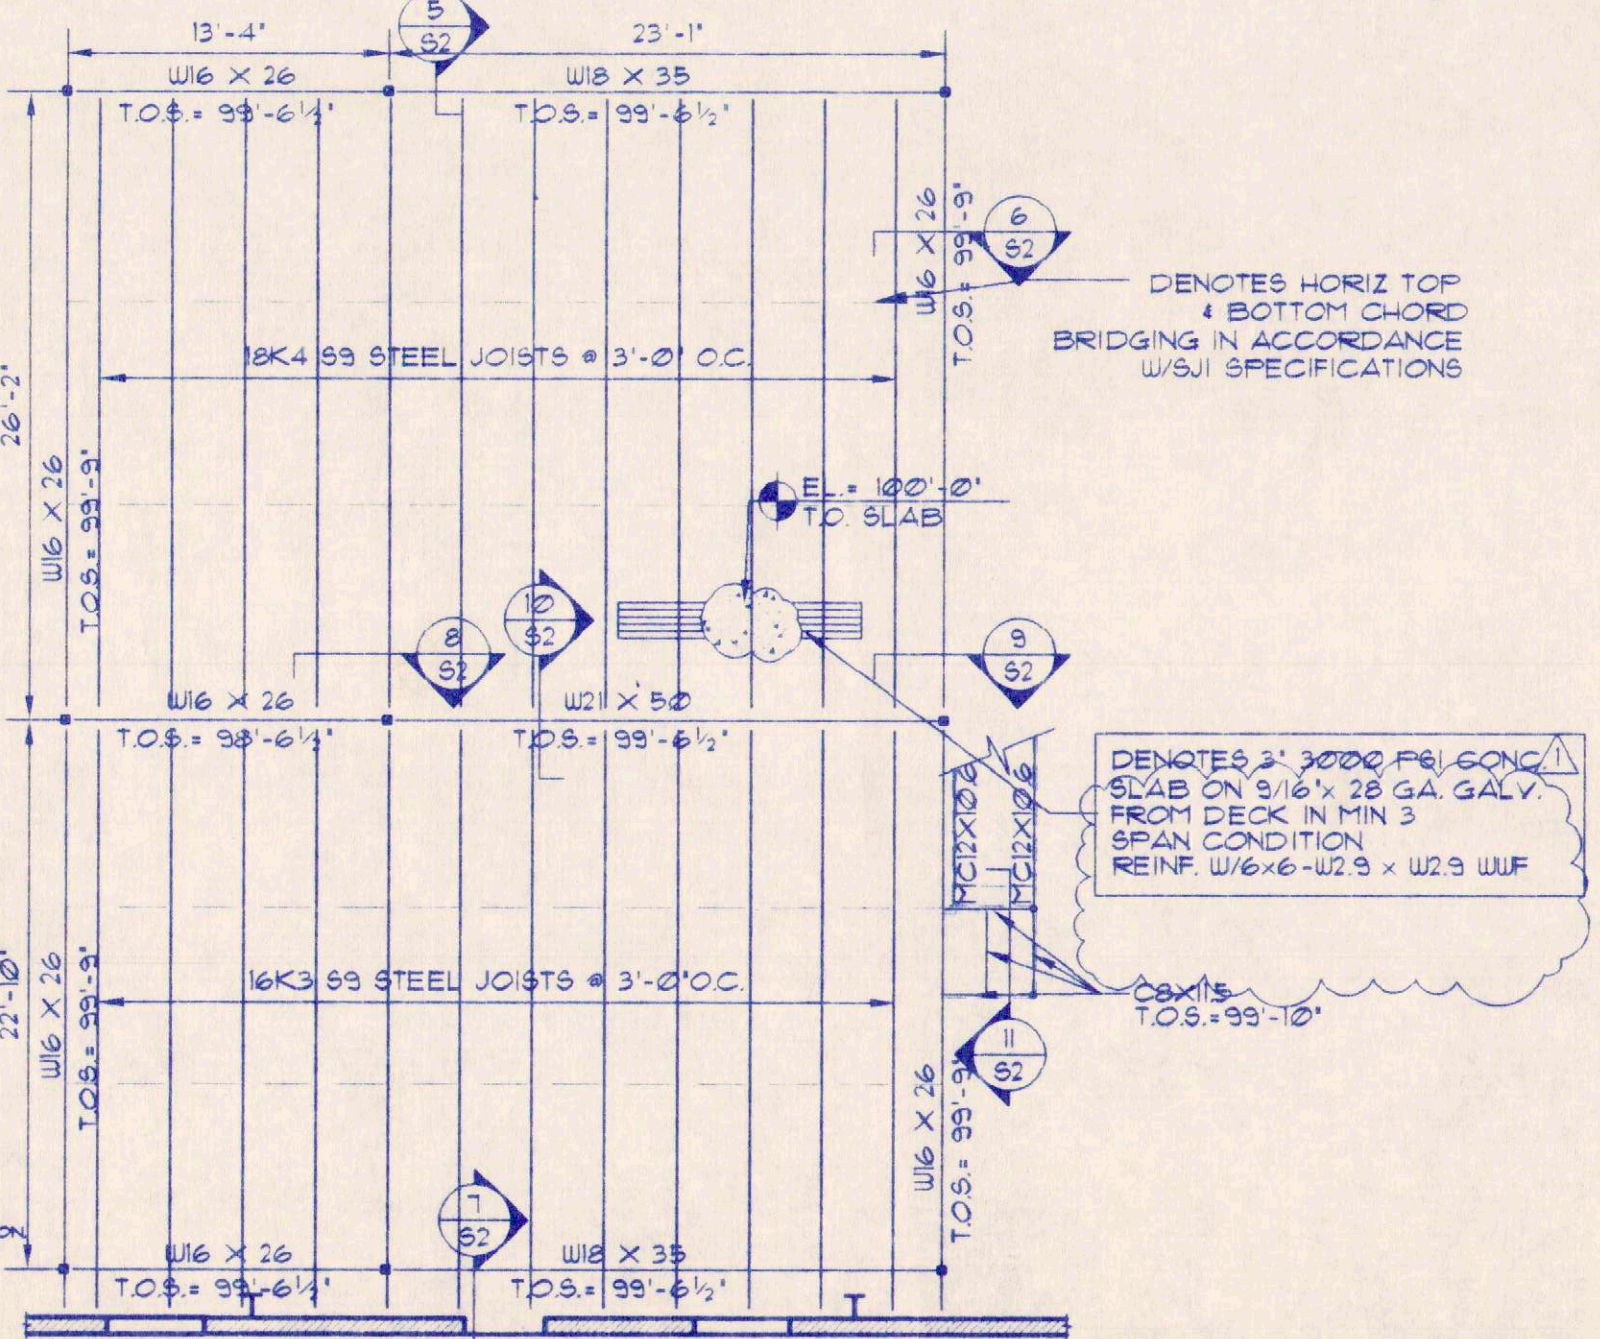


MEZZANINE PLAN

SCALE: 1/8"=1'-0"

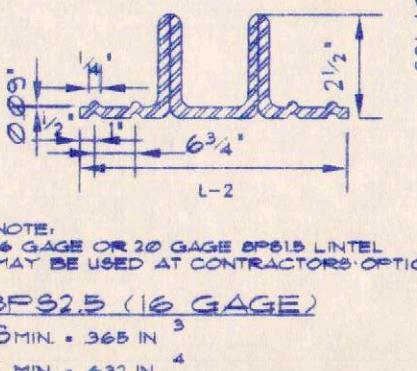

1. PRODUCT NAME (PATENT NO. 4751656: SBCCI PST # ESI # 93-132)
- REFORMED POWERS STEEL LINTEL SHALL BE GALVANIZED COIL STEEL AS MANUFACTURED BY POWERS STEEL AND WIRE PRODUCTS, INC. STEEL GRADE SHALL BE ASTM A570- GRADE C Fy = 40 ksi
2. SHORE LINTELS AS REQUIRED TO COMPENSATE FOR DEAD LOAD DEFLECTION ON NON-CURED MASONRY.
3. LINTELS TO BE USED WITH BRICK OR CONCRETE MASONRY UNITS HAVING A MINIMUM Fm AS SHOWN.
4. STEEL SURFACES IN CONTACT WITH GROUT AND/OR MORTAR SHALL BE UNPAINTED AND FREE OF MATERIAL THAT MIGHT INHIBIT BOND.
5. BEARING EACH END SHALL BE 3' PLUS OR MINUS 1". BEARING SHALL BE ON A MINIMUM 8" DEEP GROUTED CELL EXCEPT THAT L2 AND L3 LINTELS MAY BEAR ON 1 1/4" THICK MINIMUM FACE SHELL.
6. Fm: 1500 PSI MASONRY UNITS SHALL CONFORM TO ASTM C90, GRADE N.
7. GROUT: 3,000 PSI SLUMP RANGE: 8" TO 11" ROD OR VIBRATE GROUT ADEQUATELY TO ENSURE CONSOLIDATION OF GROUT (NO AIR POCKETS) GROUT SHALL COMPLY WITH ASTM C416-83 AND BE EITHER COARSE OR FINE GROUT.
8. MORTAR: TYPE 'S' OR TYPE 'M' 1500 PSI
9. TOP REINFORCING OR TOP OF WALL REINFORCING IS REQUIRED BY CODES TO PROVIDE A CONTINUOUS TIE AROUND A STRUCTURE AND TO PROVIDE FOR UPLIFT RESISTANCE AT LINTELS. TOP REINFORCING IS NOT REQUIRED AND IS NOT PART OF THE POWERS STEEL LINTELS (EXCEPT AT THE L-1 LINTELS A REINFORCING BAR IS REQUIRED FOR THE STEEL STIRRUPS). SIZING OF TOP REINFORCING IS THE RESPONSIBILITY OF THE BUILDING ARCHITECT OR ENGINEER. ALTERNATELY, TOP REINFORCING COULD BE SIZED PER SBCCI DOCUMENT 88TD 10-93.
10. ATTACHMENTS TO TOP OF WALL PER ARCHITECTURAL AND/OR ENGINEERING DRAWINGS.
11. STEEL STIRRUPS SHALL CONFORM TO ASTM A82 Fy = 60 Ksi MINIMUM. STIRRUPS SHALL BE 5/16" DIAMETER SMOOTH ROD AND SHALL BE FABRICATED SUCH THAT THE STIRRUPS HAVE SPRING AND TEND TO REMAIN IN THE HOLES IN THE LINTEL DUE TO THE SPRING. STIRRUPS SHALL HOOK 3/4" AND FIT INTO HOLE IN LINTEL VERTICAL LEG AS SHOWN. AN ALTERNATE SIZE STEEL STIRRUP SHALL BE 2-5/16" x 2 1/2" x LINTEL HEIGHT MINUS 2" x 2 1/2" PER SKETCH.
12. DEEP LINTEL - 11 STIRRUPS AT 4' O.C. EACH END (22 TOTAL STIRRUPS).
- 16" DEEP LINTEL - 6 STIRRUPS AT 8' O.C. EACH END (12 TOTAL STIRRUPS).
- STIRRUP SHALL BE 1 1/2" CLEAR FROM TOP OF GROUT.
12. PLACE FIRST STIRRUP 4" FROM FACE OF JAMB AS SHOWN, 1"
13. MASONRY WALL MAY OCCUR ABOVE COMPOSITE LINTEL HEIGHT. THE DEAD LOAD WEIGHT OF THE LINTEL MAY BE EXCLUDED FROM THE LOAD CALCULATIONS DUE TO THE COMPOSITE NATURE OF THE LINTEL ASSEMBLY.
14. 5 REINFORCING BAR (GRADE 40) TO BEAR ON BOTTOM OF STEEL LINTEL AS SHOWN AND TO BE THE SAME LENGTH AS LINTEL.
15. MANUFACTURE:
- POWERS STEEL PRODUCTS LINTELS
- 4118 EAST ELWOOD
PHOENIX, ARIZONA 85040
PHONE (602) 437-1160
FAX (602) 437-5409
- DAYTONA BEACH, FL. GIL SUMMERS
PH: FAX 1-324-339-3545
FAX: 1-800-542-5576
TAMPA FL. KAREL GRETZINGER
PH: 1-800-519-5072
FAX: 1-813-159-6899
16. TECHNICAL DATA AND ENGINEERING POWERS LINTELS HAVE BEEN DESIGNED IN ACCORDANCE WITH THE FOLLOWING:
- SBCCI 88TD 10-93
 - STANDARD BUILDING CODE - 1934
 - AISI LIGHT GAGE COLD FORMED STEEL DESIGN - 1990
- TECHNICAL ASSISTANCE IS AVAILABLE FROM THE MANUFACTURER ON SPECIAL DESIGN PROBLEMS OR LINTEL DEPTHS DIFFERENT THAN THOSE SHOWN IN THE LOAD TABLES.
- STRUCTURAL ENGINEER FOR THESE LINTELS IS:
- CARUSO, TURLEY SCOTT INC.
2702 North 44th Street, Suite 200
Phoenix, Arizona 85008
Phone No. (602) 912-9120
Fax (602) 912-9390
- IF AN INSPECTOR, CONTRACTOR, SUBCONTRACTOR OR PLANS EXAMINER HAS ANY TECHNICAL QUESTIONS PLEASE CALL PAUL SCOTT TO COLLECT.
17. INSTALLATION
- POWERS LINTELS ARE TO BE INSTALLED IN ACCORDANCE WITH STANDARD CONSTRUCTION PRACTICES SET TO PROPER LINE AND LEVEL, PLUMB AND TRUE, AND IN CORRECT RELATION TO OTHER WORK.
- STIRRUP - PLACEMENT (NOTE: STIRRUPS AT L1 LINTEL ONLY.)

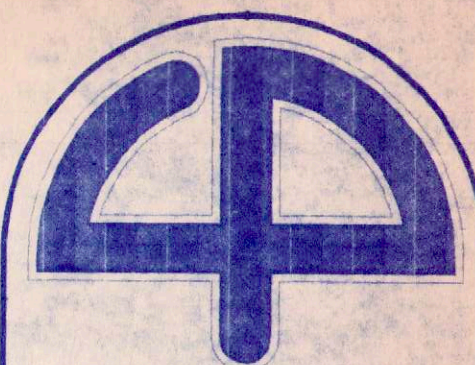

Cuhaci & Peterson
Architects

1220 Alden Road
Orlando, Florida 32803
Ph. 407 228 4220
Fax. 407 228 4219

© COPYRIGHT
All reports, plans, specifications, computer files,
field notes, notes and other documents and
instruments prepared by Cuhaci & Peterson
Architects (C & P) or instruments of service
remain the property of C & P. C & P
shall not be used for any other project or
purpose without the written permission of C & P.
Any use or reproduction of this document with-
out written permission from C & P is a
violation of Federal copyright law.

P.C.G., INC
1000 JETSTREAM DRIVE
ORLANDO, FLORIDA

DETAILS


DRAWING TITLE

REVISION	DATE	BY	CHKD
1	4/18/00		
2			
3			
4			

JOB NO.	HB-99-261
SCALE	AS SHOWN
DATE	4/10/2000
DRAWN	SRT
CHECKED	SB
DRAWING NO.	

S2

AS BUILT

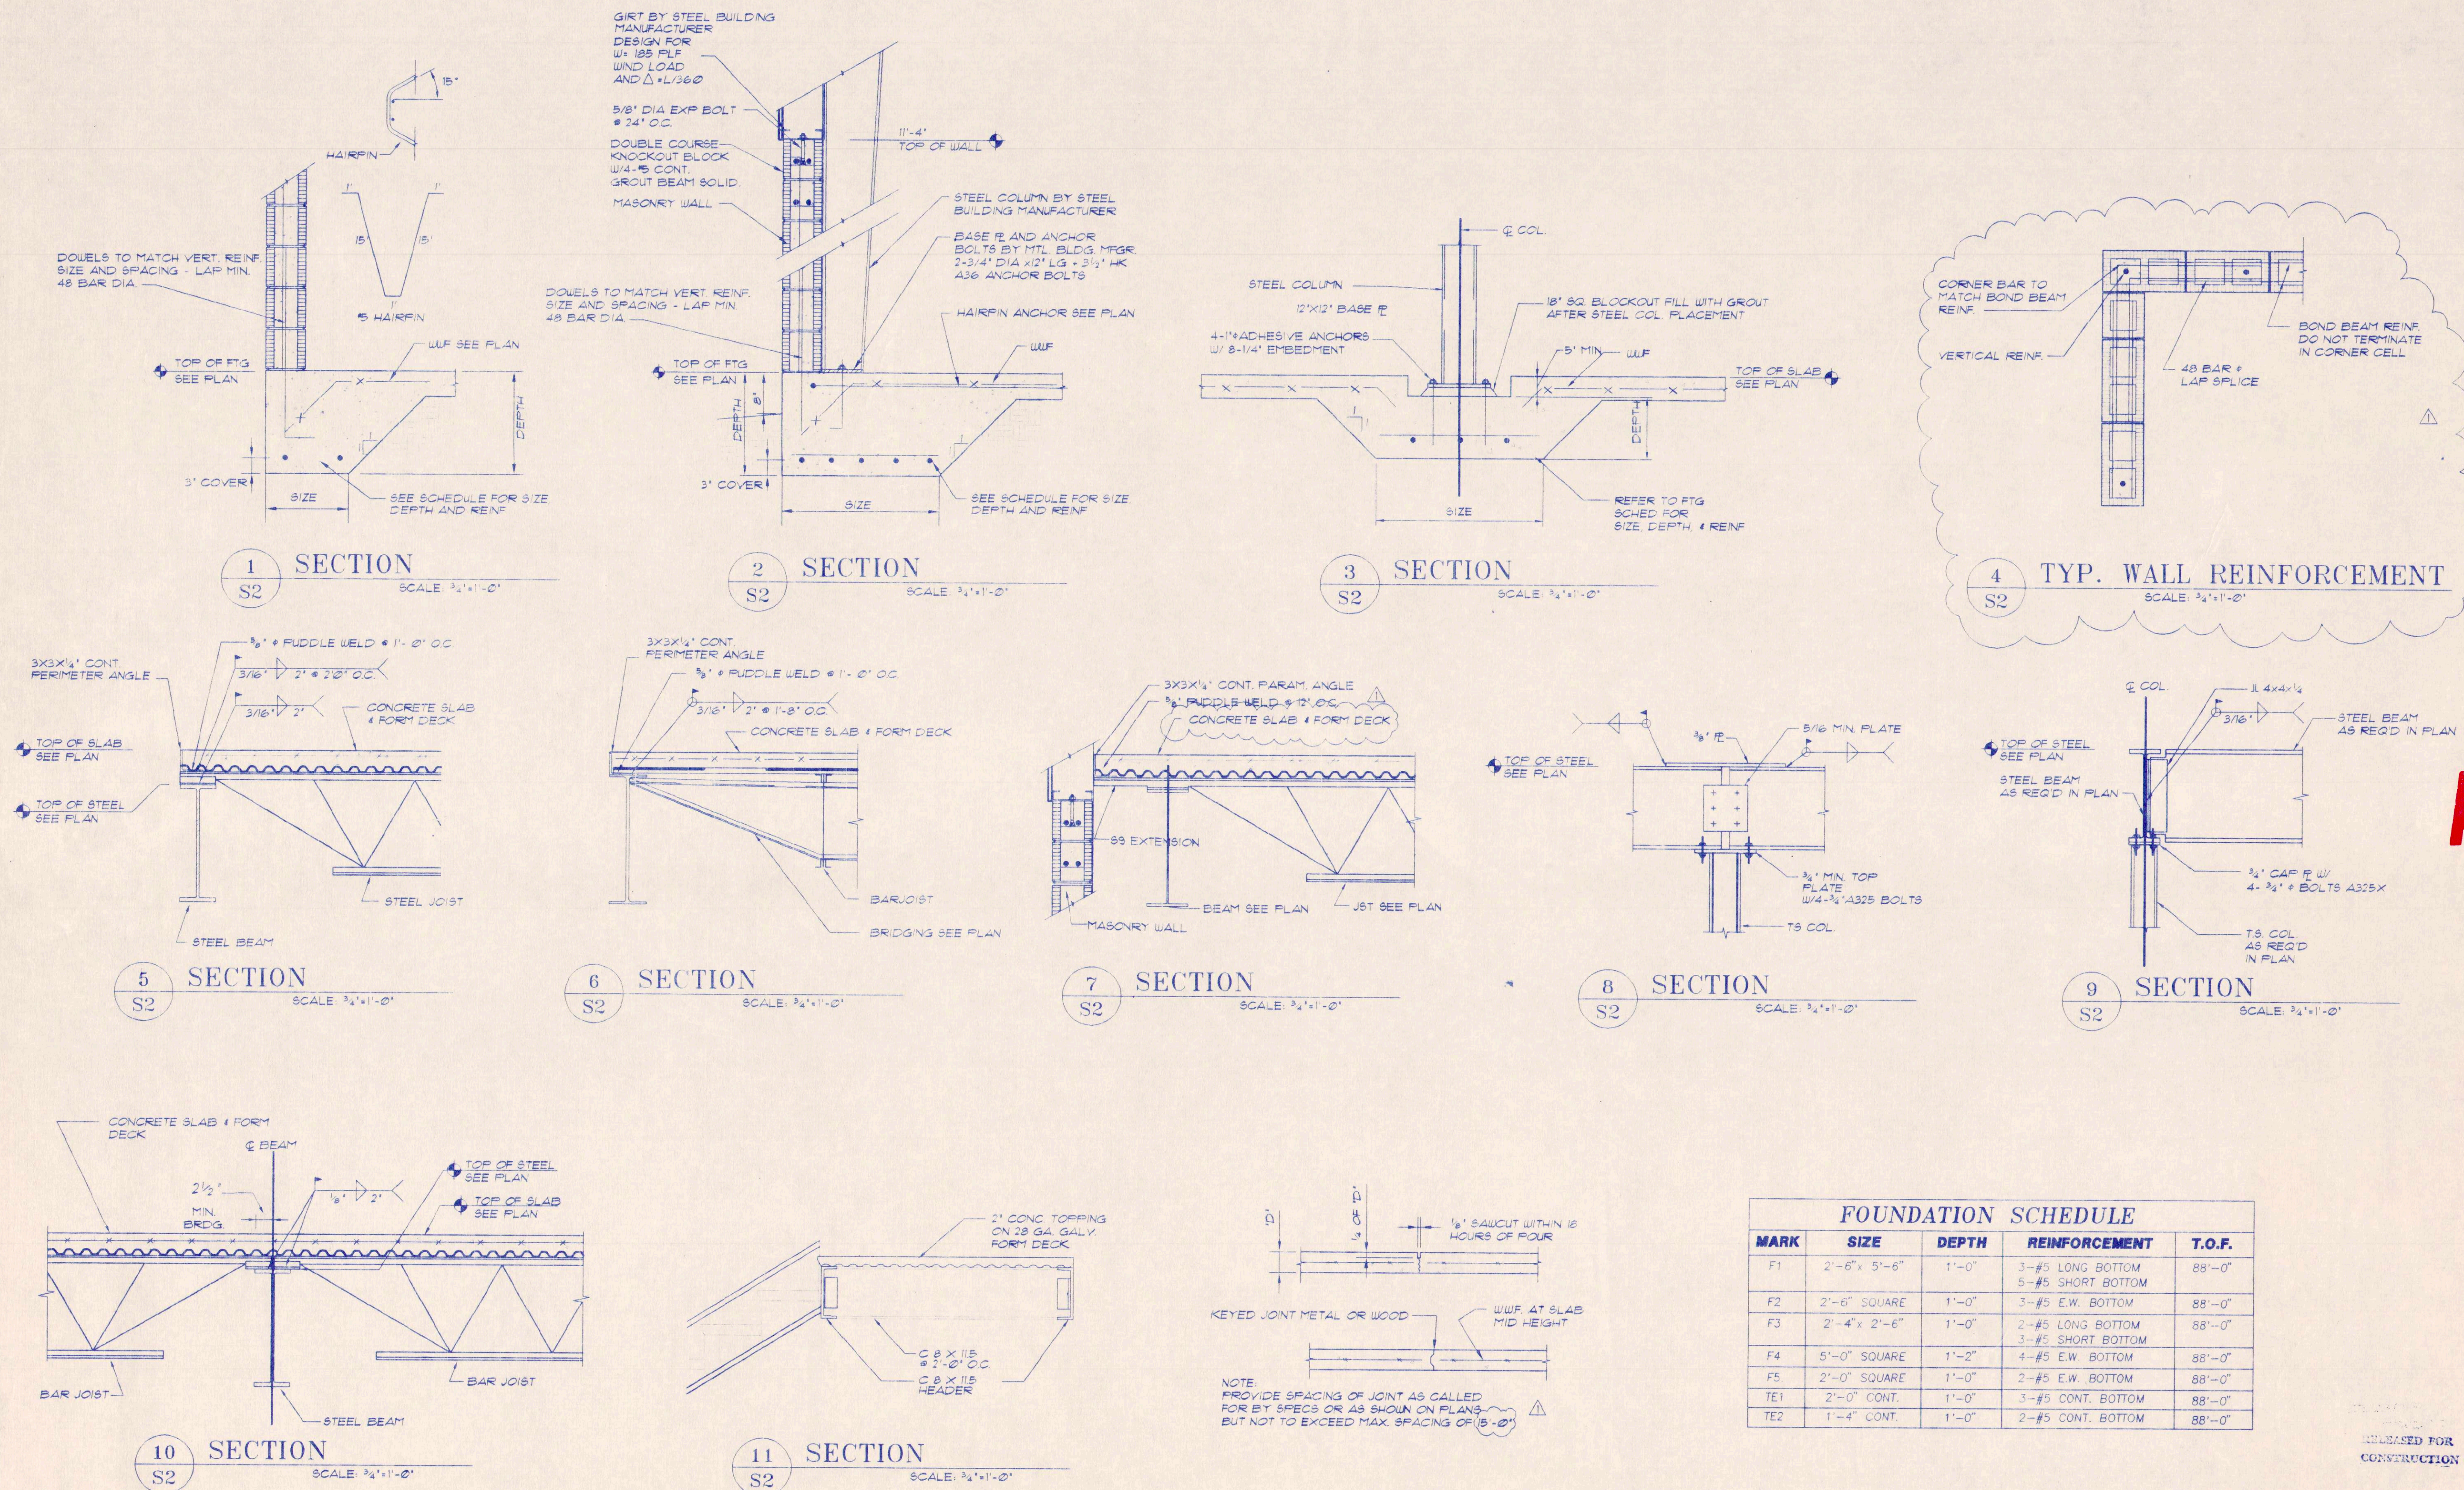

RELEASED FOR
CONSTRUCTION (date) 4/10/2000

HB ASSOCIATES, INC.
STRUCTURAL/CIVIL ENGINEERING
990 LEWIS DRIVE
WINTER PARK, FLORIDA 32789
(407) 740-5444
FAX (407) 740-7900

RECEIVED
FEB 06 2001
PRIME CONSTRUCTION GROUP, INC.



Cuhaci & Peterson
Architects
1220 Alden Road
Orlando, Florida 32803
Ph. 407 228 4220
Fax. 407 228 4219


© COPYRIGHT
All reports, plans, specifications, computer files, field data, notes and other documents and instruments prepared by Cuhaci & Peterson Architects, C & P, or its instruments of service remain the property of C & P. C & P shall retain all common law, statutory and other reserved rights, including the copyright therein. Any use or reproduction of this document without written permission from C & P is a violation of Federal copyright laws.

PRIME CONSTRUCTION
GROUP, INC.
ORLANDO, FL

ELECTRICAL LIGHTING
PLAN

REVISION:	
JOB NO.	99228
SCALE	AS SHOWN
DATE	5/3/00
DRAWN	CRW
CHECKED	AP
DRAWING NO.	

E1

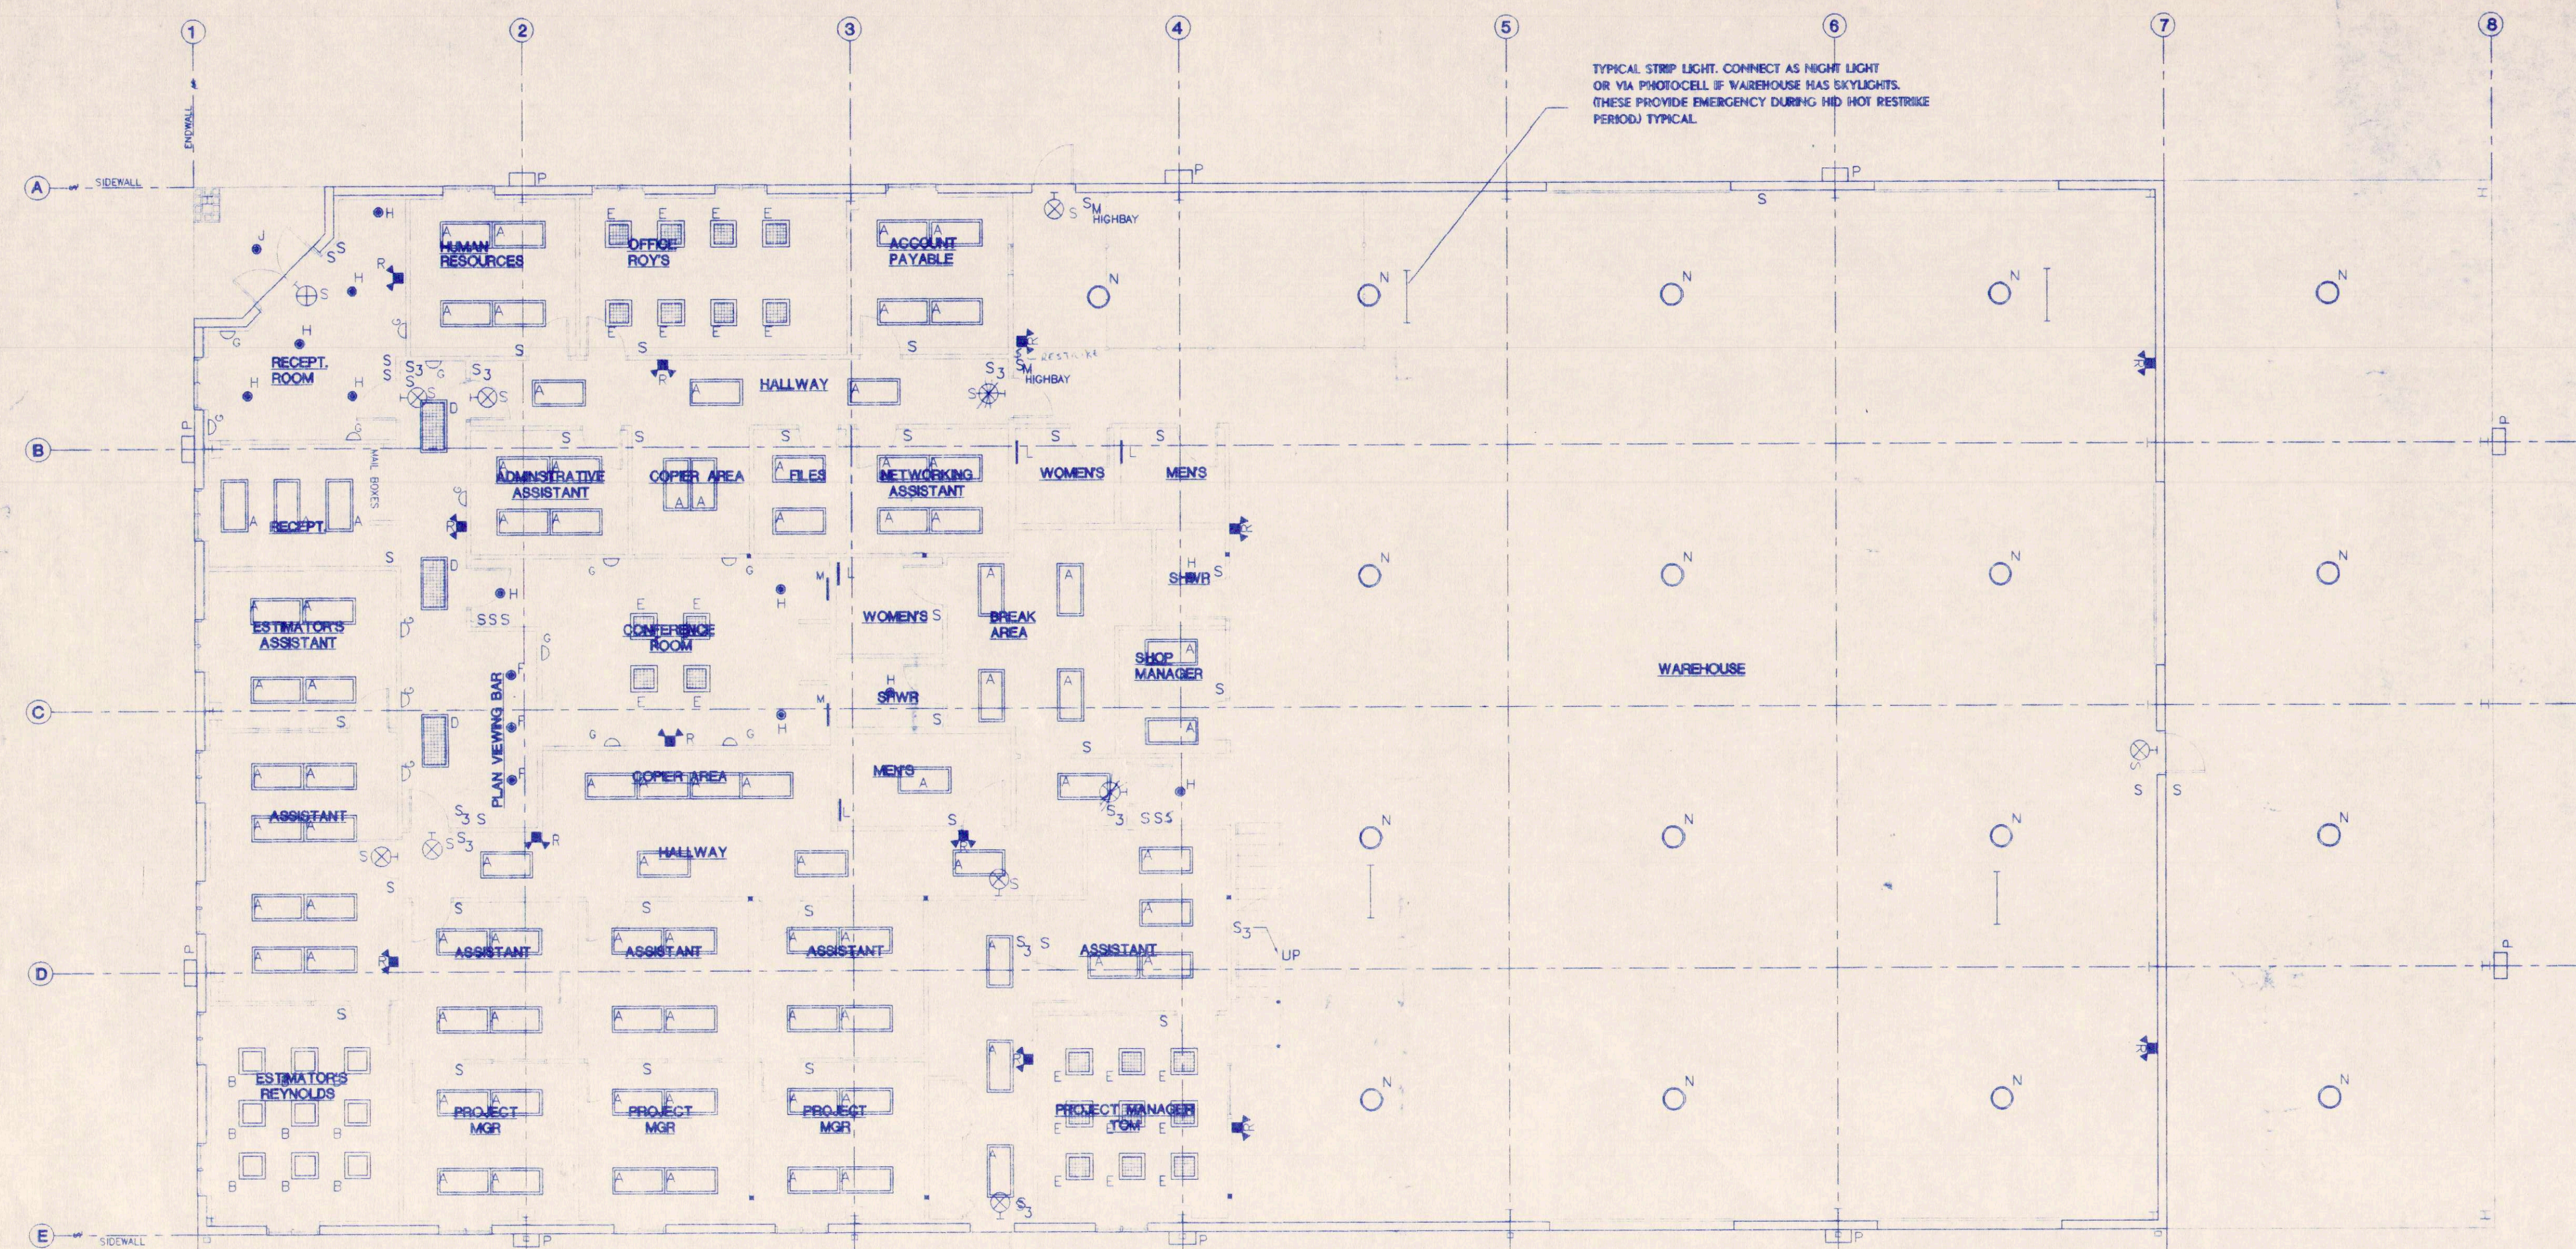

TYPICAL STRIP LIGHT. CONNECT AS NIGHT LIGHT OR VIA PHOTOCELL IF WAREHOUSE HAS SKYLIGHTS. (THESE PROVIDE EMERGENCY DURING MID NOT RESTRICTED PERIOD) TYPICAL.

CEILING LEGEND

- SUPPLY AIR DIFFUSER
- RETURN AIR DIFFUSER
- PENDANT HUNG FLUORESCENT LIGHT FIXTURE
- EXIT LIGHT (WALL MOUNTED)
- EMERGENCY EXIT LIGHT
- 400 WATT METAL HALIDE INDUSTRIAL LIGHT
- 2'-0"x4'-0" FLUORESCENT LIGHT FIXTURE
- RECESSED LIGHT
- EXHAUST FAN
- CEILING HEIGHT TAG

SERVICE CALCULATIONS:

RECEPTACLES: 130x180 VA = 10000
OFFICE LIGHTING: 6000x3Wx125% = 6700
WAREHOUSE LIGHTING: 6400x125% = 24000
OUTSIDE LIGHTING: 840x125% = 8000
EQUIPMENT: 10000 = 10500
HVAC: 45000 = 49000
TOTAL VA = TOTAL VA = 108200
(108200/208)/1.732 = 300 AMP
400 AMP SERVICE RECOMMENDED

CODE NOTES:

- ALL RECEPTACLES IN THE WAREHOUSE ARE TO BE GFI.
- MAXIMUM SIX(6) RECEPTACLES PER CIRCUIT IN OFFICE.
- MAXIMUM THREE(3) RECEPTACLES PER CIRCUIT IN WAREHOUSE.
- ALL OUTSIDE RECEPTACLES TO BE GFI.
- PER 99 NEC AND CODE LETTER "J"

POWER DESIGNER:

TONY DINATALE
A&D ELECTRIC, INC
1153 10TH STREET #E
CLERMONT, FL 34711

ENGINEER:

ALEX PIPER, P.E.
1226 TURNER ROAD
WINTER PARK, FL 32789

SWITCHING NOTES:


- S SINGLE POLE 48" AFF
- S³ 3-WAY POLE 48" AFF
- S⁴ 4-WAY POLE 48" AFF
- S^D DIMMER
- S^M MOMENTARY SWITCH

1 LIGHTING PLAN
SCALE: 1/8" = 1'-0"


ID	MANUF	CATALOG NO.	No.	LAMP	FINISH	MOUNTING	REMARKS
A	COLUMBIA	J24232QFSA12EB8120	2	FL 32	WHITE	LAY-IN	PRISMATIC
B	COLUMBIA	J22232UGFSA12EB8120	2	FL 32	WHITE	LAY-IN	PRISMATIC
C	COLUMBIA	J24232FQSA12EB8120	3	FL 32	WHITE	LAY-IN	PRISMATIC
D	COLUMBIA	VP24232GND036SEB8120	2	FL 32		LAY-IN	PARABOLIC
E	COLUMBIA	VP22322UGMA33EB8120	3	FL 32		LAY-IN	PARABOLIC
F	HALO	H803 CAN. 810 TRIM	2	FL 26	SPEC/ALZAR	RECESSED	RECESSED CAN OPEN TRIM
G	HALO	H600 CAN. 1625 TRIM	1	FL 22	WHITE	RECESSED	WALL WASH
H	HALO	H802 CAN. 810 TRIM	2	FL 18	SPEC/ALZAR	RECESSED	RECESSED CAN OPEN TRIM
I	HALO	H277 CAN. 419 TRIM	1	INC 75R30	EYEBALL	RECESSED	RECESSED ADJ. EYEBALL
J	HALO	M700T 611CAN1700 TRIM	1	MPS 35	SPEC/ALZAR	RECESSED	DAMP LOCATION/PHOTO CELL
K	HALO	H803 HP CAN. 800 TRIM	1	INC 60	WHITE	RECESSED	SHOWER
L	COLUMBIA	SA217EB8120	2	FL 17	WHITE	SURFACE	VANITY
M	HUBBELL	UL117B	1	FL 17	WHITE	SURFACE	UNDER CABINET
N	GE	EH84QMOL	1	MH 400		SURFACE	HIGH BAY
P	GE	WM414030	1	MPS 400	BRONZE	SURFACE	PHOTO CELL WALLPACK
Q	COLUMBIA	CS8259EB8120	2	FL 59	WHITE	SURFACE	FLOOR STRIP
R	PRESOLITE	EMAX	2	INC 6	WHITE	SURFACE	EMERGENCY LIGHT
S	PRESOLITE	XT3RENW		LED	WHITE	SURFACE	EXIT LIGHT
T	LSI	CTM3400SMTB(208V)	1	MPS 40	BRONZE	30' CONC POLE	SHOE BOX

AS BUILT

RELEASED FOR
CONSTRUCTION (date) Aug 8 2000

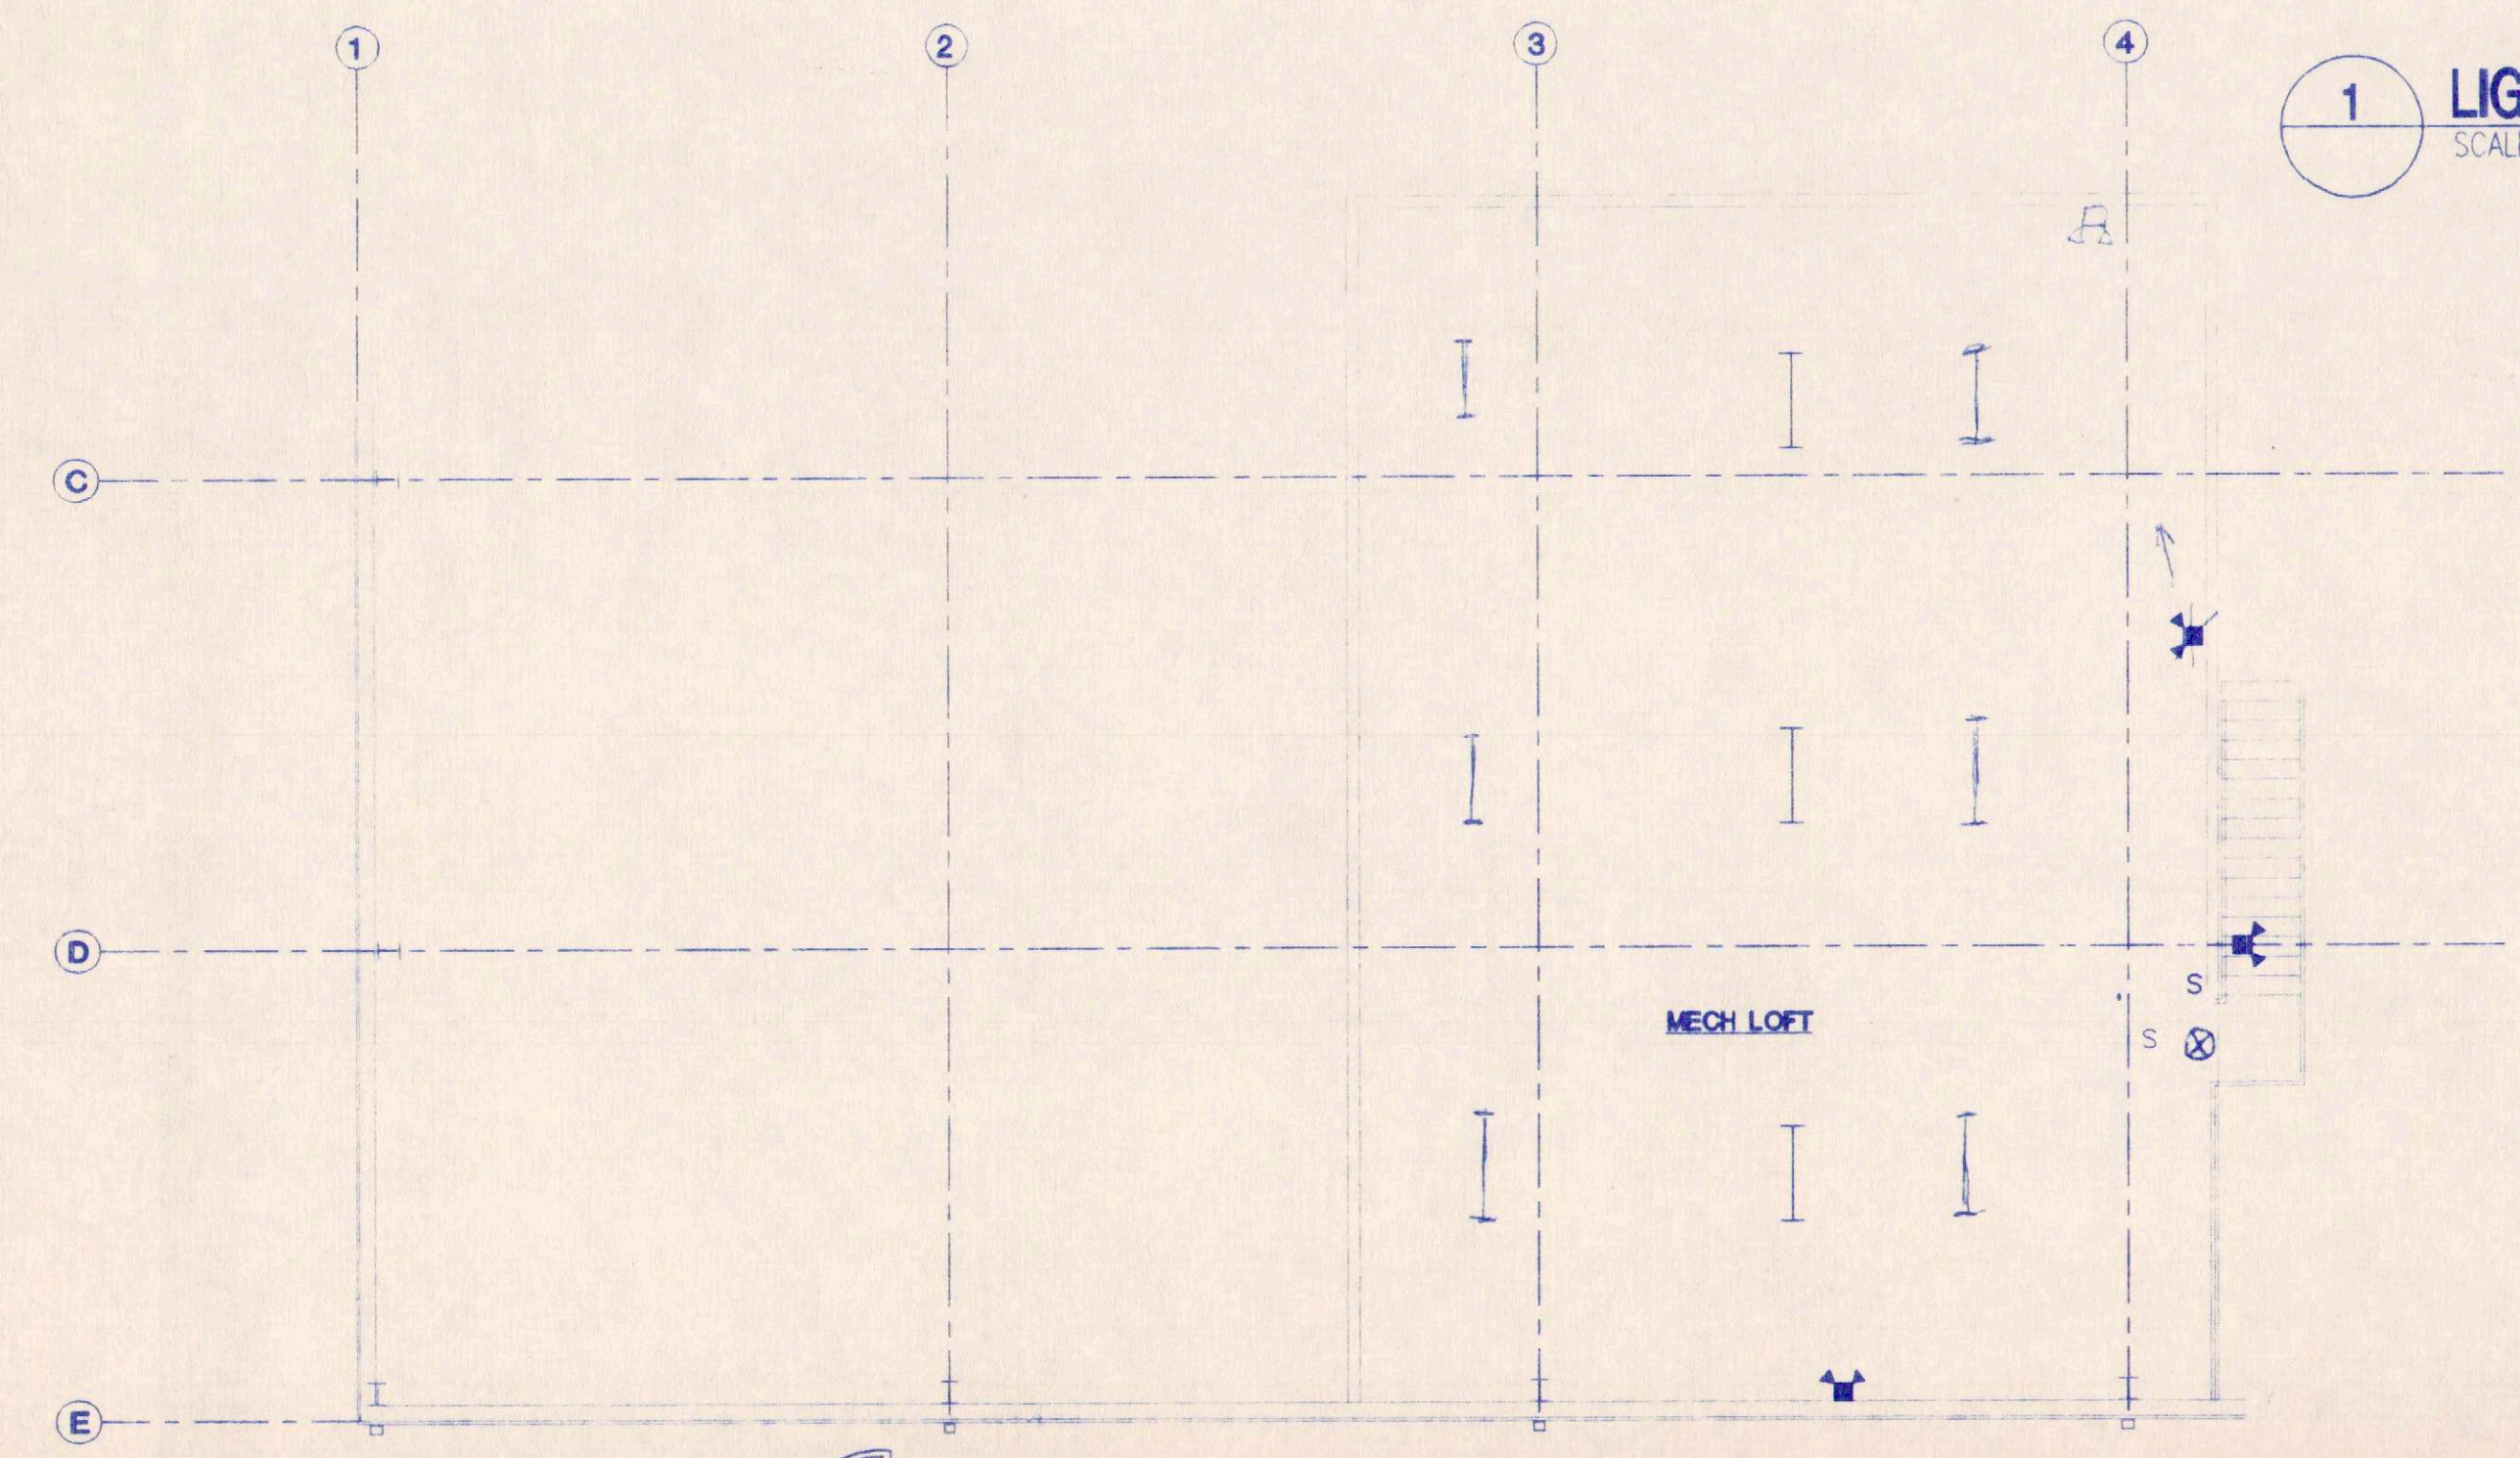

2 LIGHTING PLAN
SCALE: 1/8" = 1'-0"

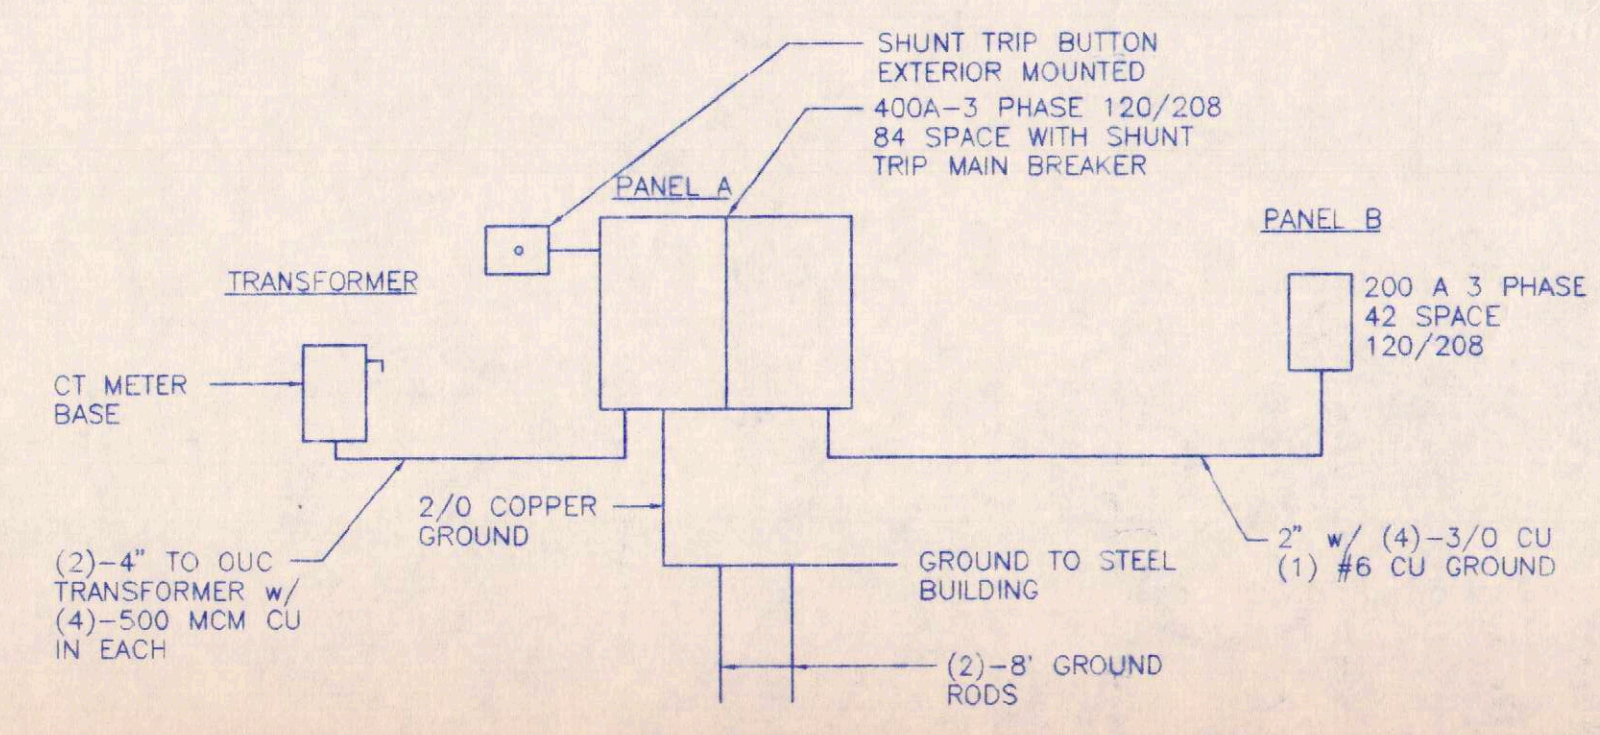

C:\UPD\107\99228\2661.dwg Wed Aug 09 13:57:49 2000 Cuhaci & Peterson Architects, Orlando, FL



Cuhaci & Peterson
Architects
1220 Alden Road
Orlando, Florida 32803
Ph. 407 228 4220
Fax. 407 228 4219

©COPYRIGHT
All reports, plans, specifications, computer files,
field notes, notes and other documents and
instruments prepared by Cuhaci & Peterson
Architects (C & P) are instruments of service
remain the property of C & P. C & P
shall retain all common law, statutory and other
reserved rights, including the copyright therein.
Any use or reproduction of this document with-
out written permission from C & P is a
violation of Federal copyright laws.


PRIME CONSTRUCTION
GROUP, INC.
ORLANDO, FL

POWER PLAN

REVISION:	
5/12/00	

JOB NO.	99228
SCALE	AS SHOWN
DATE	5/3/00
DRAWN	CRW
CHECKED	AP
DRAWING NO.	

E2

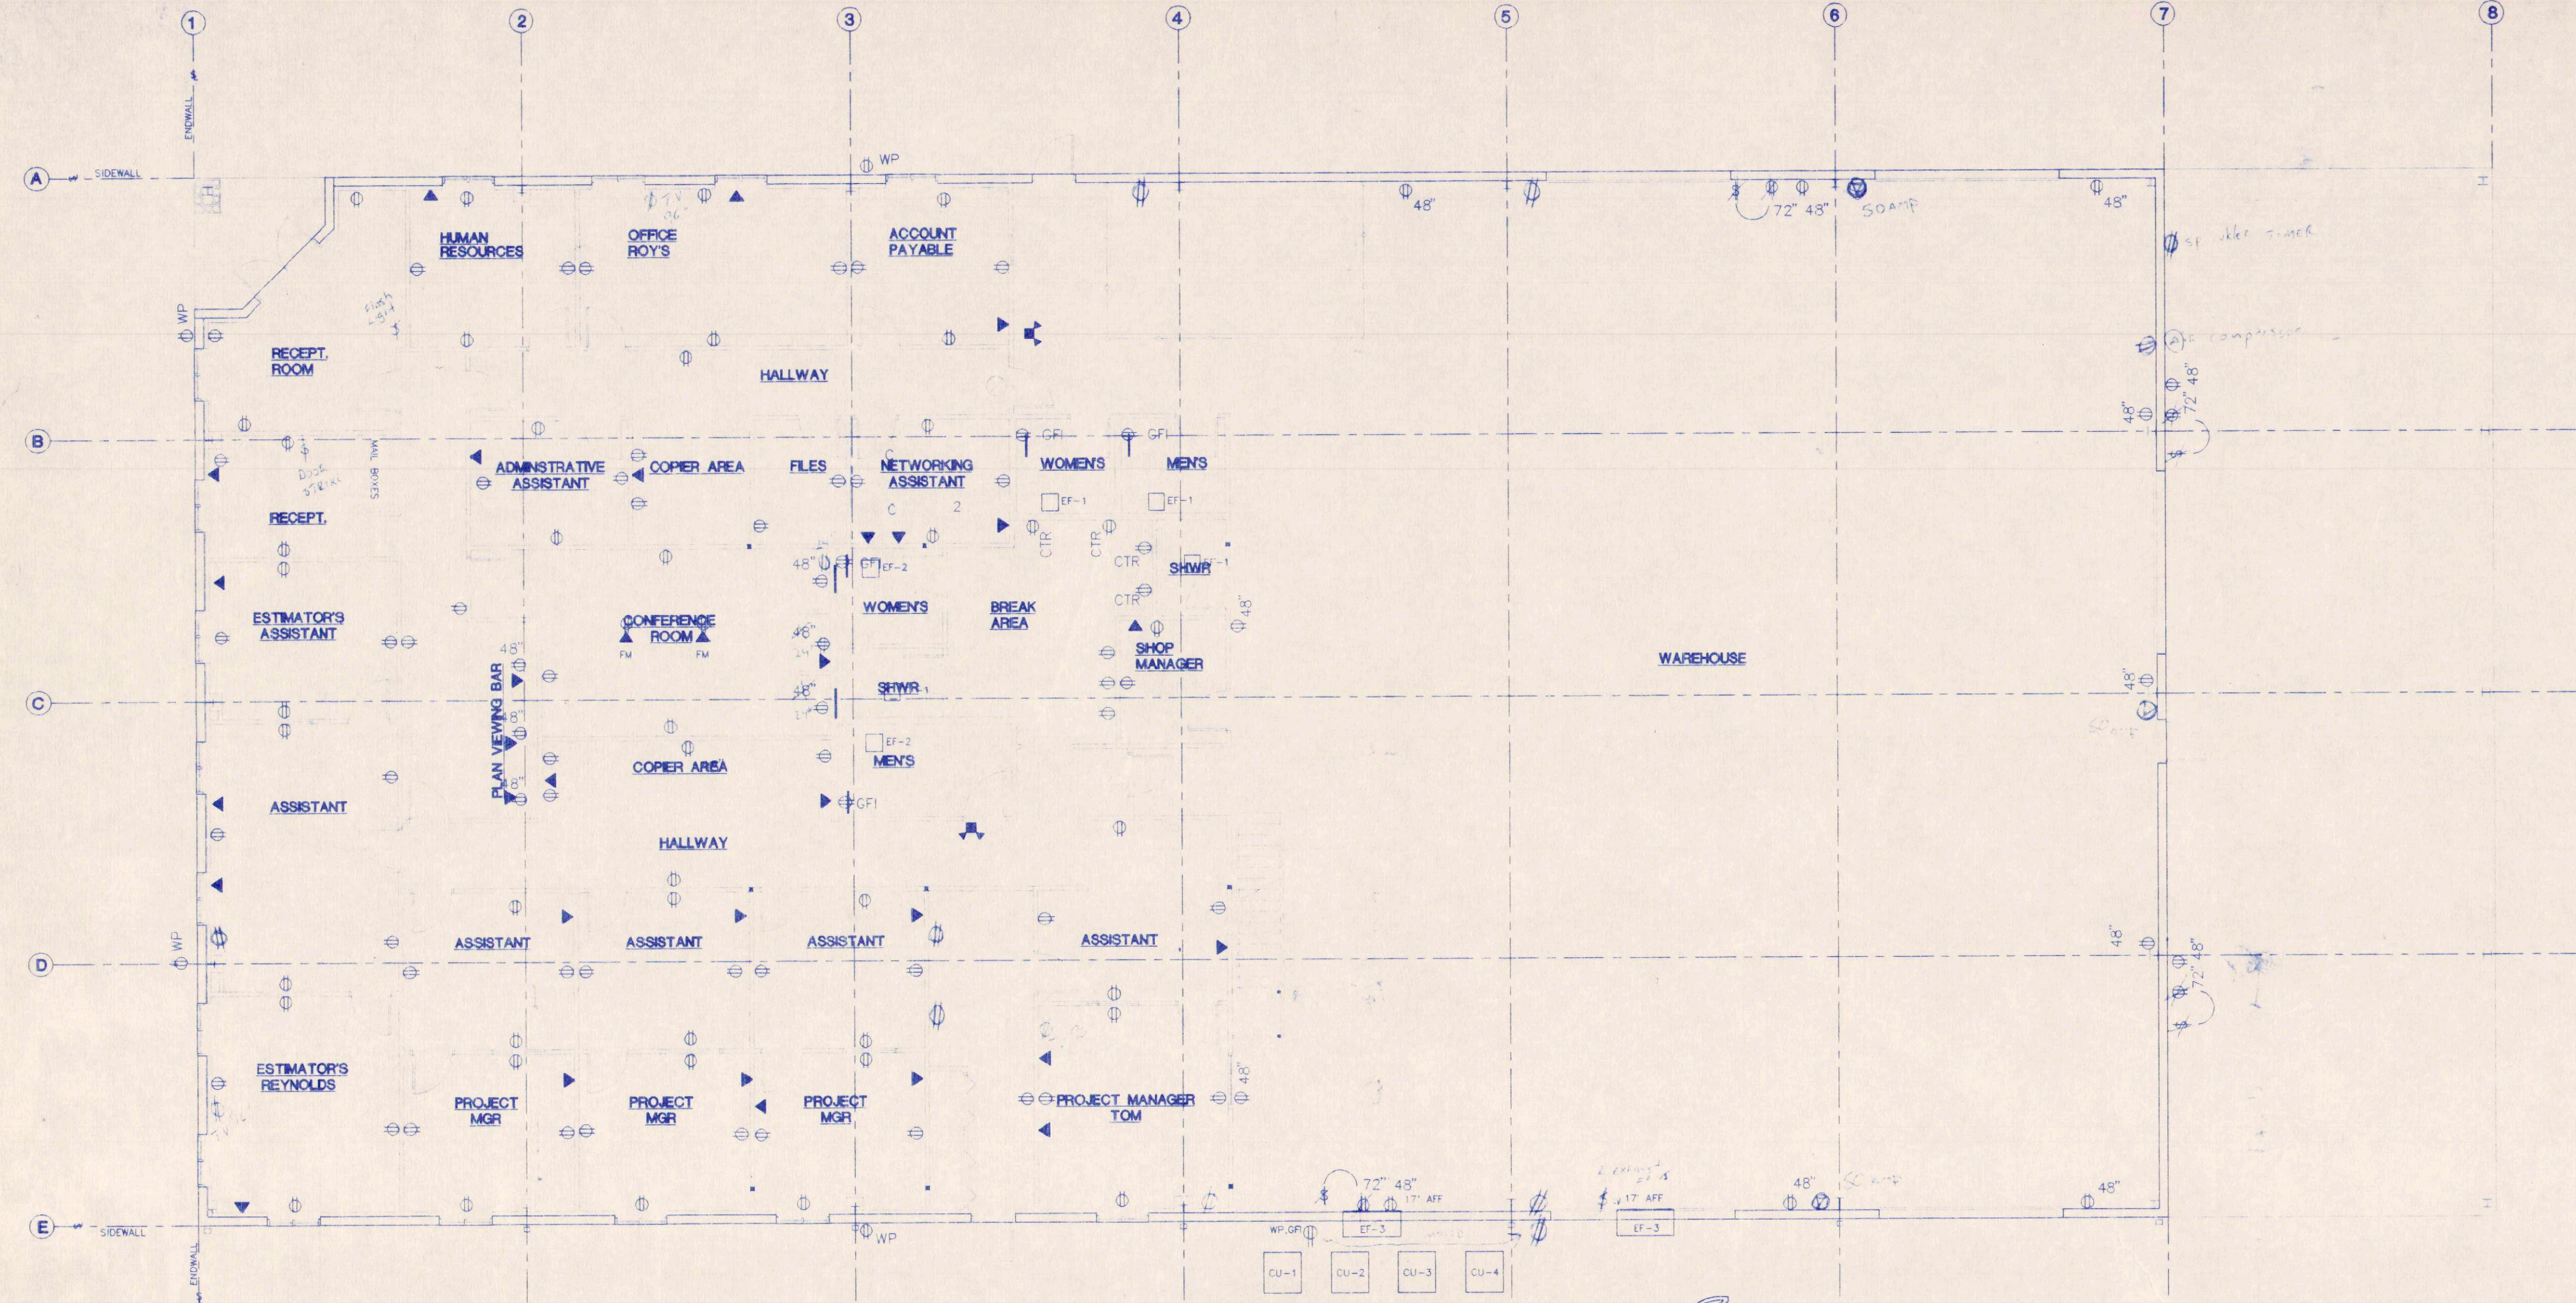

- LEGEND
- ⊕ DUPLEX 20-AMP RECEPTACLE, 18" AFF U.H.O.
 - ◀ COMMUNICATIONS OUTLET BOX, 18" AFF U.H.O. PROVIDE 3/4" TO ACCESSIBLE CEILING SPACE.

AS BUILT

1 POWER PLAN
SCALE: 1/8" = 1'-0"



GENERAL NOTE:
PER 99 NEC & CODE LETTER J

HVAC EQUIPMENT ELECTRICAL CHARACTERISTICS


MARK	VOLT	PH	MOTORS	HEAT	PLA	LRA	MCA	MOCF	MANUF	MODEL	SIZE	LOCATION
AHU-1	208	1	1/2 HP	10 KW	19.9	15.0	66	70	CARRIER	FB4AHF042	1400 CFM	MECH. LOFT
CU-1	208	1	0.8 AMP				26.3	40	CARRIER	FB1XB042	15 TON	ON GRADE
AHU-2	208	1	1/2 HP	73 KW			50	50	CARRIER	FB4AHF090	1000 CFM	MECH. LOFT
CU-2	208	1	0.8 AMP		18.7	75.0	17.9	25	CARRIER	FB1XB090	25 TON	ON GRADE
AHU-3	208	1	1/4 HP	6 KW			40	40	CARRIER	FB4AHF024	800 CFM	MECH. LOFT
CU-3	208	1	0.5 AMP		11.2	61.0	14.3	20	CARRIER	FB1XB024	2 TON	ON GRADE
AHU-4	208	1	1/2 AMP	8 KW			24	60	CARRIER	400H007	2400 CFM	MECH. LOFT
CU-4	208	1	1/2 AMP		19	142.0	25.6	35	CARRIER	FB4AHF070	6 TON	ON GRADE
EF-1	120	1	1.0 AMP				1	20	GREENHECK	SP-107	120 CFM	TOILET
EF-2	120	1	1.0 AMP				1	20	GREENHECK	SP-125	200 CFM	TOILET
EF-3	120	1	1/2 HP				7	20	GREENHECK	SPF-36	4000 CFM	WAREHOUSE

- NOTES:
1. RLA AND LRA ARE FOR THE UNIT COMPRESSOR ONLY, MCA AND MOCF ARE FOR THE ENTIRE UNIT.
 2. ALL AIR HANDLERS AND CONDENSING UNITS SHALL HAVE A SINGLE POINT CONNECTION.
 3. VERIFY UNIT NAMEPLATE PRIOR TO ORDERING MATERIALS OR ROUGH-IN. WHEN HACR RATED CB'S MATCH UNIT NAMEPLATES EXACTLY, THEN FUSES ARE NOT REQUIRED IN DISCONNECTS.
 4. VERIFY EXHAUST FANS ARE THERMALLY PROTECTED. OTHERWISE PROVIDE MOTOR STARTERS.
 5. VERIFY MECHANICAL SUBMITTAL DATA PRIOR TO ORDERING MATERIALS.

RELEASED FOR
CONSTRUCTION (date) 5/12/00

2 POWER PLAN
SCALE: 1/8" = 1'-0"



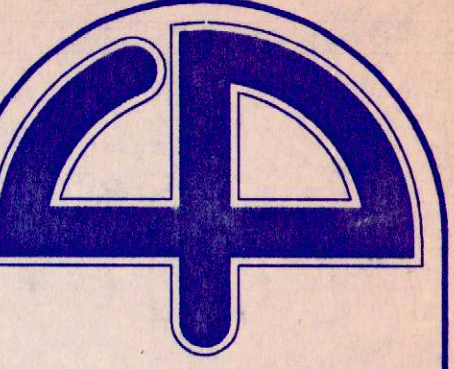

Cuhaci & Peterson
Architects

1220 Alden Road
Orlando, Florida 32803
Ph. 407.228.4220
Fax. 407.228.4219

© COPYRIGHT
All reports, plans, specifications, computer files,
field data, notes and other documents and
instruments prepared by Cuhaci & Peterson
Architects C & P are instruments of service
remain the property of C & P. C & P
shall retain all rights, including the copyright therein.
Any use or reproduction of this document with-
out written permission from C & P is a
violation of Federal copyright laws.

PRIME CONSTRUCTION
GROUP, INC.
ORLANDO, FL.

JOB TITLE


FLOOR PLAN -
HVAC

DRAWING TITLE

REVISION	
01 MAY 2000	OWNER COMMENTS
02 JUNE 2000	OWNER COMMENTS
03 JULY 2000	REVISIONS

JOB NO.	98000
SCALE	1/8" = 1'-0"
DATE	1-1-1998
DRAWN	RIV
CHECKED	JAA
DRAWING NO.	


M-I

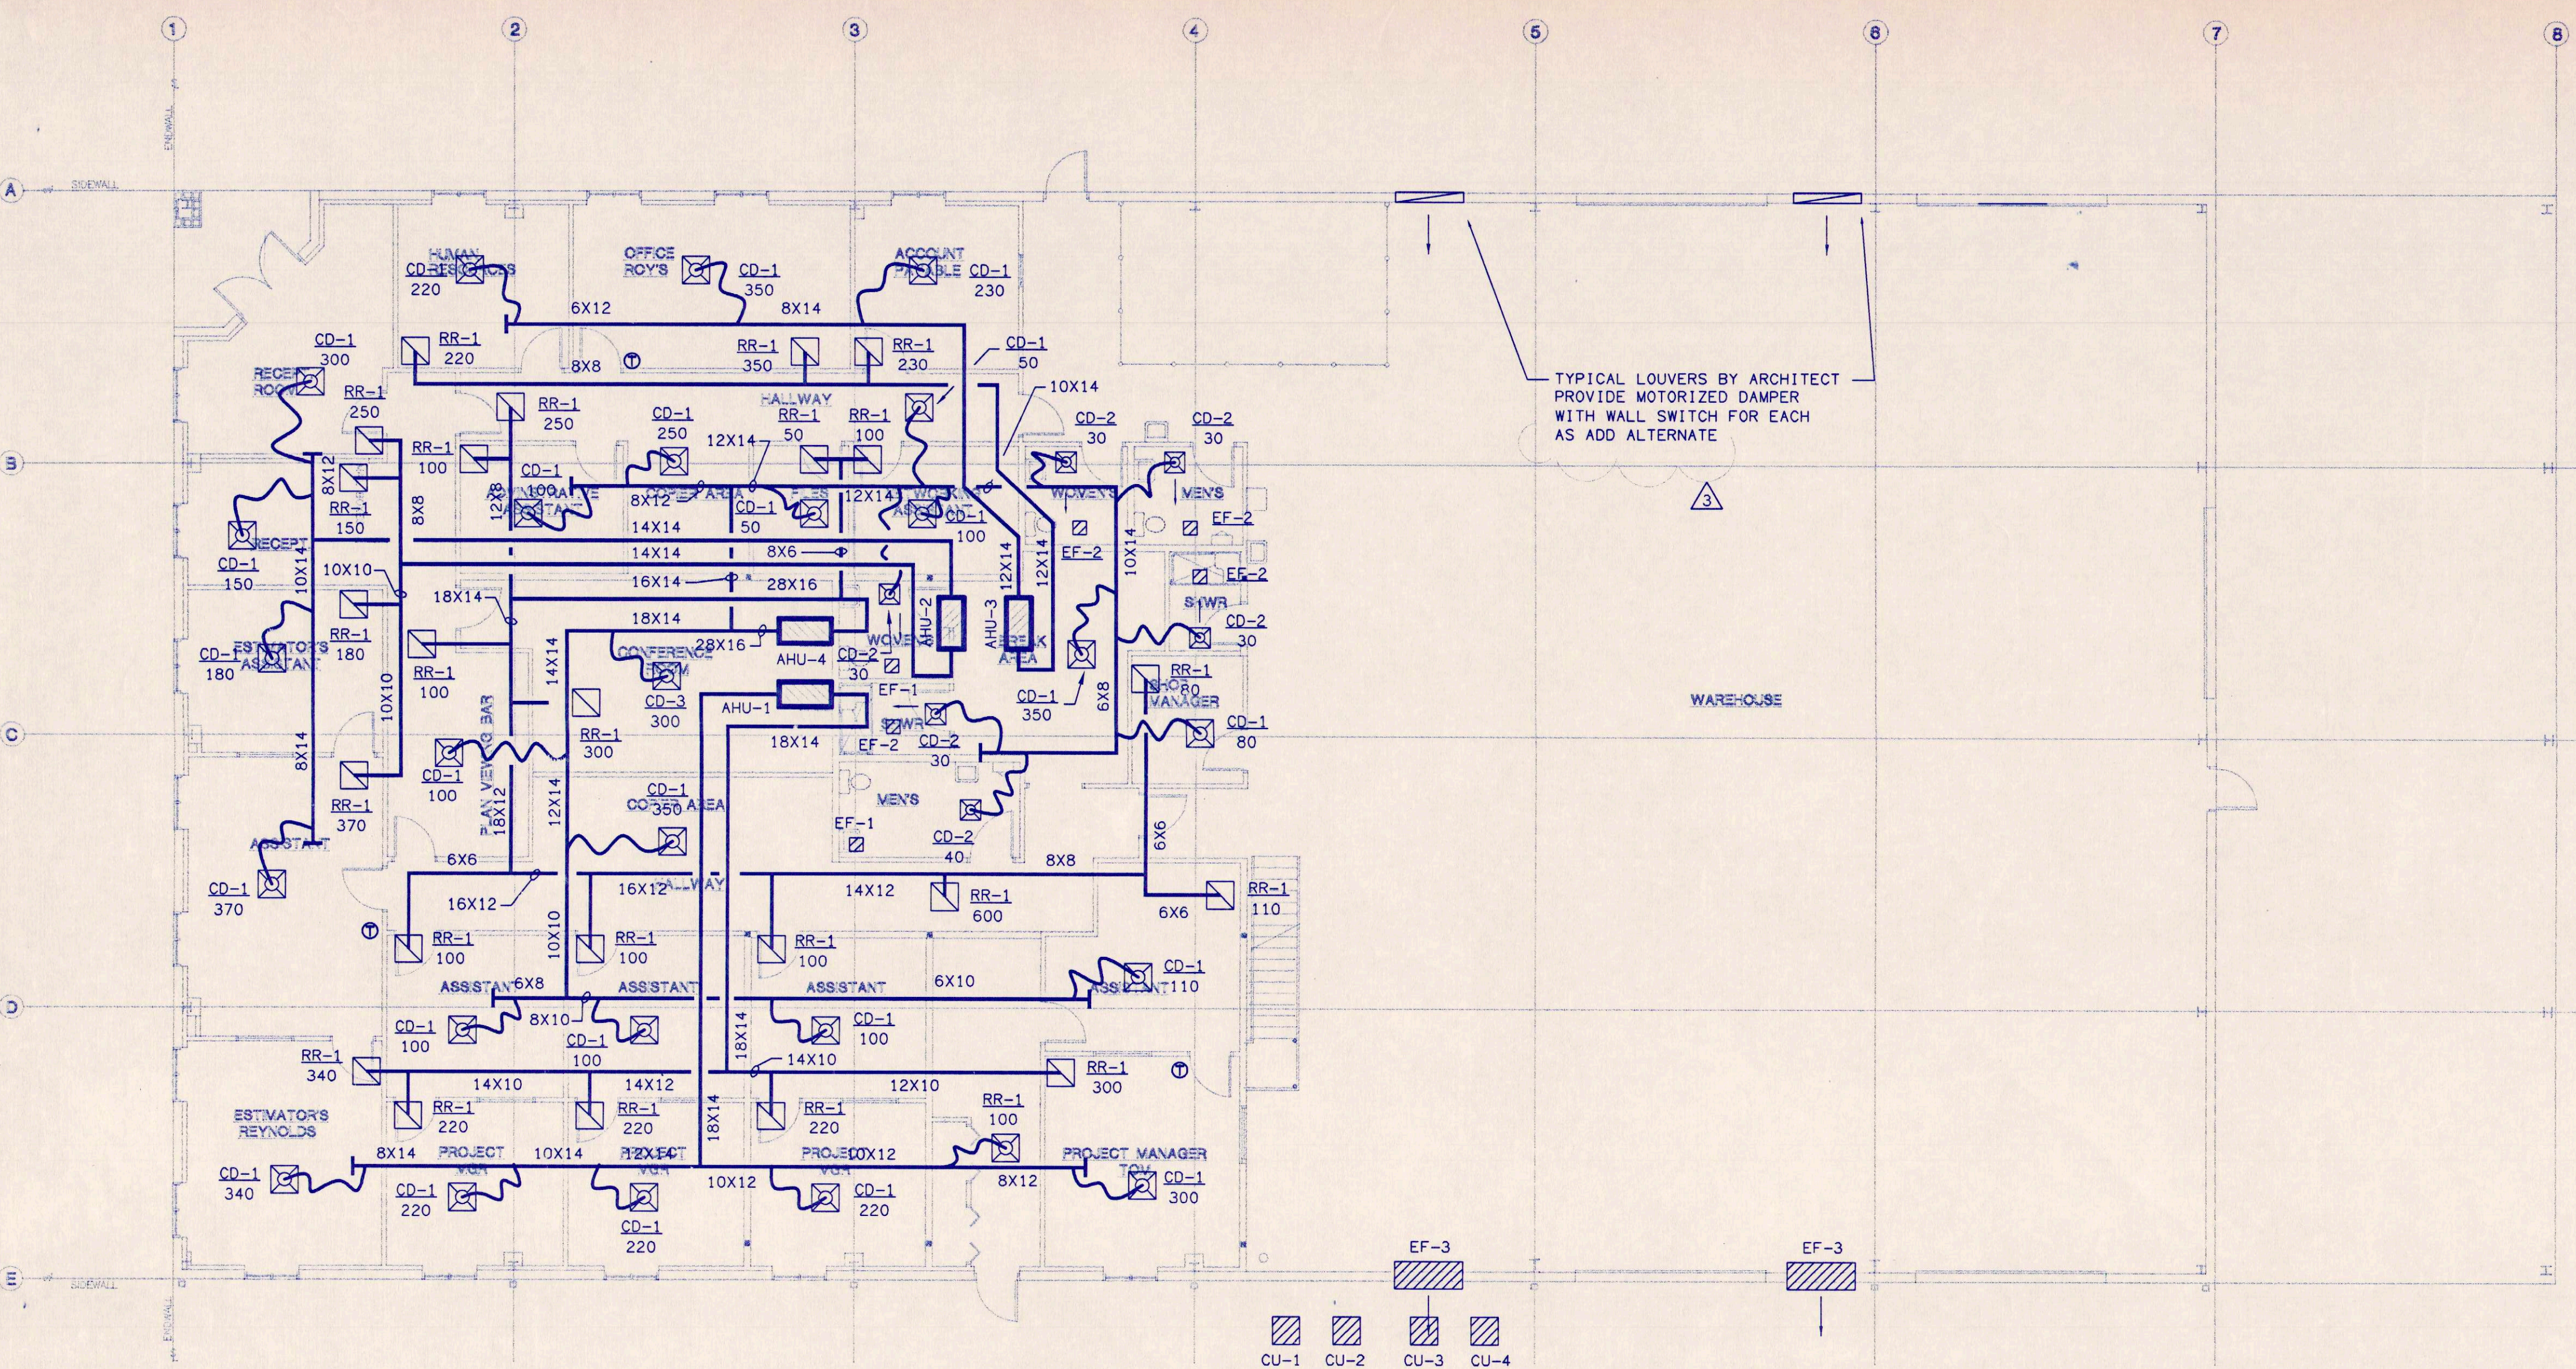

TYPICAL LOUVERS BY ARCHITECT
PROVIDE MOTORIZED DAMPER
WITH WALL SWITCH FOR EACH
AS ADD ALTERNATE

WAREHOUSE

CU-1 CU-2 CU-3 CU-4

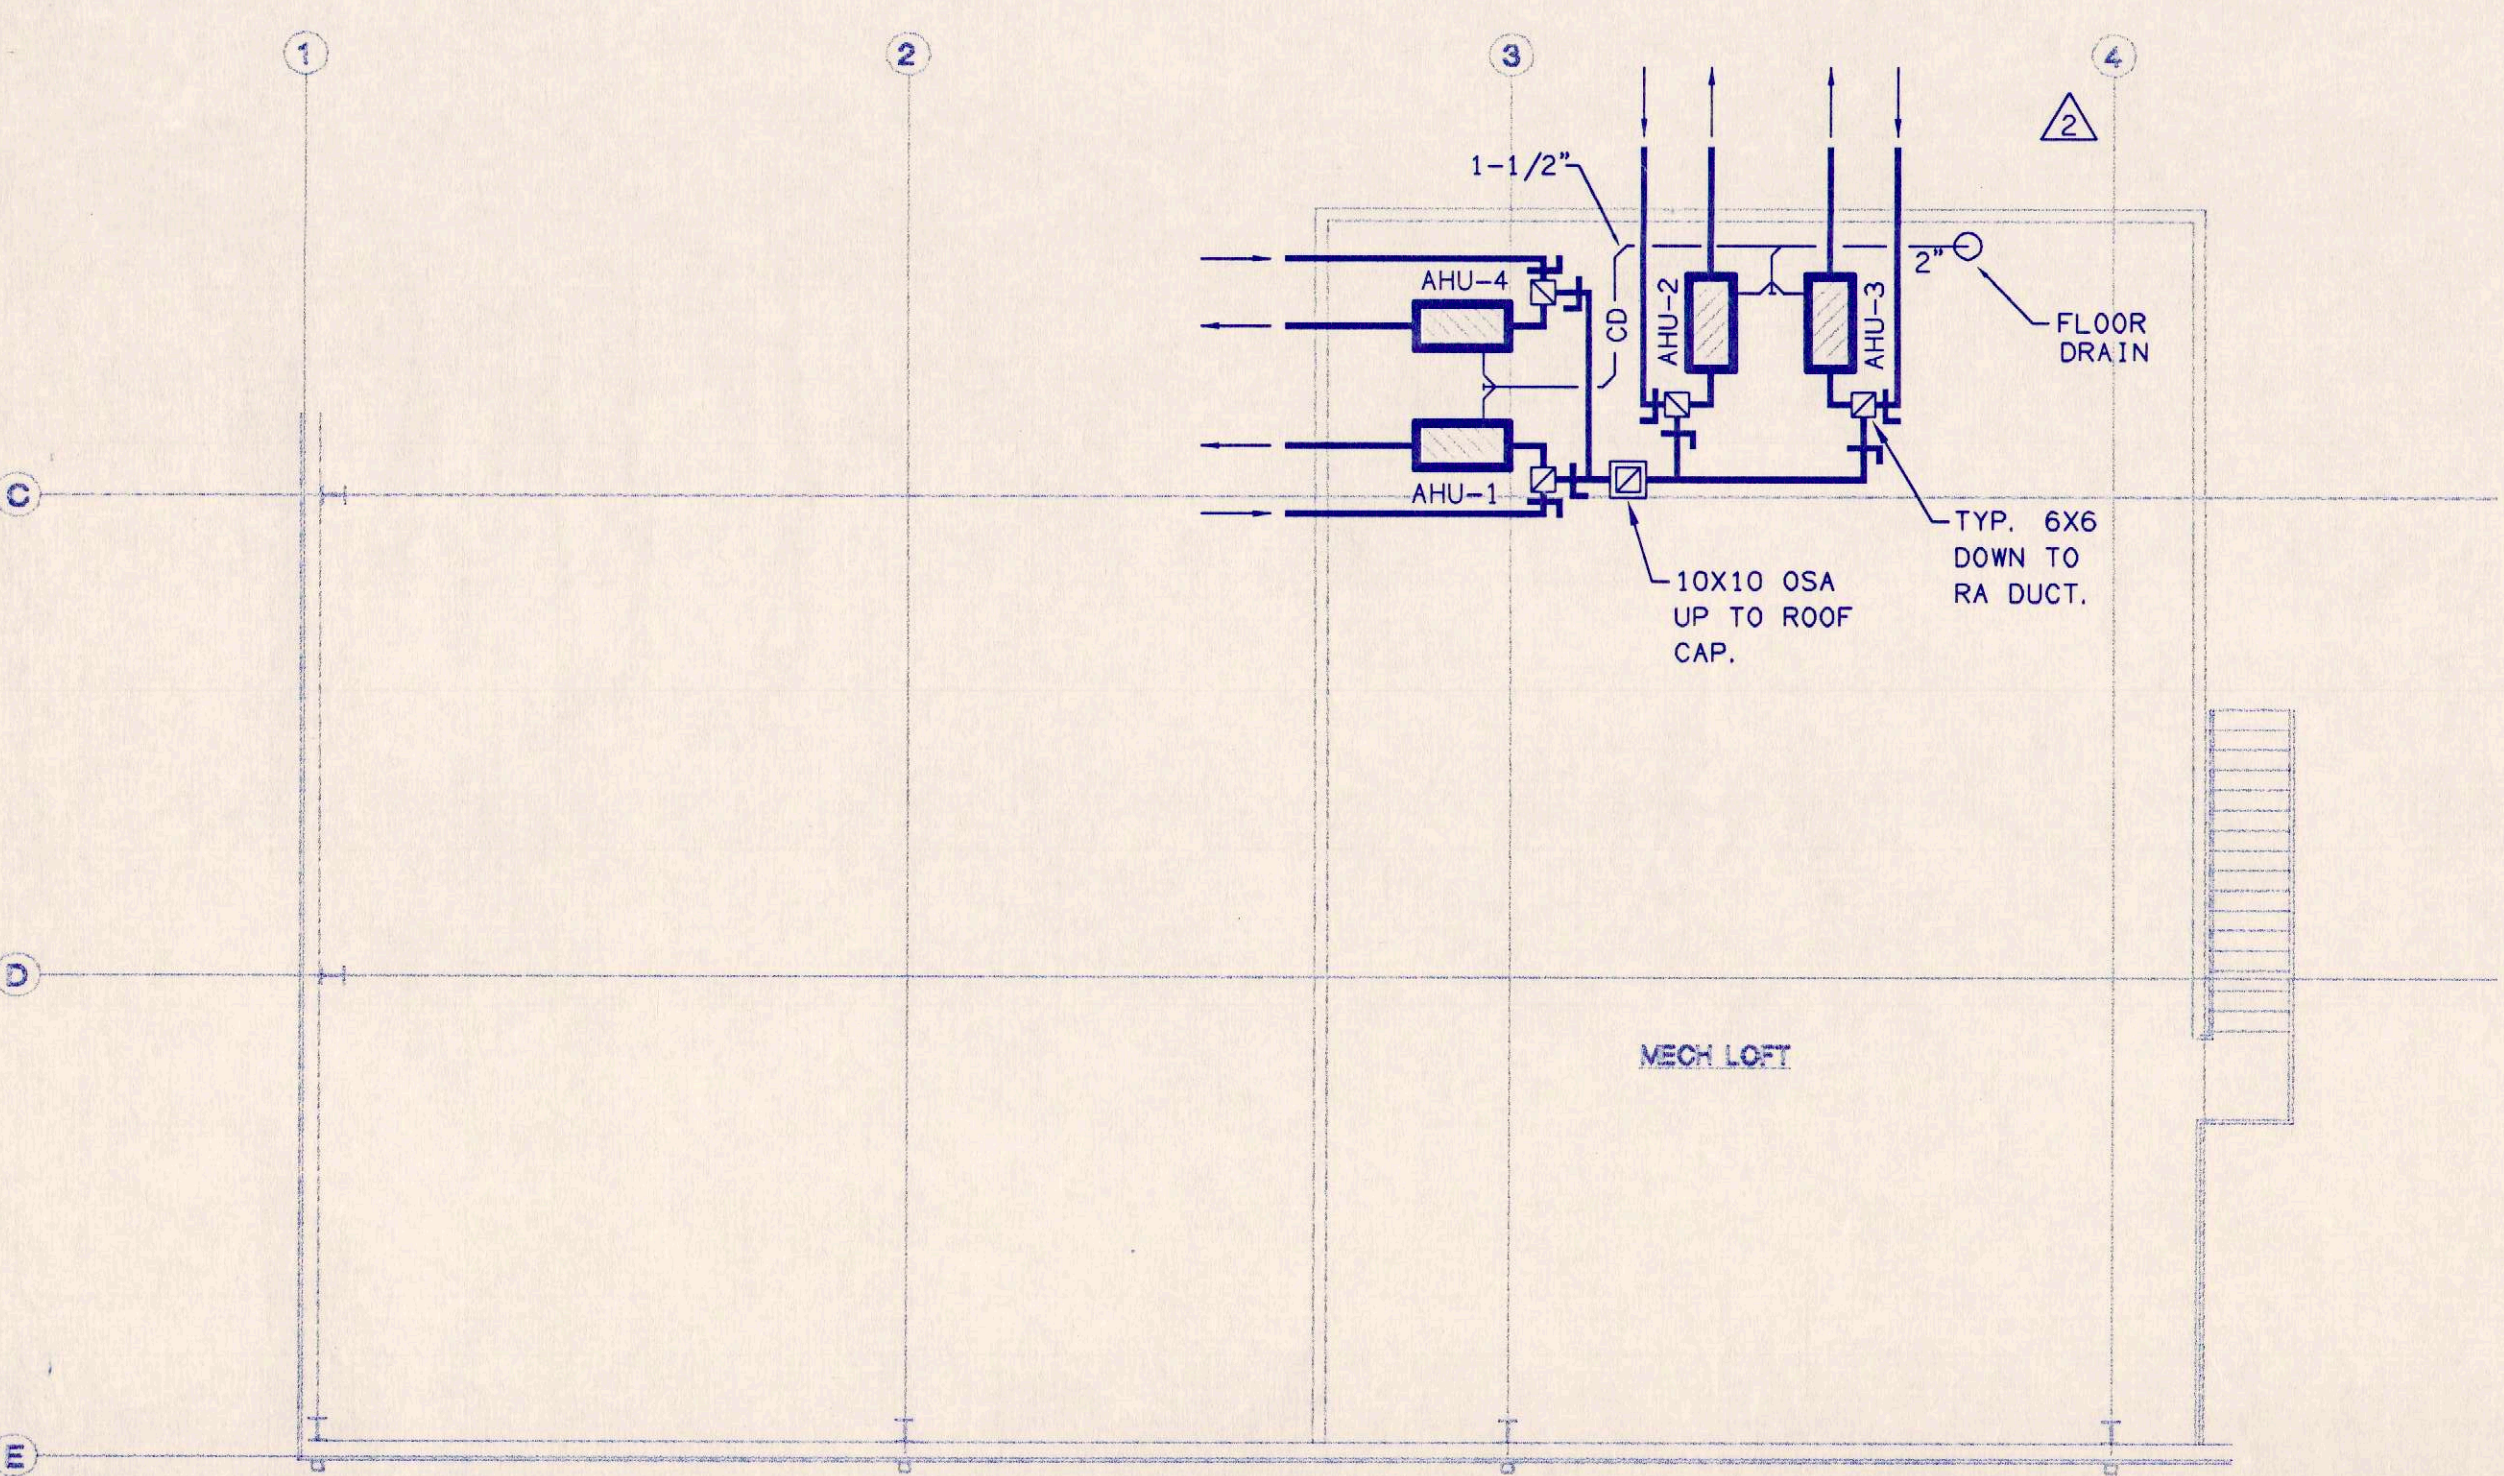


FLOOR PLAN - HVAC
1/8" = 1'-0"

JOHN ANTHONY ANDARY & ASSOCIATES
CONSULTING ENGINEERS
P.O. BOX 3634, WINTER PARK, FLORIDA 32789
407.366.7256 OFFICE / 407.366.7146 FAX

RELEASED FOR
CONSTRUCTION (date) 1/1/2000

AS BUILT

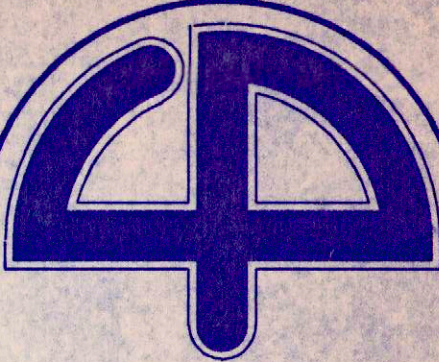

Cuhaci & Peterson
Architects

1220 Alden Road
Orlando, Florida 32803
Ph. 407 228 4220
Fax. 407 228 4219

© COPYRIGHT
All reports, plans, specifications, computer files, field data, notes and other documents and instruments prepared by Cuhaci & Peterson Architects (C & P) as instruments of service remain the property of C & P. C & P shall retain all common law, statutory and other reserved rights, including the copyright therein. Any use or reproduction of this document without written permission from C & P is a violation of Federal copyright laws.

PRIME CONSTRUCTION
GROUP, INC.
ORLANDO, FL.

JOB TITLE

HVAC - SCHEDULE &
DETAILS

DRAWING TITLE

REVISION :	△
13 MAY 2000	△
OWNER COMMENT	△
	△
	△
	△

JOB NO.	98000
SCALE	NOT TO SCALE
DATE	1-1-1998
DRAWN	RIV
CHECKED	JAA
DRAWING NO.	

M-2

GENERAL NOTES - HVAC (CONT.)

21. RIGID SUPPLY AND RETURN DUCTWORK SHALL BE R-6 MANSVILLE "SUPERDUCT" OR APPROVED EQUAL. OUTSIDE AIR DUCTWORK SHALL BE SHEETMETAL WITH R-6 INSULATION WRAP. EXHAUST DUCTWORK SHALL BE SHEETMETAL AND SHALL NOT BE INSULATED.
22. FLEXIBLE ROUND SUPPLY AIR DUCTWORK SHALL BE CLASS 1 WITH MINIMUM R-6 INSULATION AND INTERNAL PLASTIC LAMINATE LINING, FLEXMASTER TYPE 9M OR APPROVED EQUAL. PROVIDE SPIN-IN FITTING WITH AIR SCOOP AND LOCKING VOLUME DAMPER AT ALL FLEXIBLE BRANCH DUCT CONNECTIONS TO SUPPLY AIR DUCT.
23. EF-1 : NEW CEILING MOUNTED EXHAUST FAN, GREENHECK MODEL SP-125 OR APPROVED EQUAL. EXHAUST AIR = 200 CFM @ 0.15" E.S.P. MAX SONES = 5.0. FAN MOTOR = 1.0 AMPS. VOLT/PHASE = 120/1. PROVIDE SOLID STATE SPEED CONTROLLER. PROVIDE WALL MOUNTED ON/OFF SWITCH. PROVIDE INTEGRAL BACKDRAFT DAMPER AND EXHAUST DUCT UP TO ROOF CAP.
24. EF-2 : NEW CEILING MOUNTED EXHAUST FAN, GREENHECK MODEL SP-117 OR APPROVED EQUAL. EXHAUST AIR = 120 CFM @ 0.15" E.S.P. MAX SONES = 5.0. FAN MOTOR = 1.0 AMPS. VOLT/PHASE = 120/1. PROVIDE SOLID STATE SPEED CONTROLLER. PROVIDE WALL MOUNTED ON/OFF SWITCH. PROVIDE INTEGRAL BACKDRAFT DAMPER AND EXHAUST DUCT UP TO ROOF CAP.
25. EF-3 : WALL MOUNTED EXHAUST FAN, GREENHECK MODEL SPF-36OR APPROVED EQUAL. EXHAUST AIR = 4000 CFM @ 0.15" E.S.P. MAX SONES = 10.0. FAN MOTOR = 1/3 HP. VOLT/PHASE = 120/1. COORDINATE MOUNTING LOCATION WITH ARCHITECT. PROVIDE WALL MOUNTED ON/OFF SWITCH. PROVIDE INTEGRAL BACKDRAFT DAMPER AND OSHA MOTOR SIDE GUARD.
26. AIR HANDLING UNITS : PROVIDE NEW HORIZONTAL UNITS WITH SINGLE POINT ELECTRICAL CONNECTION, 30% FILTERS. CONDENSATE PIPING SHALL BE SCHEDULE 40 PVC. PROVIDE CONDENSATE P-TRAP AND ROUTE DRAIN, FULL SIZE OF UNIT CONNECTION, TO FLOOR DRAIN IN MECH ROOM. PROVIDE SEVEN DAY PROGRAMMABLE HEATING/COOLING THERMOSTAT BY THE UNIT MANUFACTURER, WHERE SHOWN ON PLANS. MOUNTED 48" A.F.F. PROVIDE IONIZATION SMOKE DETECTORS IN THE SUPPLY AND RETURN OF AHU-4, WITH WALL MOUNTED A/V ALARM LOCATED IN THE CORRIDOR. PROVIDE ALL OTHER AHU'S WITH A FIRESTAT IN THE RETURN TO DE-ENERGIZE THE UNIT.
27. CONDENSING UNITS : UNITS SHALL BE MOUNTED ON 6" DEEP, REINFORCED CONCRETE PAD, 4" LARGER THAN UNIT ON ALL SIDES. PROVIDE 5 YEAR COMPRESSOR WARRANTY. PROVIDE REFRIGERANT DRYER, SITE GLASS, TIME-DELAY RELAY, 5 MINUTE ANTI-RECYLING DELAY, AND THERMOSTATIC EXPANSION VALVE KIT. FURNISH, SIZE, INSULATE, AND INSTALL COPPER REFRIGERANT PIPING FROM CONDENSING UNITS TO CORRESPONDING AIR HANDLING UNIT IN STRICT ACCORDANCE WITH MANUFACTURERS RECOMMENDATIONS. INSULATION SHALL BE 1" THICK ARMAFLEX. INSTALL REFRIGERANT PIPING BELOW GRADE IN 6" ROUND PVC PIPE SLEEVE. INSULATED REFRIGERANT PIPING OUTSIDE OF THE BUILDING SHALL BE PROVIDED WITH AN ADDITIONAL ALUMINUM JACKET FOR PROTECTION.


GENERAL NOTES - HVAC

1. ALL WORK SHALL COMPLY WITH THE FOLLOWING CODES:
STANDARD BUILDING CODE.
STANDARD MECHANICAL CODE
STANDARD PLUMBING CODE
NATIONAL ELECTRICAL CODE.
FLORIDA MODEL ENERGY EFFICIENCY CODE FOR BUILDING CONSTRUCTION.
STANDARD FIRE CODE.
ALL LOCAL CODES.
2. WORK SHALL COMPLY WITH THE FOLLOWING STANDARDS:
AMERICAN SOCIETY OF HEATING, REFRIGERATION, AND AIR COND. ENGINEERS (ASHRAE).
AMERICAN SOCIETY OF MECHANICAL ENGINEERS (ASME).
AMERICAN NATIONAL STANDARDS INSTITUTE (ANSI).
AMERICAN SOCIETY FOR TESTING AND MATERIALS. (ASTM)
UNDERWRITER'S LABORATORIES, INC. (UL).
SHEET METAL AND AIR CONDITIONING CONTRACTORS NATIONAL ASSOCIATION (SMACNA).
NATIONAL ELECTRICAL MANUFACTURER'S ASSOCIATION (NEMA).
AMERICAN REFRIGERATION INSTITUTE (ARI).
ASSOCIATED AIR BALANCE COUNCIL (AABC).
AIR MOVEMENT AND CONTROL ASSOCIATION (AMCA).
NATIONAL FIRE PROTECTION ASSOCIATION (NFPA).
AMERICAN SOCIETY OF PLUMBING ENGINEERS (ASPE)
3. ALL EQUIPMENT, MATERIAL AND LABOR SHALL BE GUARANTEED FOR A MINIMUM PERIOD OF 12 MONTHS FROM THE DATE OF FINAL COMPLETION AND ACCEPTANCE. ANY DEFECTS ARISING WITHIN THIS PERIOD SHALL BE REPAIRED AND/OR REPLACED AT NO COST TO THE OWNER.
4. ALL CONTROL WIRING, CONDUIT AND HARDWARE TO COMPLETE THE H.V.A.C. CONTROL SYSTEMS SHALL BE FURNISHED AND INSTALLED UNDER DIVISION 15 - MECHANICAL OF THESE CONTRACT DOCUMENTS. PROVIDE ALL CONTROL EQUIPMENT, MOTOR STARTERS, RELAYS, LINE VOLTAGE CONTROLS, TRANSFORMERS, LOW VOLTAGE CONTROLS AND DEVICES NECESSARY FOR THE OPERATION OF HEATING, AIR CONDITIONING AND VENTILATION SYSTEMS. THE SIZE, LOCATION, AND ELECTRICAL REQUIREMENTS OF ALL EQUIPMENT INSTALLED UNDER DIVISION 15 (MECHANICAL) SHALL BE COORDINATED WITH DIVISION 16 (ELECTRICAL) AND ALL OTHER TRADES, PRIOR TO BID AND CONSTRUCTION.
5. FURNISH OWNER WITH H.V.A.C. AIR BALANCING REPORT, BY AN INDEPENDENT AIR BALANCE CONTRACTOR WITH MEMBERSHIP IN A.A.B.C.
6. THE CONTRACTOR IS EXPECTED TO ORDER ALL MATERIALS IN SUFFICIENT TIME TO AVOID DELAYING THE COMPLETION OF THE PROJECT. DELAY IN DELIVERIES WILL NOT BE CONSIDERED A JUSTIFIABLE REASON FOR SUBMISSION OF SUBSTITUTE MATERIALS.
7. THIS CONTRACTOR SHALL SUBMIT EQUIPMENT CUT-SHEETS TO THE ARCHITECT FOR REVIEW PRIOR TO PURCHASE OR INSTALLATION OF ANY MATERIALS OR EQUIPMENT FOR THIS PROJECT.
8. ALL DUCTWORK SHALL BE FURNISHED AND INSTALLED IN STRICT ACCORDANCE WITH SMACNA STANDARDS. RIGID BRANCH DUCTS SHALL HAVE 45 DEGREE TAP AND BALANCING DAMPER. ALL DUCT ELBOWS SHALL HAVE TURNING VANES. PROVIDE SPIN-IN FITTING AND VOLUME DAMPER AT ALL ROUND BRANCH DUCT CONNECTIONS FROM MAIN DUCT TO DIFFUSERS. ALL SEAMS IN DUCTWORK AND DUCTWORK INSULATION SHALL BE SEALED WITH TWO LAYERS OF GLASS FABRIC AND MASTIC.
9. ALL DIVISION 15 (MECHANICAL) EQUIPMENT SHALL BE INSTALLED IN STRICT ACCORDANCE WITH THE MANUFACTURERS RECOMMENDATIONS AND APPLICABLE CODE REQUIREMENTS.
10. AHU-1 : NOMINAL 3.5 TON AIR HANDLER, CARRIER MODEL FB4ANF042, OR APPROVED EQUAL, SUPPLY AIR = 1400 CFM, OUTSIDE AIR = 100 CFM, HEAT = 10 KW, 208 V / 1 PH, FAN = 1/2 HP.
11. CU-1 : NOMINAL 3.5 TON CONDENSING UNIT, CARRIER MODEL 38TKB042, OR APPROVED EQUAL, MCA = 26.3 AMPS, MOCP = 40 AMPS, 208 V / 1 PH.
12. AHU-2 : NOMINAL 2.5 TON AIR HANDLER, CARRIER MODEL FB4ANF030, OR APPROVED EQUAL, SUPPLY AIR = 1000 CFM, OUTSIDE AIR = 100 CFM, HEAT = 7.5 KW, 208 V / 1 PH, FAN = 1/3 HP.
13. CU-2 : NOMINAL 2.5 TON CONDENSING UNIT, CARRIER MODEL 38TKB030, OR APPROVED EQUAL, MCA = 17.9 AMPS, MOCP = 25 AMPS, 208 V / 1 PH.
14. AHU-3 : NOMINAL 2 TON AIR HANDLER, CARRIER MODEL FB4ANF024, OR APPROVED EQUAL, SUPPLY AIR = 800 CFM, OUTSIDE AIR = 100 CFM, HEAT = 6 KW, 208 V / 1 PH, FAN = 1/4 HP.
15. CU-3 : NOMINAL 2 TON CONDENSING UNIT, CARRIER MODEL 38TKB024, OR APPROVED EQUAL, MCA = 14.5 AMPS, MOCP = 20 AMPS, 208 V / 1 PH.
16. AHU-4 : NOMINAL 6 TON AIR HANDLER, CARRIER MODEL 40RM007, OR APPROVED EQUAL, SUPPLY AIR = 2400 CFM, OUTSIDE AIR = 150 CFM, HEAT = 15 KW, 208 V / 3 PH, FAN = 1.3 HP.
17. CU-4 : NOMINAL 6 TON CONDENSING UNIT, CARRIER MODEL 38AK070, OR APPROVED EQUAL, MCA = 25.6 AMPS, MOCP = 35 AMPS, 208 V / 3 PH.
18. CD-1 : TYPICAL 24" X 24" SUPPLY AIR DIFFUSER, TITUS MODEL PAS OR APPROVED EQUAL. INSULATE THE BACK OF EACH DIFFUSER WITH 2" BATT INSULATION. DIFFUSERS SHALL BE 4-WAY THROW UNLESS NOTED OTHERWISE ON PLANS WITH DIRECTIONAL ARROWS. PROVIDE OPPOSED BLADE DAMPER FOR EACH DIFFUSER AND BALANCE EACH FOR THE CFM SHOWN ON THE PLANS. PROVIDE DIFFUSER NECK SIZES AND BRANCH FLEX DUCT SIZE AS SHOWN BELOW. COLOR PER ARCHITECT. CD-2 SHALL BE SAME MODEL WITH 12" X 12" FACE.
19. CD-3 : 24" X 24" VAV SUPPLY AIR GRILLE, THERMA-FUSER MODEL TB-CW OR APPROVED EQUAL. 10" ROUND NECK. COLOR PER ARCHITECT.
20. RR-1 : 24" X 24" LOUVERED RETURN AIR GRILLE, TITUS MODEL PAR OR APPROVED EQUAL. COLOR PER ARCHITECT. PROVIDE OPPOSED BLADE DAMPER.

NECK SIZE	MAX AIR FLOW
6" ROUND	100 CFM
8" ROUND	200 CFM
10" ROUND	300 CFM
12" ROUND	400 CFM
14" ROUND	500 CFM


NECK SIZE	MAX AIR FLOW
6 X 6	120 CFM
8 X 8	250 CFM
10 X 10	450 CFM
12 X 12	750 CFM
14 X 14	1200 CFM

JOHN ANTHONY ANDARY & ASSOCIATES
CONSULTING ENGINEERS
P.O. BOX 3634, WINTER PARK, FLORIDA 32789
407.366.7256 OFFICE / 407.366.7146 FAX

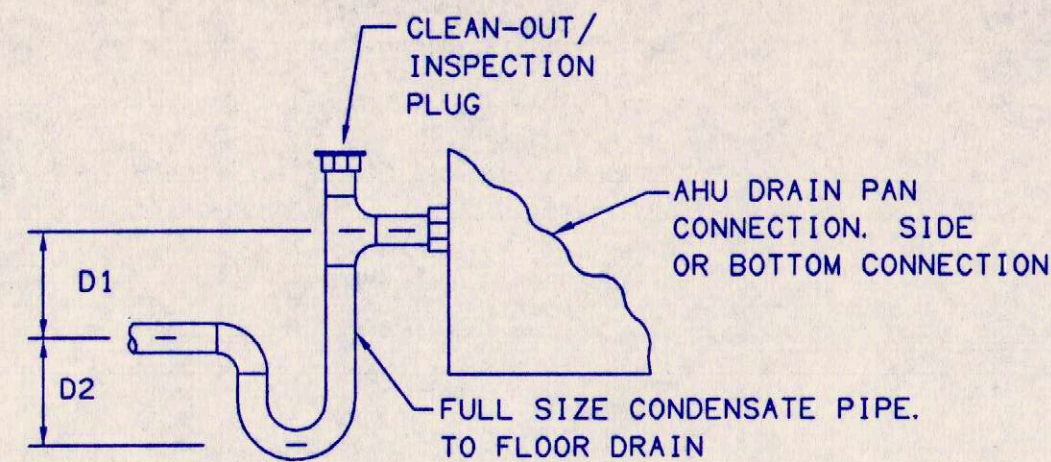


	DIMENSION D1, INCHES (MINIMUM)	DIMENSION D2, INCHES (MINIMUM)
DRAW-THROUGH AIR HANDLER	EQUAL TO FAN NEGATIVE PRESSURE, BUT NOT LESS THAN 3"	EQUAL TO FAN NEGATIVE PRESSURE, BUT NOT LESS THAN 3"
BLOW-THROUGH AIR HANDLER	2"	EQUAL TO FAN TOTAL STATIC PRESSURE, BUT NOT LESS THAN 4"

CONDENSATE DRAIN P-TRAP NOT TO SCALE

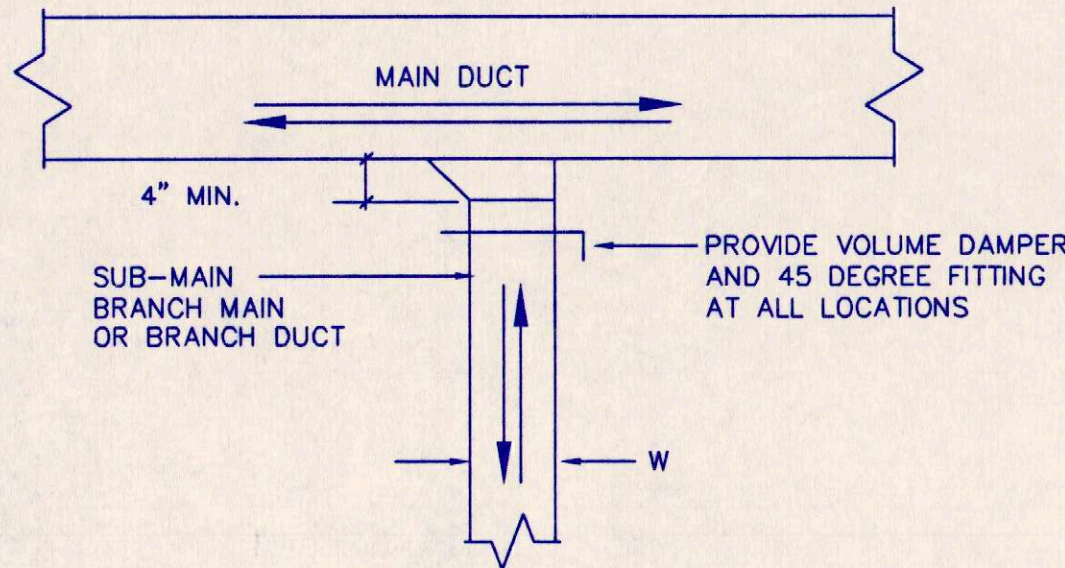


NOTE:
THE BRANCH DUCT TAKE-OFF MAY
BE USED FOR UP TO 15% OF THE
MAIN DUCT CFM ANYTIME AND UP TO
40% WHEN THE MAIN DUCT VELOCITY
IS 1000 FPM OR LESS. ALL SUPPLY,
RETURN, OUTSIDE AIR, AND EXHAUST DUCTS.


BRANCH DUCT NOT TO SCALE

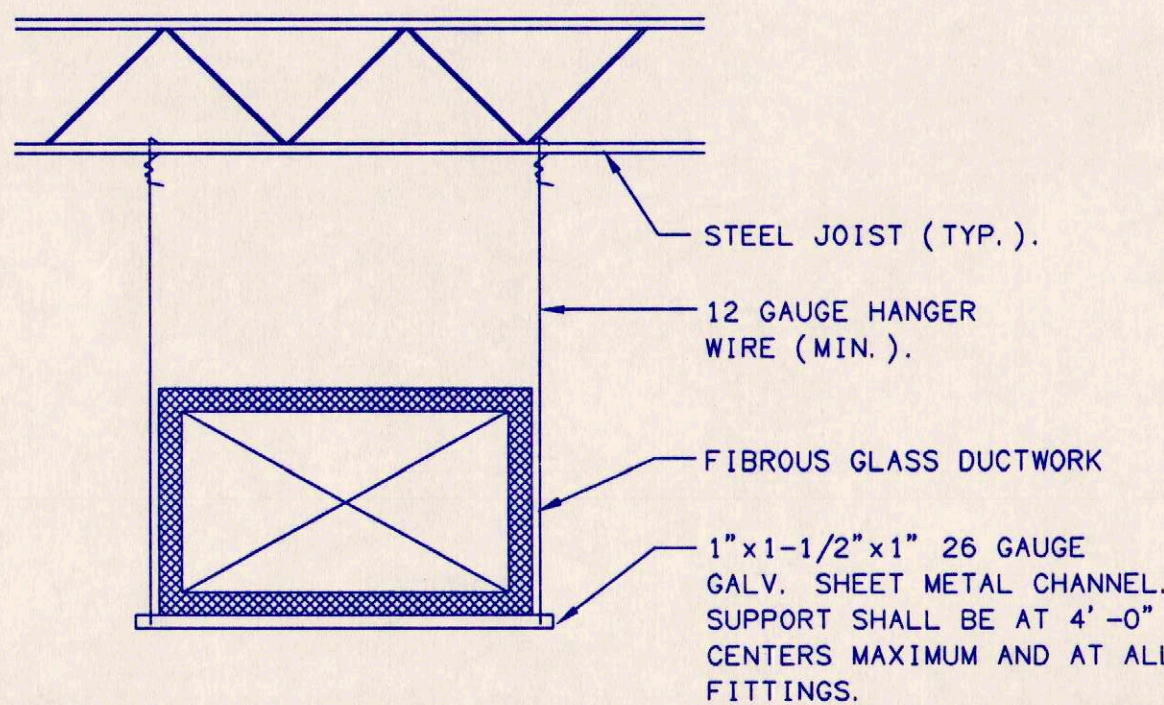

DUCTBOARD SUPPORT NOT TO SCALE




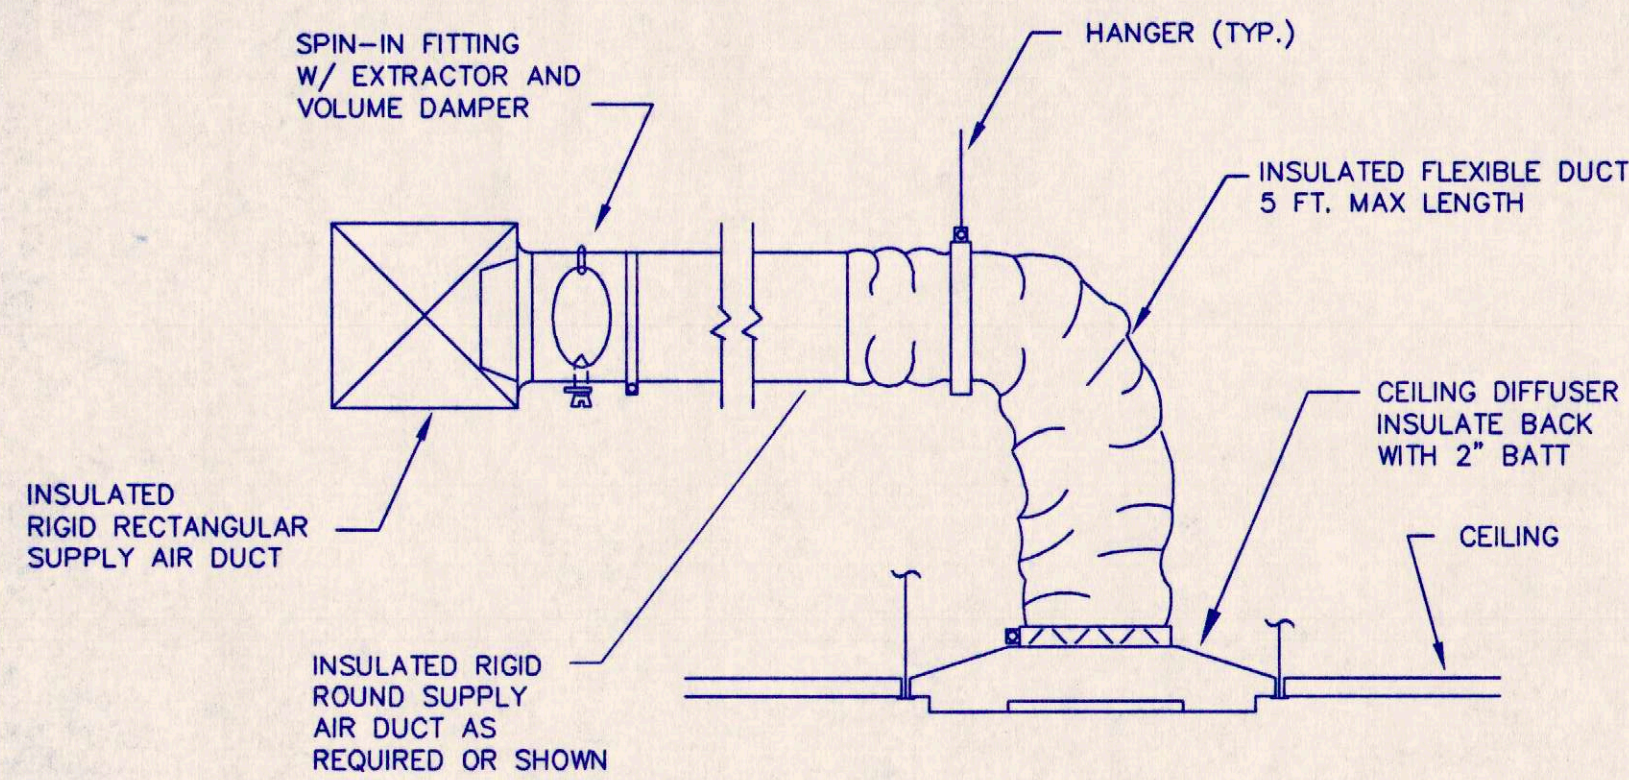


CEILING DIFFUSER AND BRANCH DUCT NOT TO SCALE

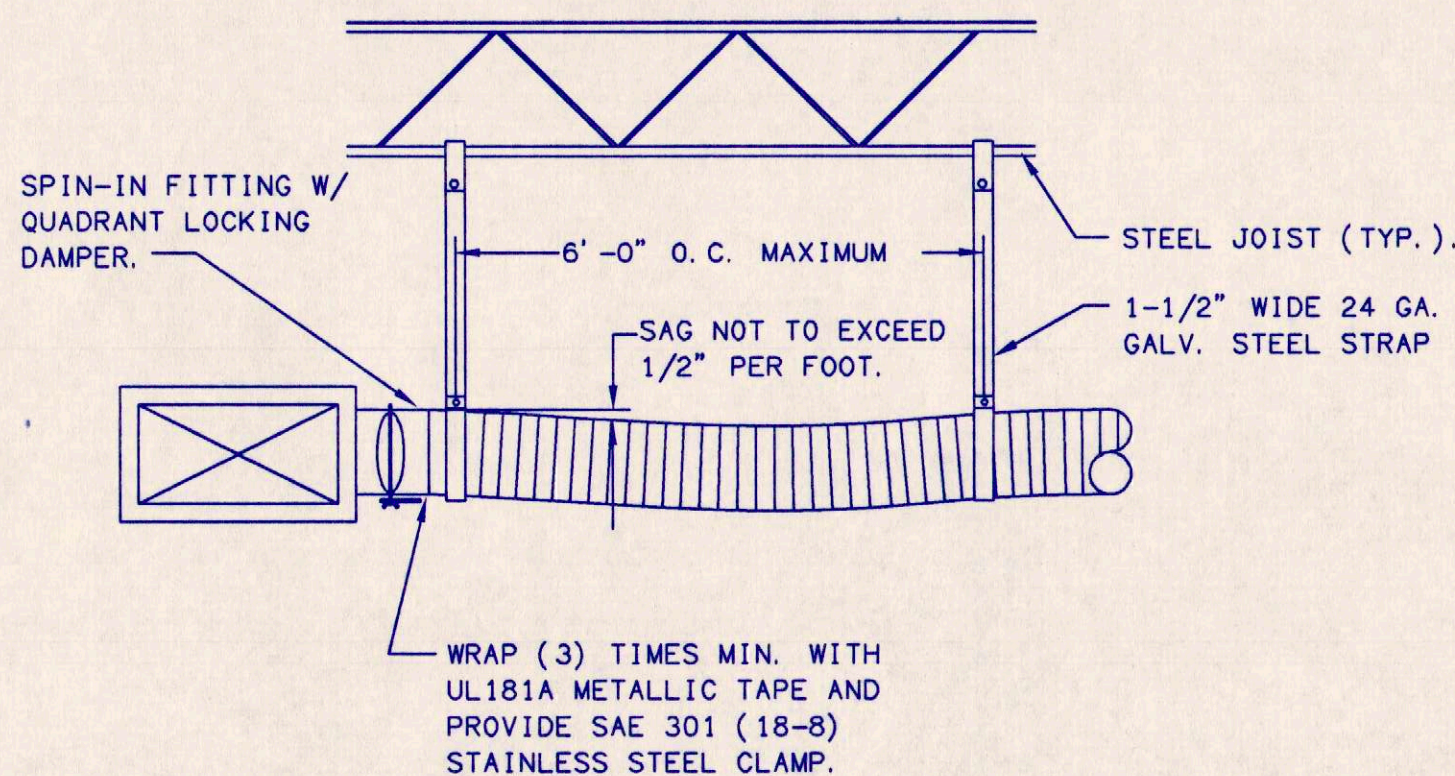

FLEXIBLE DUCT SUPPORT NOT TO SCALE

INSTALLATION TO BE IN ACCORDANCE WITH NFPA 24 (LATEST EDITION)
ALL PIPE AND FITTINGS TO BE INSPECTED PRIOR TO COVERING
ALL PIPE AND FITTINGS TO BE IN ACCORDANCE WITH NFPA 24
ALL PIPE AND FITTINGS TO BE TESTED AT 200 PSI FOR 2 HOURS
PIPE TO BE FLUSHED BEFORE CONNECTING TO SPRINKLERS
SPRINKLER SYSTEM POINT OF SERVICE IS AT THE 6" OS & Y ON BACKFLOW
ALL UNDERGROUND PIPE TO BE BURIED 30" MINIMUM BELOW GRADE
ALL PAINTING OF SPRINKLER PIPE BY OTHERS
WIRING AND MONITORING OF DEVICES IS BY OTHERS
ALL FDC'S TO BE LOCATED AS SHOWN AND SHALL MEET LOCAL CODE
FDC'S TO BE LOCATED SO AS TO FACE THE ROAD
ALL SPRINKLER UNDERGROUND FROM THE POINT OF SERVICE ON TO BE
INSTALLED BY A STATE LICENSED OR LICENSED SPRINKLER UNDGR. CONTRACTOR
SEE CLIMB PLANS BY OTHERS FOR DETAILS OF PIPING PRIOR TO THE POINT OF SERVICE
WAYNE AUTOMATIC TO START AT THE POINT OF SERVICE
ALL DUCTILE IRON PIPE TO BE CLASS 350
ALL PVC PIPE TO BE CLASS 200 (SDR-14) WITH TYTON SLIP JOINTS AND MECHANICAL JOINTS
CHANGED TO DIRECTOR TO BE RESTRAINED WITH MEQALUGS-RETAINING GLANDS
STRIPPING AS REQUIRED BY OTHERS

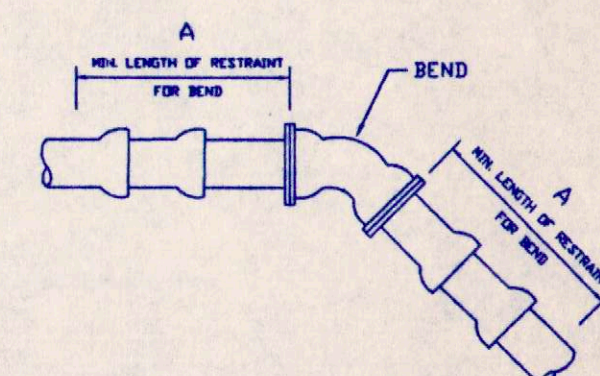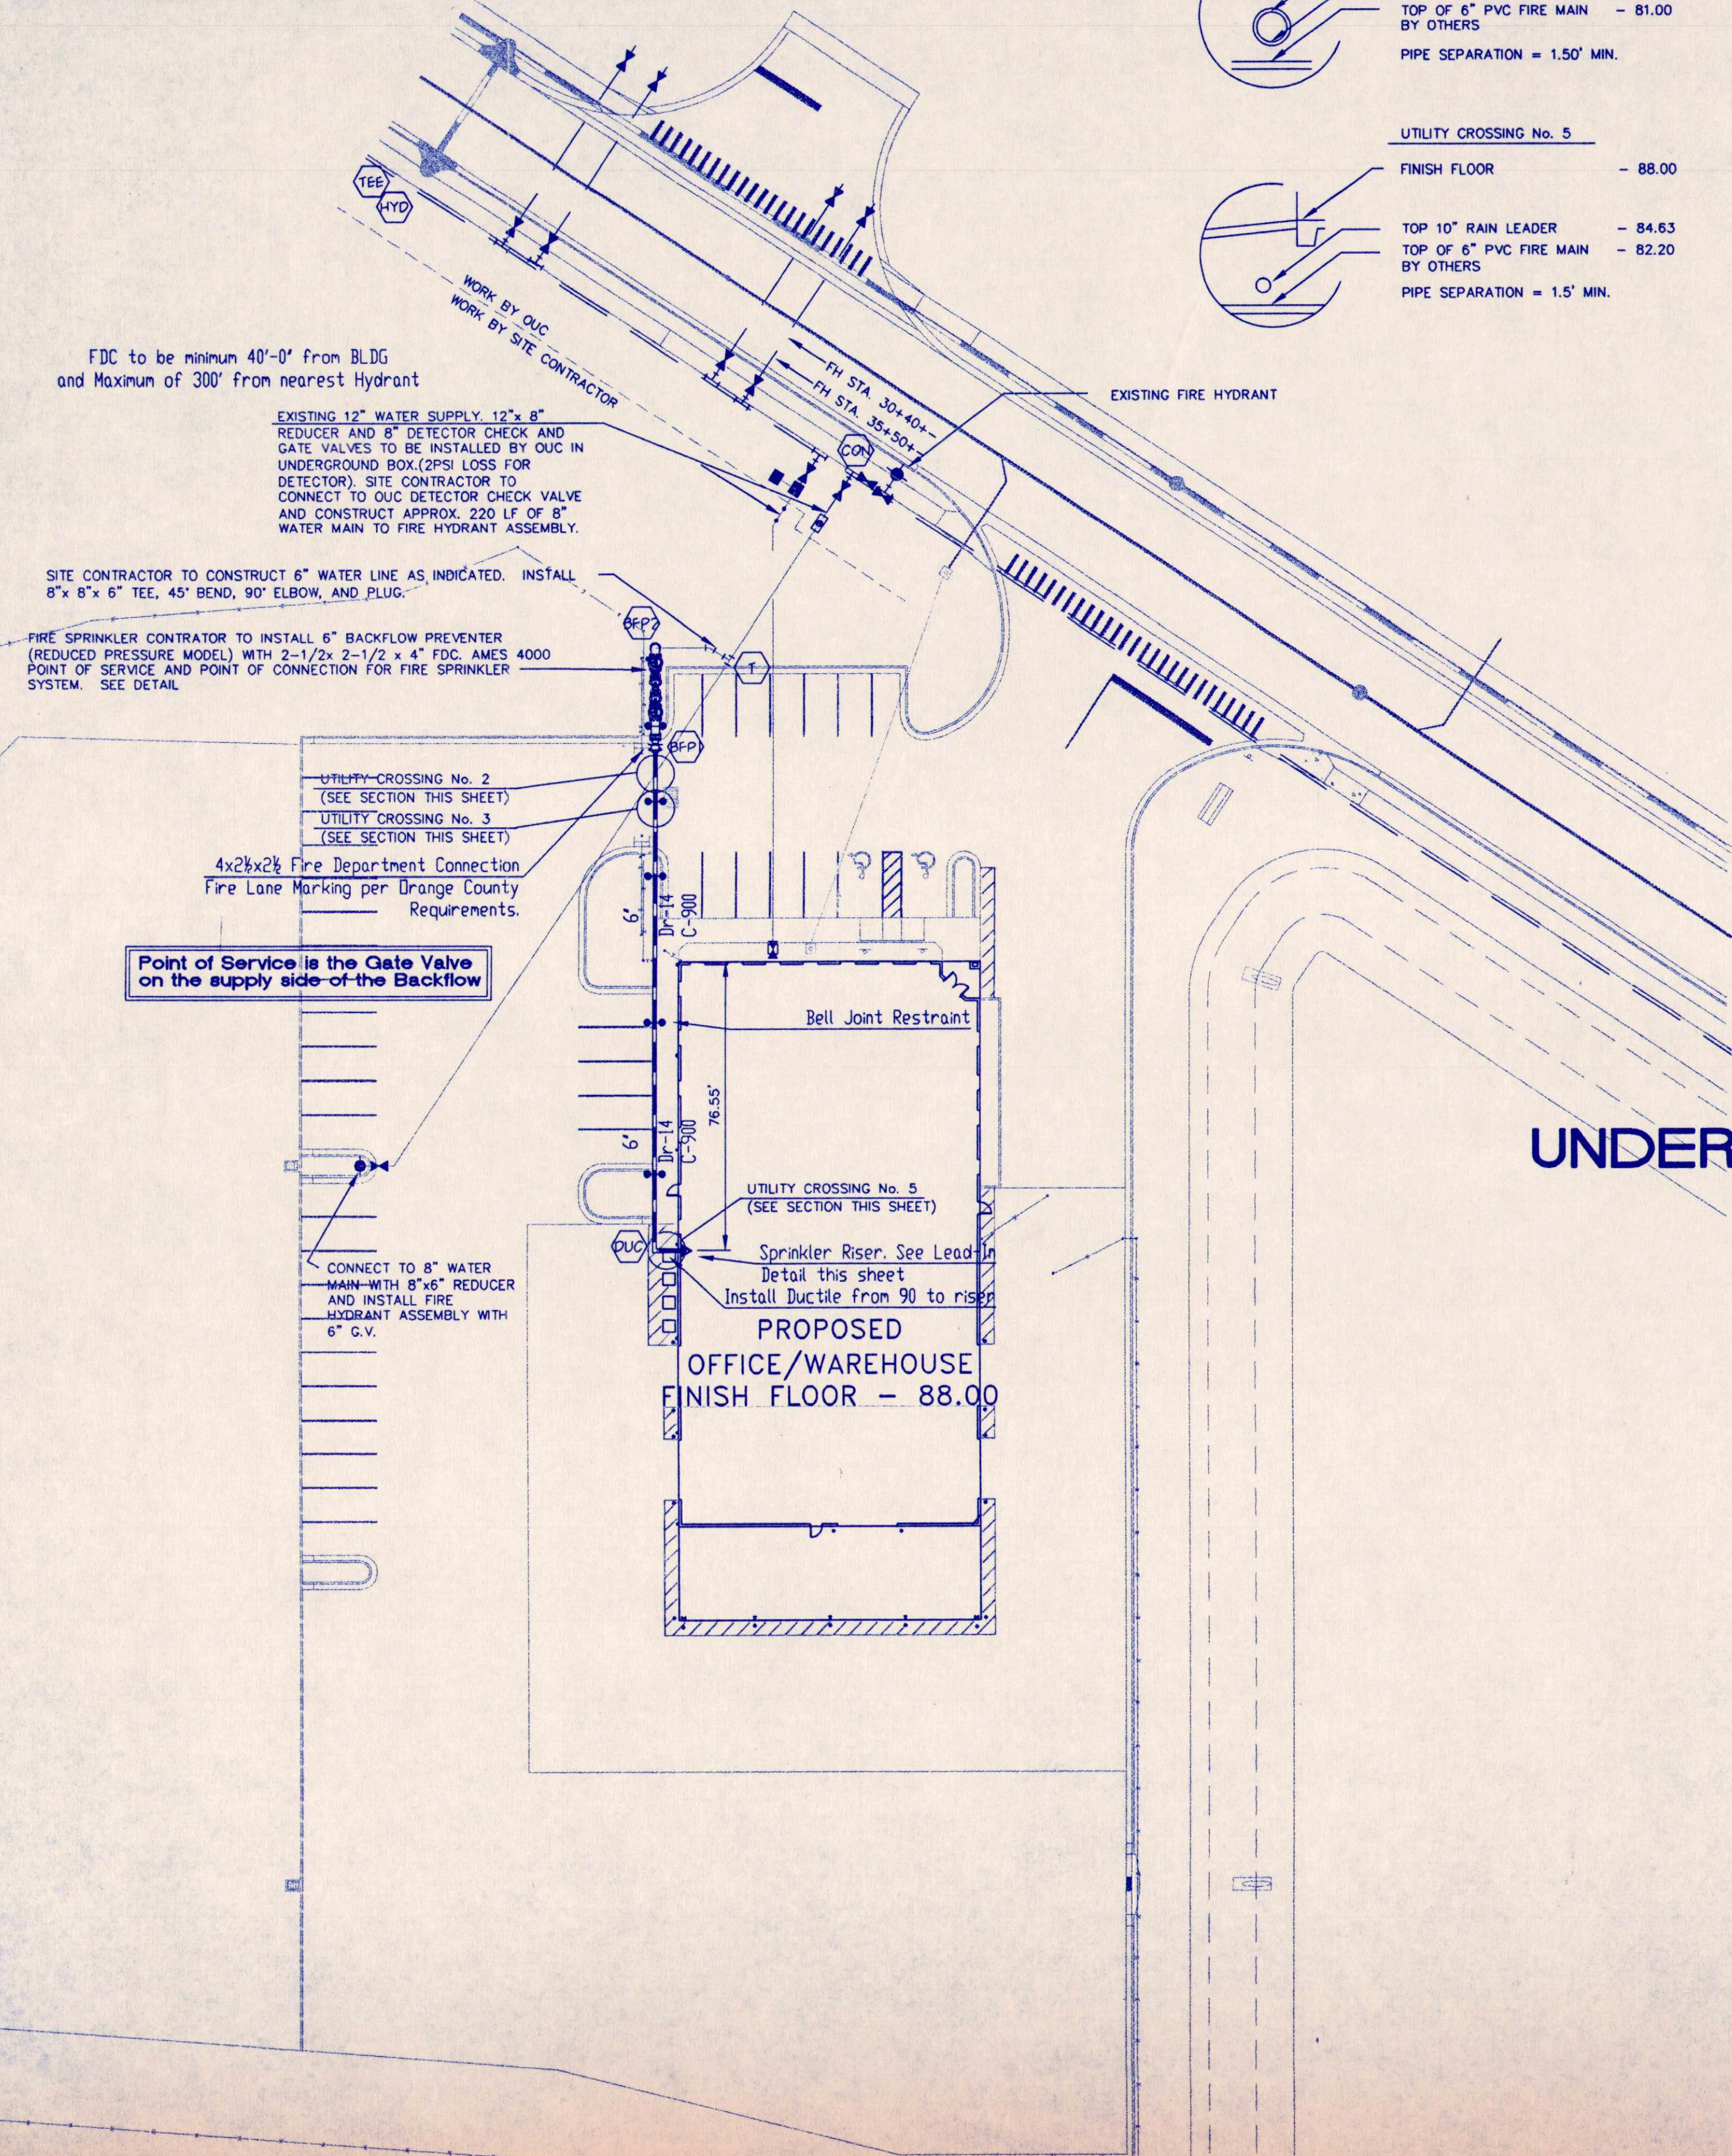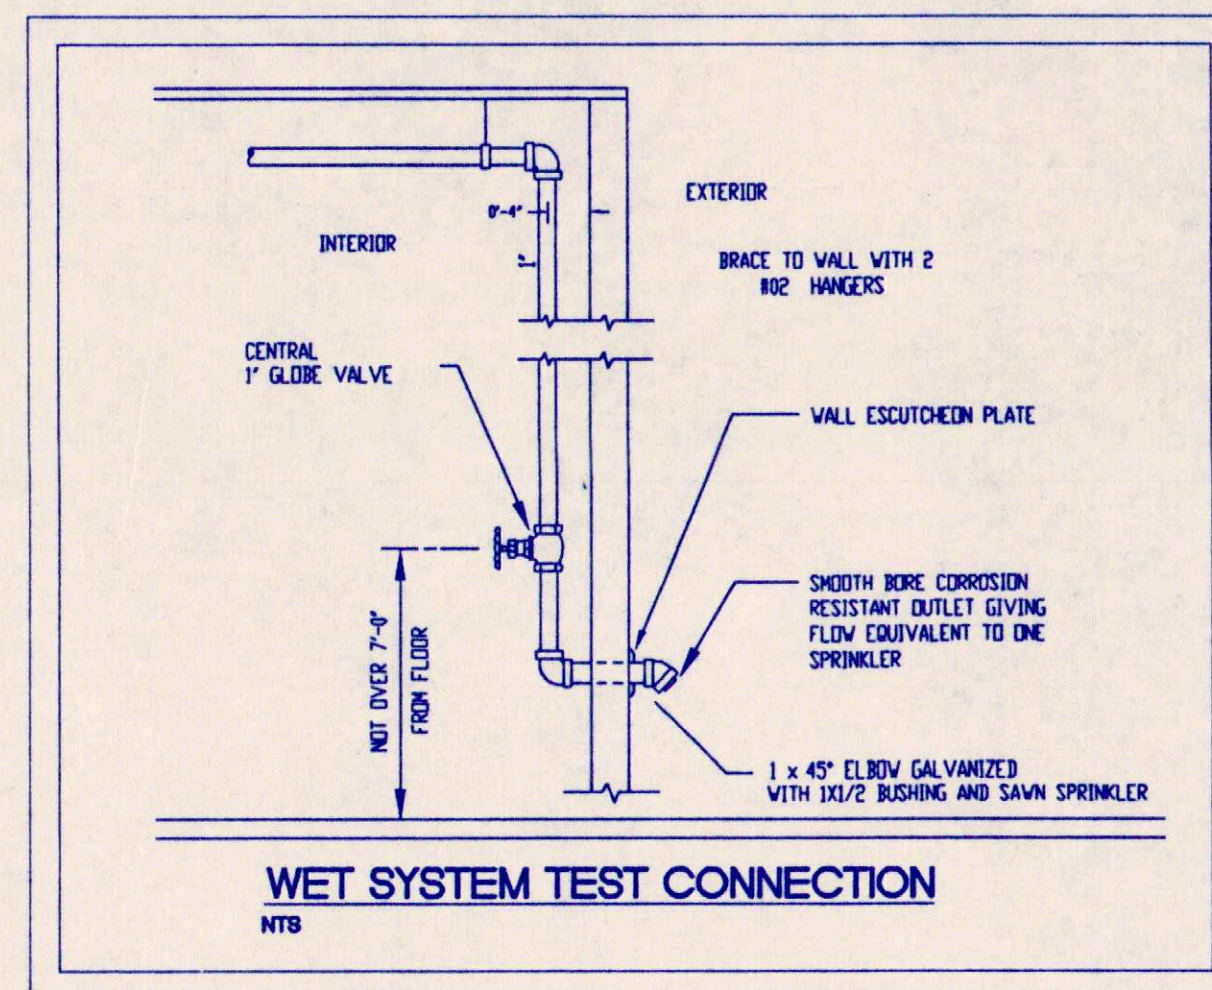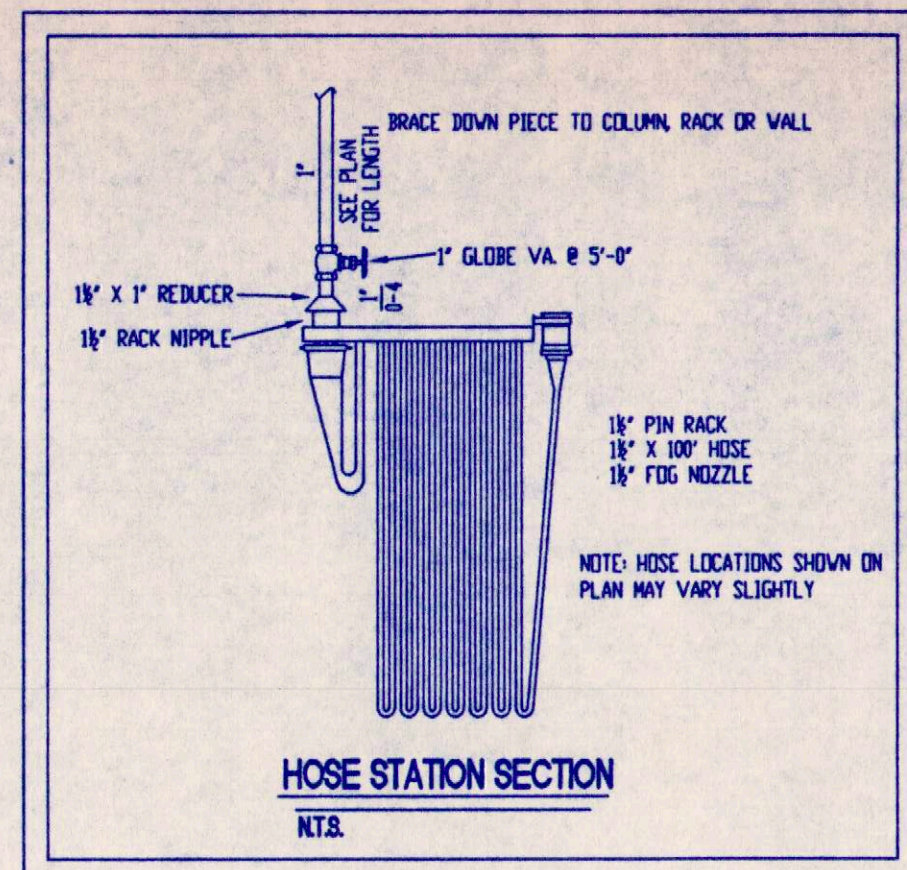


RESTRAIN 'A' (LJ)					
Fitting	4"	6"	8"	10"	12"
11k*	4" ^x	6" ^x	6" ^x	7" ^x	8" ^x
22k*	7" ^x	8" ^x	10" ^x	12" ^x	14" ^x
45°/ Offset	11" ^x	14" ^x	18" ^x	20" ^x	23" ^x
90°	16" ^x	20" ^x	27"	34"	39"
HEAD ENL. VALVE OR TEE	12" ^x	15" ^x	19" ^x	24"	28"

- A = MINIMUM FOOTAGE OF PIPE TO BE RESTRAINED ON EITHER SIDE OF FITTING
- MINIMUM ONE PIPE JOINT UPSTREAM AND DOWNSTREAM OF EACH FITTING SHALL BE RESTRAINED

NOTES:

1. THIS TABLE IS BASED ON:
 - a) MAXIMUM TEST PRESSURE OF 200 psi
 - b) LAYING CONDITION SC/NATIVE
 - c) POOR SOIL CONDITIONS
 - d) HORIZONTAL BENDS
 - e) USING PVC
2. RESTRAINING DEVICES FOR PVC PIPE SHALL BE BY MEANS OF EQUIPPED UNIFORM-BITS
3. ANY ADDITIONAL FITTINGS WITHIN THE RESTRAINED SECTION SHALL BE RESTRAINED ACCORDINGLY.

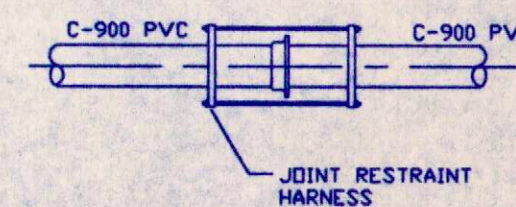

TO BE USED ONE (1) JOINT ON EACH SIDE OF ALL 45 DEGREE BENDS AND TWO (2) JOINTS ON EACH SIDE OF ALL 90 DEGREE BENDS AND THE OUTLET SIDE OF TEES.

UNDERGROUND JOINT RESTRAINT

AS BUILTS

11-30-00

Site Plan

HAZARD
Fire Protection Engineering, Inc.
222 CAPITOL COURT OCOEE, FL 34761
PH (407) 877-5589 FAX: (407) 856-8026
Certificate of Authorization Number 7523

COPYRIGHT
ALL DOCUMENTS, INCLUDING ORIGINAL DRAWINGS, SPECIFICATIONS, FIELD NOTES, ESTIMATES AND DATA, INCLUDING COMPUTER PROGRAMS PURSUANT TO THIS PROCEEDING AND VARIOUS RESEARCH PROJECTS OF THE FIRM, ARE THE PROPERTY OF THE FIRM (WAFF) AS INSTRUMENTS OF SERVICE. THEY ARE NOT INTENDED, NOR REPRESENTED TO BE SUITABLE FOR REUSE BY ANY OTHER PARTY. ANY REUSE OR ADAPTATION OF THE INFORMATION CONTAINED HEREIN, WITHOUT SPECIFIC WRITTEN PERMISSION FROM WAFF, WILL BE AT THE CLIENT'S SOLE RISK, WITHOUT LIABILITY, OR LEGAL EXPENSE. WAFF, AND WILL ENTITLE WAFF TO FURTHER COMPENSATION AT RATES TO BE AGREED ON BETWEEN WAFF AND THE CLIENT. THE CLIENT SHALL ALSO INDEMNIFY AND HOLD WAFF HARMLESS FROM ALL CLAIMS, DAMAGES AND EXPENSES INCURRED BY WAFF IN USING ATTORNEY'S FEES RESULTING FROM ANY SUCH PERMISSIONS.

NO.	DATE	REVISIONS	
1			
2			
3			
4			

WATER SUPPLY INFORMATION			
STATIC PRESSURE	63 PSI	FIRE PUMP	N/A
RESIDUAL PRESSURE	54 PSI	SIZE GPM @ PSI	N/A
PYDOT READING	43 PSI	TYPE OF DRIVER	
FLOW IN G.P.M.	1100 GPM	ELECTRICAL REQS	N/A
DATE OF TEST	08-03-00		
TIME OF TEST	08:30 AM		
TEST TAKEN BY	NAME AUTOMATIC FIRE SPINMLERS INC		
HYDRANT LOCATION	300' WEST OF CONNECTION TO SITE		

DESIGN CRITERIA	
SYSTEM /	
DESIGN AREA	
DENSITY	
DESIGN AREA S.F.	
PSI REQ'D @ BASR	
GPM REQ'D @ BASR	
PSI REQ'D @ TEST	
GPM REQ'D @ TEST	
/ SPRINKLES	
DESIGN AREA	
ELEVATION @	
HIGHEST SPKR	
HOSE INSIDE-OUT	

[illegible][illegible]


Automatic Fire Sprinklers, Inc.
ORLANDO - JACKSONVILLE - FORT MYERS
POMPANO - CHARLOTTE, NC
CORPORATE OFFICE - ORLANDO, FLORIDA
222 CAPITOL COURT OCOEE, FL 32761
PHONE: (407) 656-3030 FAX: (407) 656-8026

PRIME CONSTRUCTION
JET STREAM DR. (LOT 7)
ORLANDO FLORIDA

PERTREE CONSTRUCTION
845 SUNSHINE LANE
ALTAMONTE SPRINGS, FL 32714

SYSTEM #	SITE PLAN
DRAWN BY:	PETE SCHWAB
CHECKED BY:	L.J. SMITH P.E.
LISTED BY:	PETE SCHWAB
DATE:	MAY 25, 2000
SCALE:	1"=30'-0"
AHA:	ORANGE COUNTY
CONTRACT #	00155
SHEET #	

FP 1 OF 2

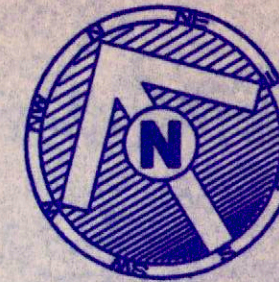

HAZARD
Fire Protection Engineering, Inc.
222 CAPITOL COURT
ORLANDO, FL 32761
PH (407) 877-5599 FAX (407) 856-8026
Certificate of Authorization Number 7523

COPYRIGHT
This document is the property of HAZARD Fire Protection Engineering, Inc. and is not to be reproduced, stored in a retrieval system, or transmitted in any form or by any means, electronic, mechanical, photocopying, recording, or by any information storage and retrieval system, without the prior written permission of HAZARD Fire Protection Engineering, Inc. The user of this document is hereby notified that any unauthorized reproduction or use of this document is strictly prohibited and may result in legal action.

IMPORTANT OTHER INFORMATION This drawing is based on the drawings and specifications of the project. It is the responsibility of the user to verify the accuracy of the information provided and to ensure that the drawings and specifications are in accordance with the latest edition of the applicable codes and standards.

NO.	DATE	REVISIONS	BY
1	01-16-00	ADJUSTMENTS FOR DUCTWORK	PTS

WATER SUPPLY INFORMATION	
STATIC PRESSURE	51 PSI
RESIDUAL PRESSURE	54 PSI
PISTON READING	43 PSI
FLOW IN G.P.M.	1100 GPM
DATE OF TEST	06-05-98
TIME OF TEST	8:30 AM
TEST TAKEN BY	WAYNE AUTOMATIC FIRE SPRINKLERS INC.
HYDRANT LOCATION	300' WEST OF CONNECTION TO SITE

DESIGN CRITERIA	
SYSTEM #	ALL
DESIGN AREA	11
DENSITY	1.0
DESIGN AREA S.F.	1521
PSI HEAD @ BASE	45.258
GPM HEAD @ BASE	369.20
PSI HEAD @ TEST	58.255
GPM HEAD @ TEST	369.20
SPRINKLER IN DESIGN AREA	14
HOSE WGS/OUTS	100 / 0

SPRINKLERS SPACING	
SYMBOL	MAXIMUM
1	25' x 25' LIGHT HAZ
2	12' x 12' LIGHT HAZ

SPRINKLERS	
SYMBOL	QUANTITY
1	54
2	85
139	TOTAL PER SYSTEM
139	TOTAL THIS SHEET



WAYNE
Automatic Fire Sprinklers, Inc.
ORLANDO - JACKSONVILLE - FORT MYERS
POMPAU - CHARLOTTE, NC
CORPORATE OFFICE - ORLANDO, FLORIDA
222 CAPITOL COURT ORLANDO, FL 32761
PHONE (407) 856-3000 FAX (407) 856-8026

PRIME CONSTRUCTION
JET STREAM DR. (LOT 7)
ORLANDO FLORIDA

PRIME CONSTRUCTION
846 SUNSHINE LANE
ATLANTA, GA 30328


SYSTEM #	BUILDING PLAN
DRAWN BY	PETE SCHWAR
CHECKED BY	L.J. SMITH P.E.
TOTAL A/R	139
DATE	AUGUST 8, 2000
SCALE	AS NOTED
AREA	ORANGE COUNTY
CONTRACT #	00155
SHEET #	

FP2 OF 2


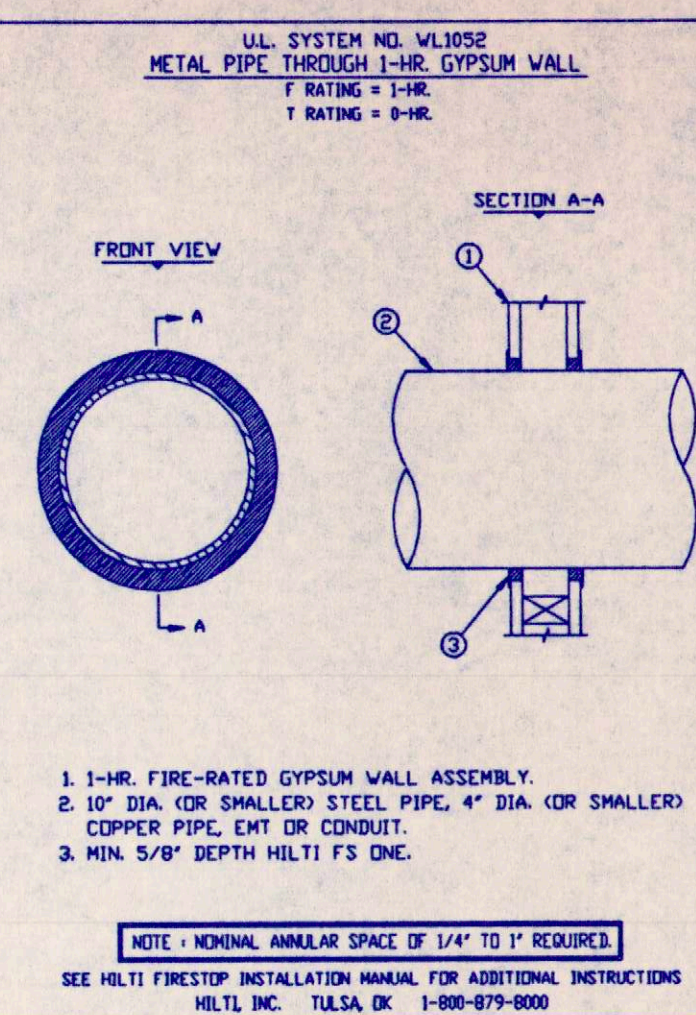
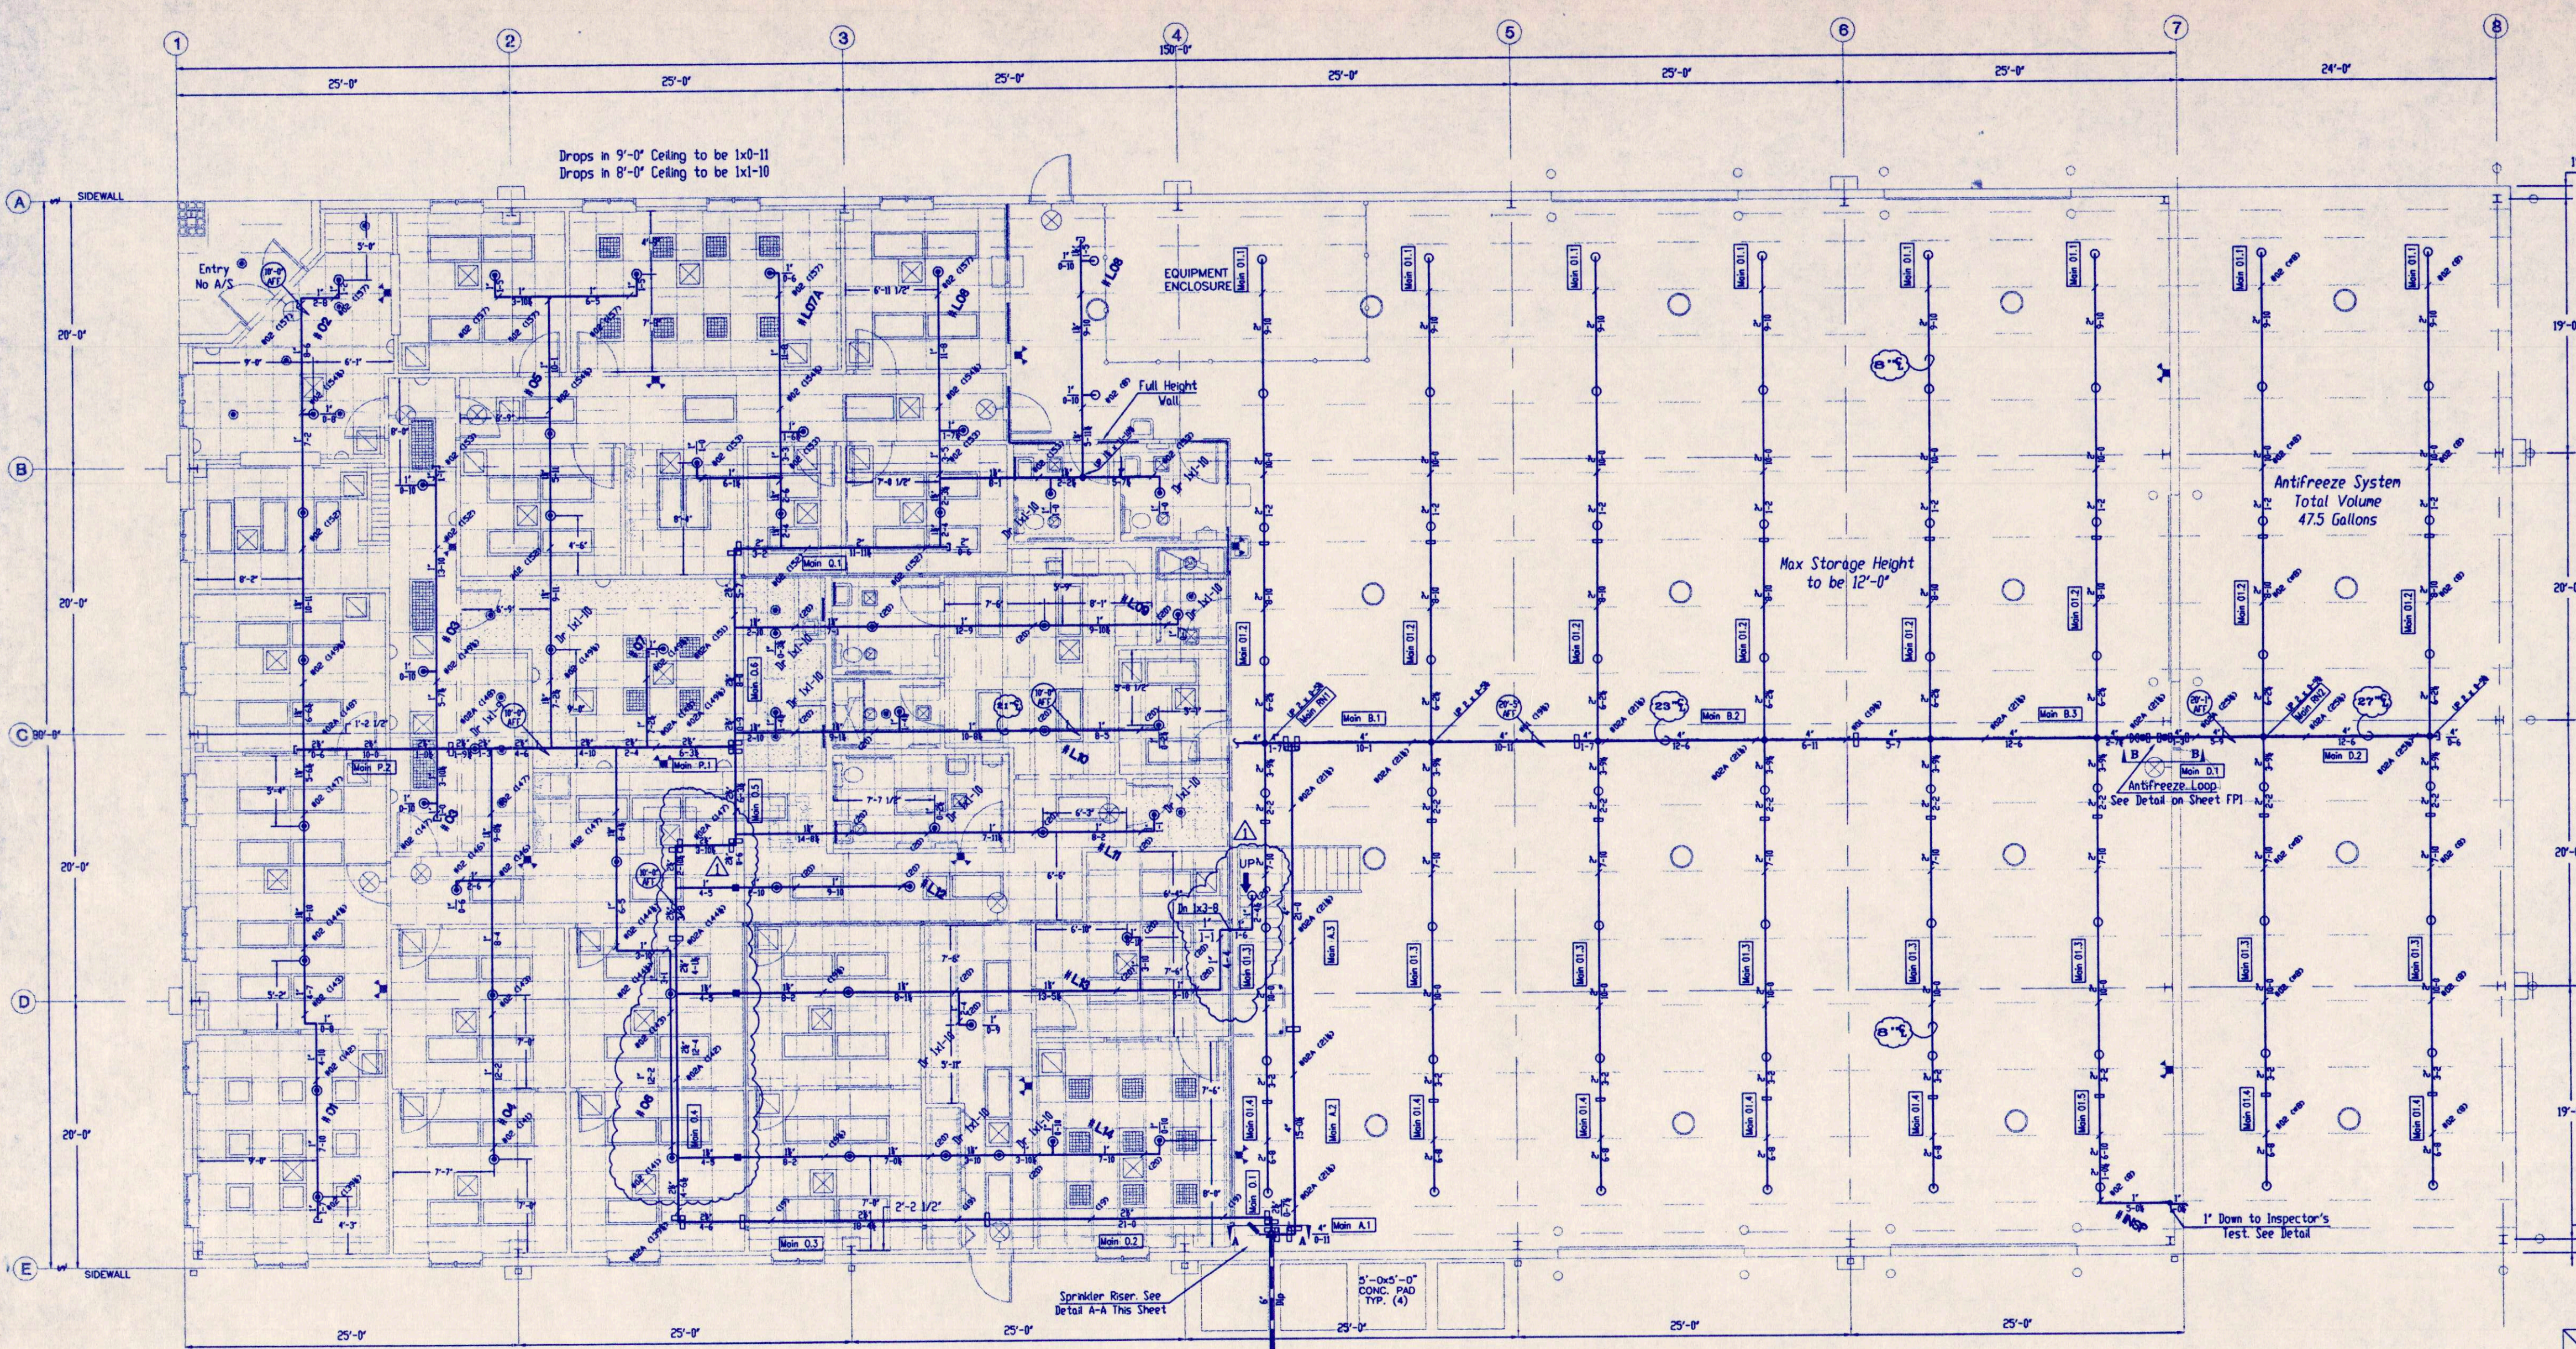


AS BUILT

GENERAL NOTES
SYSTEM TO BE DESIGNED AND INSTALLED IN ACCORDANCE WITH NFPA 13 1994 EDITION AND NFPA 25 LATEST REVISION, EDITION 1994.
ALL PIPE AND FITTINGS TO BE IN ACCORDANCE WITH THE FOLLOWING LIST:
ALL PIPE 1" TO 1 1/2" TO BE SCHEDULE 40 BLACK STEEL UNO
ALL FITTINGS 1" TO 1 1/2" TO BE 90° ELBOWS STANDARD CLASS UNO
ALL STEEL PIPING WITH GROOVED OR WELDED FITTINGS TO BE BLACK SCHEDULE 40 TO MEET ANSI/ASTM 100 STANDARDS.
THREADED FITTINGS WILL BE STANDARD BLACK CAST/DUCTILE IRON ANSI B16.4 CLASS 125.
ALL PIPE 2" AND LARGER TO BE DUCTILE BLACK STEEL UNO
ALL FITTINGS 2" AND LARGER TO BE GROOVED/LARGED AND/OR WELDED UNO
STEEL PIPING WITH GROOVED OR WELDED FITTINGS WILL BE BLACK RAINWALL PIPE TO MEET ANSI/ASTM A750 STANDARDS.
GROOVED FITTINGS WILL BE DUCTILE IRON ASTM A538
ALL HANGERS TO BE SPACED IN ACCORDANCE WITH NFPA 13 AND THEIR LISTING
ALL PENETRATIONS TO BE SEALED WITH "MILT" FIRE CAULK IN ACCORDANCE WITH DETAILS PROVIDED.
ALL UNDERGROUND PIPING TO BE FLUSHED BEFORE CONNECTION TO ABOVEGROUND PIPING.
ALL PIPING SHALL BE INSPECTED AND APPROVED BY PROPER AUTHORITIES PRIOR TO COVERING WITH DRYWALL AND CORRESPONDING TEST PIPERS FORWARDED TO PROPER RECEIPTS.
ALL SOFFITS ARE BY OTHERS
MAX SPACING OF SPRINKLERS TO BE AS NOTED ON EACH SHEET.
ALL WORK OF DEVICES BY OTHERS
ALL PAINTING OF PIPE TO BE BY OTHERS
MAINTENANCE OF THE SPRINKLER SYSTEM IS THE RESPONSIBILITY OF THE OWNER.
MAINTENANCE SHALL BE IN ACCORDANCE WITH NFPA 25 LATEST REVISION, EDITION 1994.
SPARE SPRINKLERS AND APPROPRIATE WRENCHES SHALL BE PROVIDED IN ACCORDANCE WITH NFPA 13
CONNECTIONS TO BUILDING ALARM SYSTEM AND ANY MONITORING IS BY OTHERS
SPRINKLERS MAY BE LIMITED FROM THE FOLLOWING:
LIGHT PORCHES AND BALCONIES THAT ARE OF NON-COMBUSTIBLE CONSTRUCTION
INDICATES HYDRAULIC REFERENCE NOTES

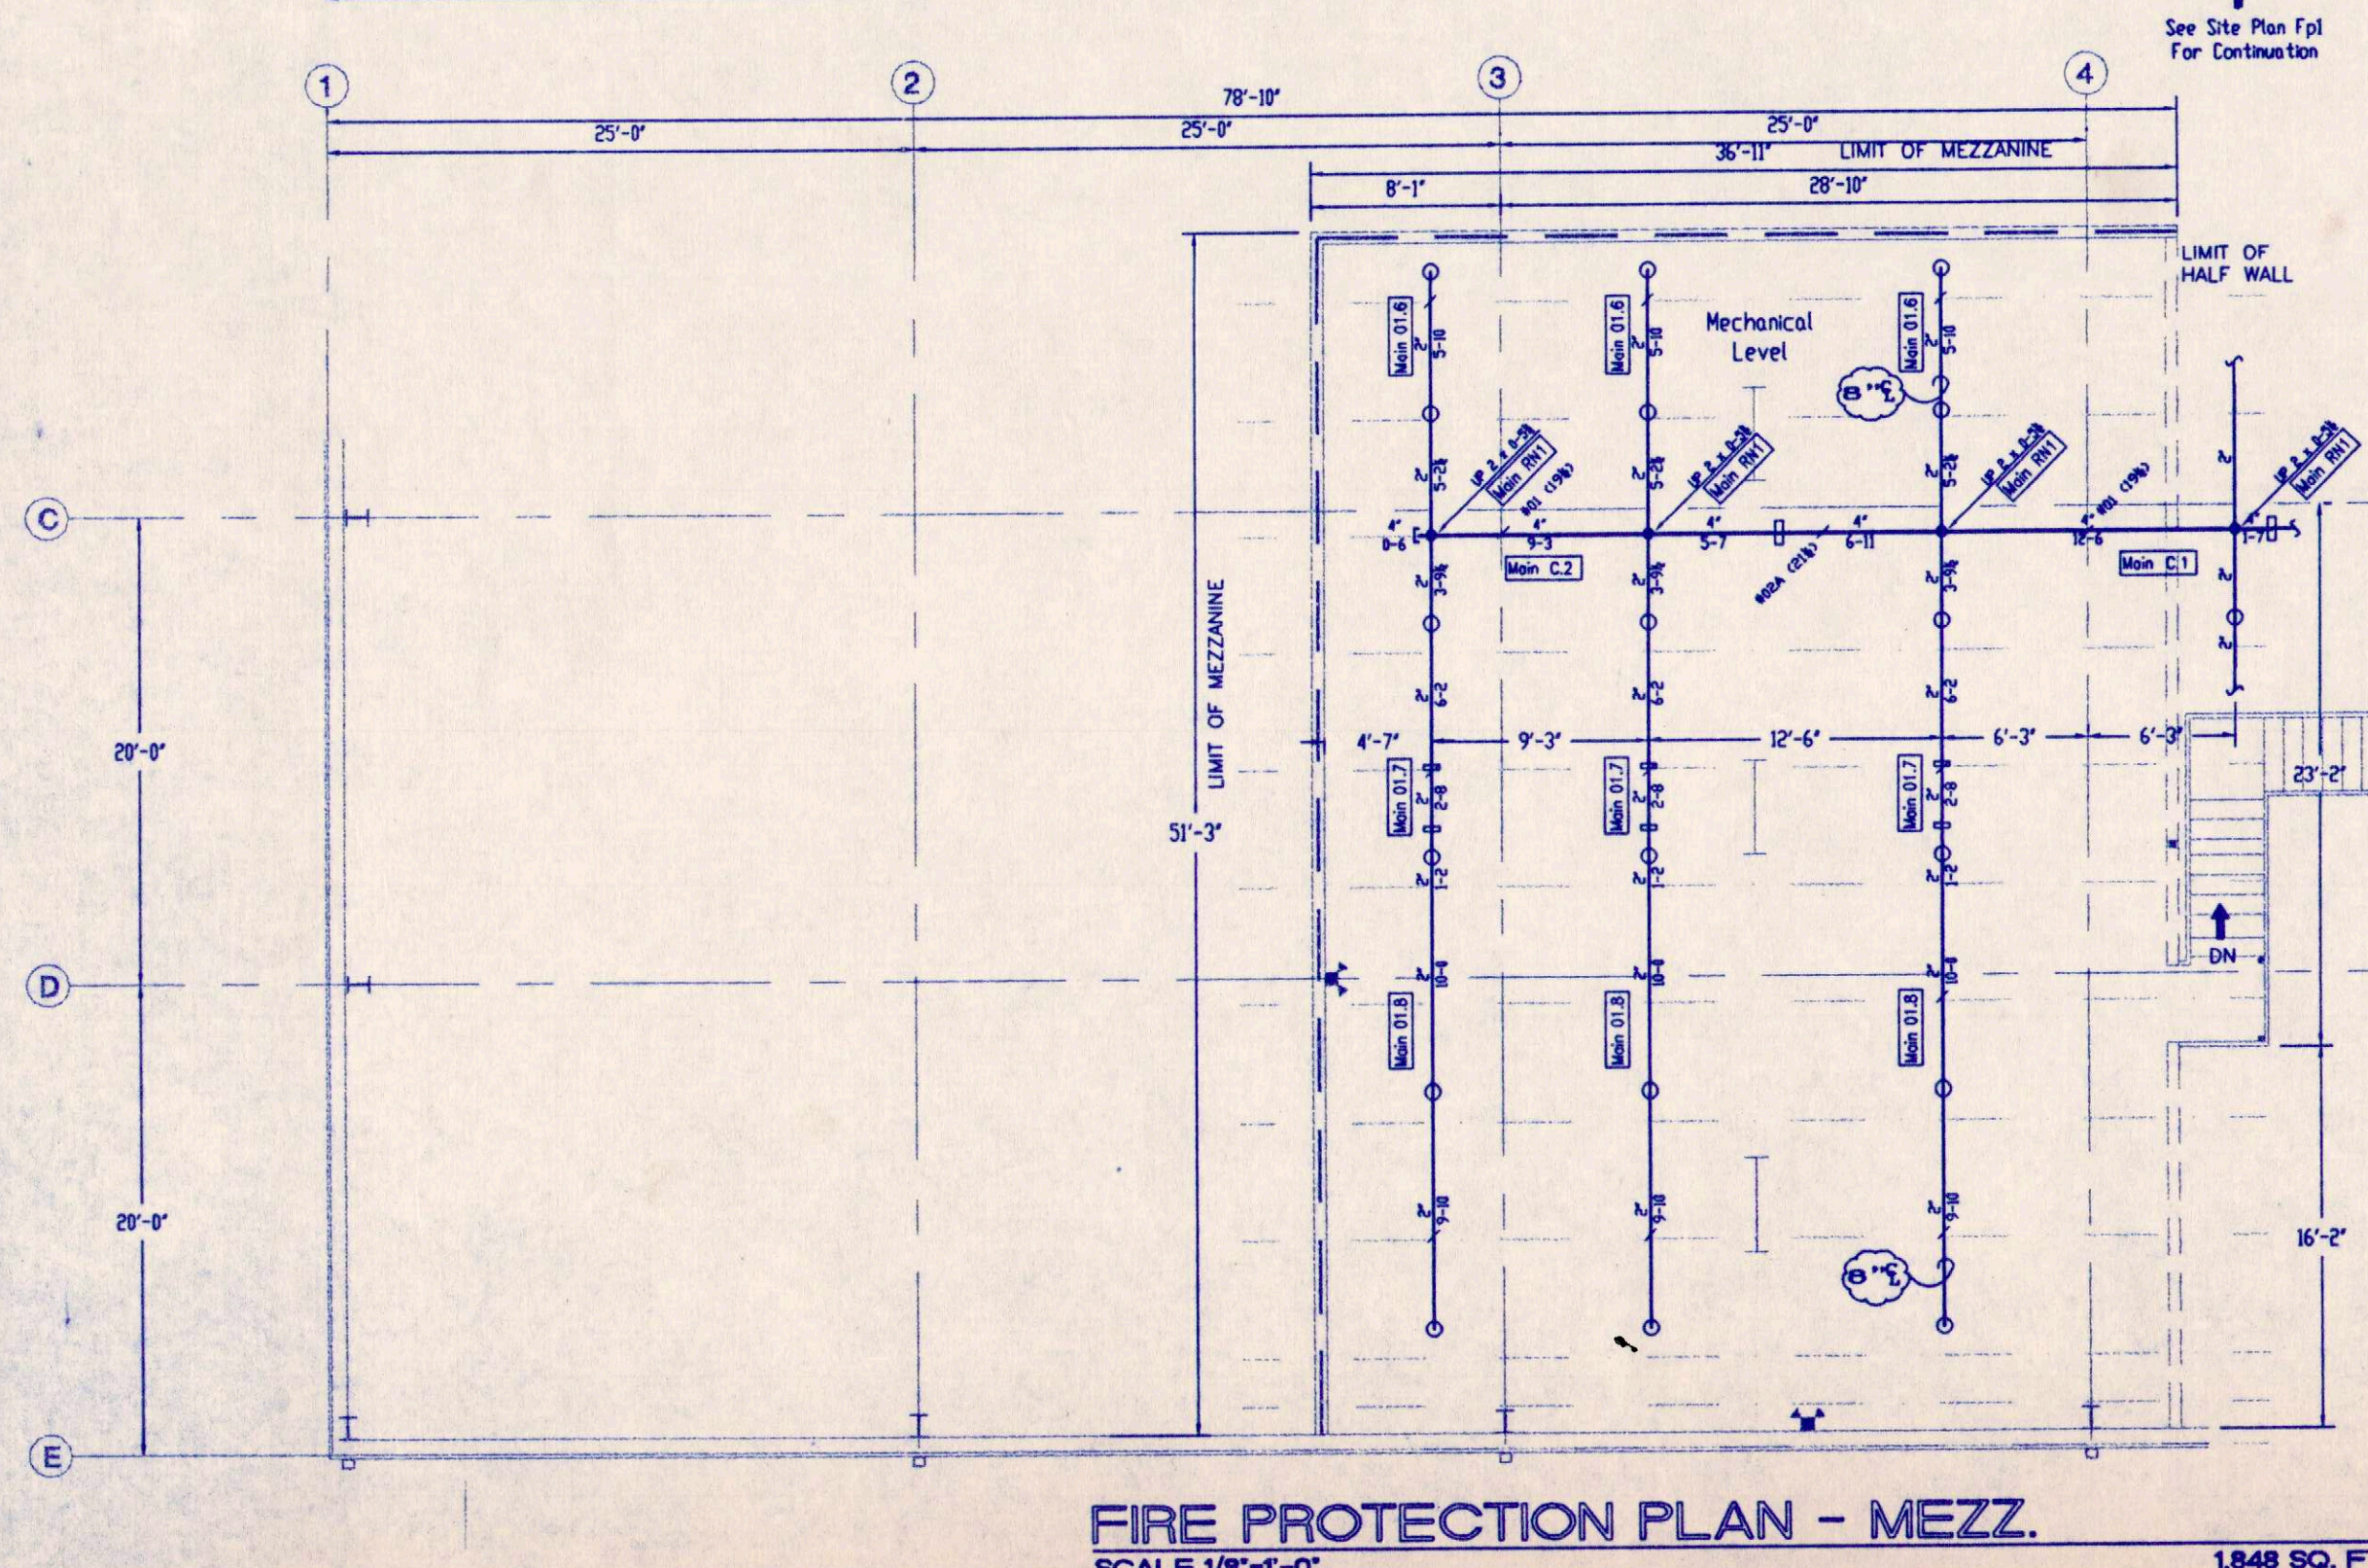

FIRE PROTECTION PLAN
SCALE 1/8"=1'-0"

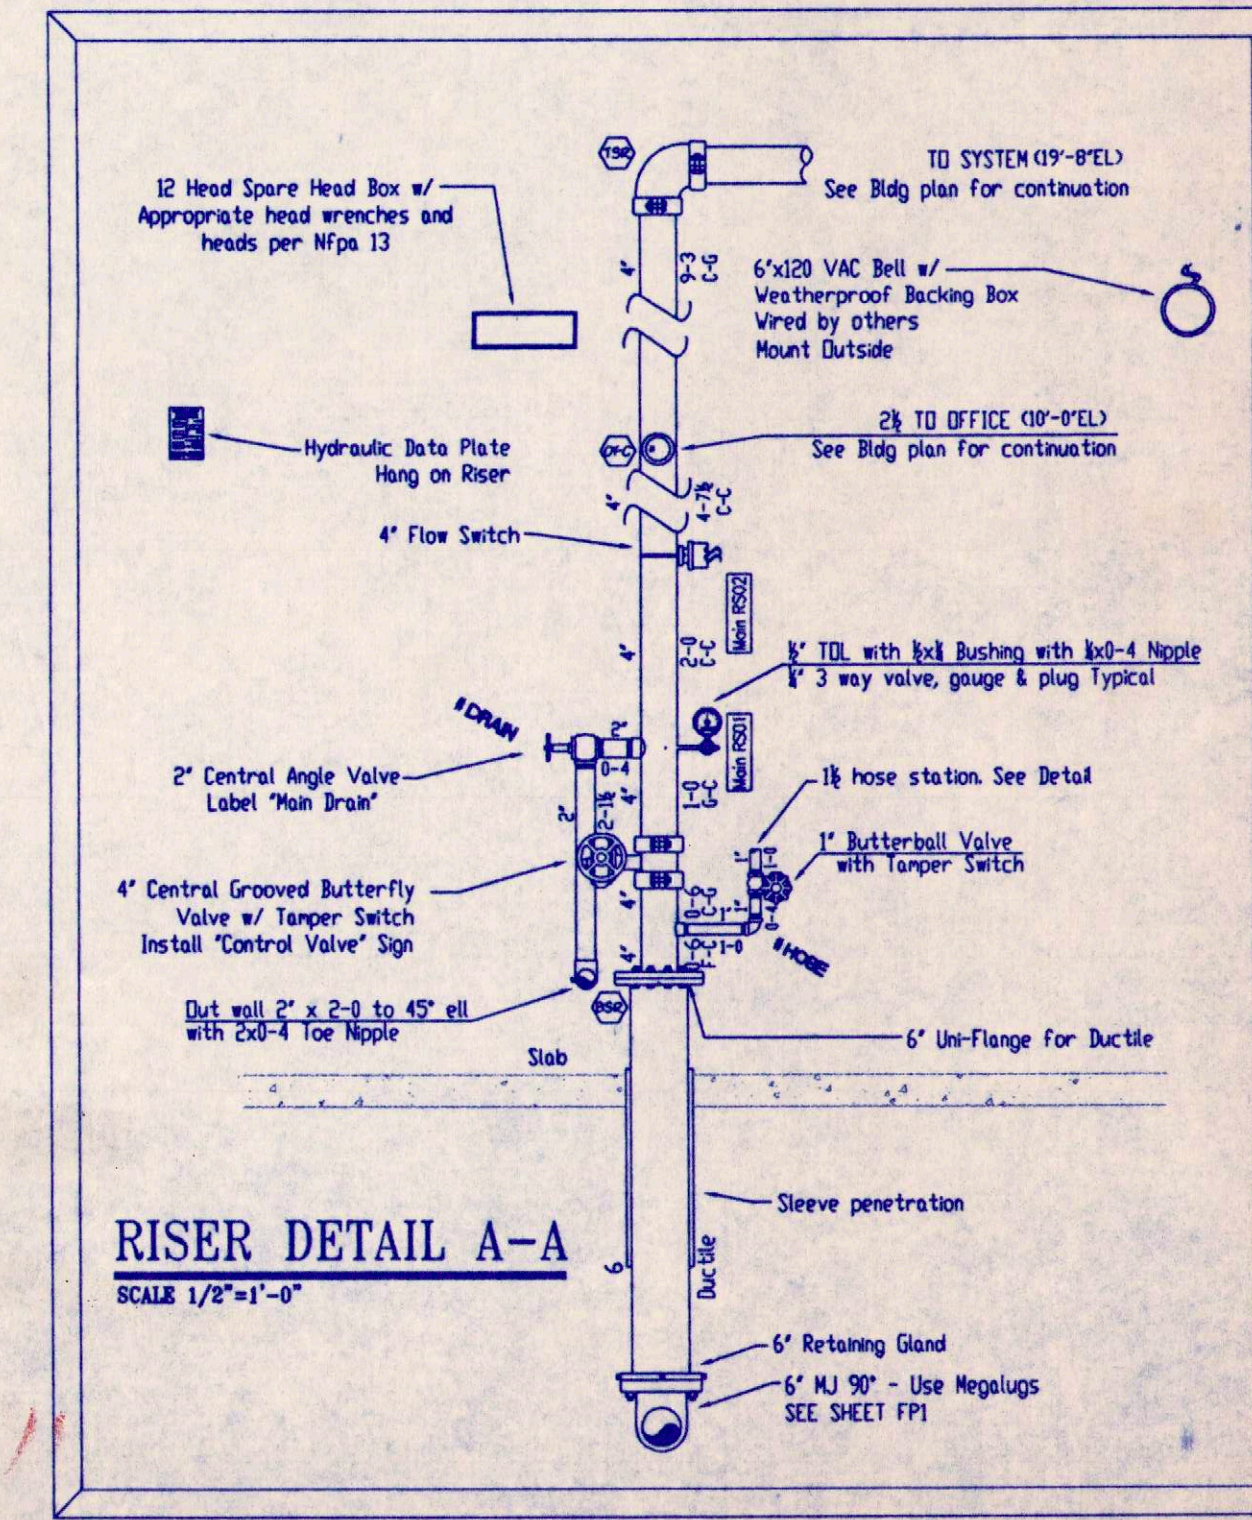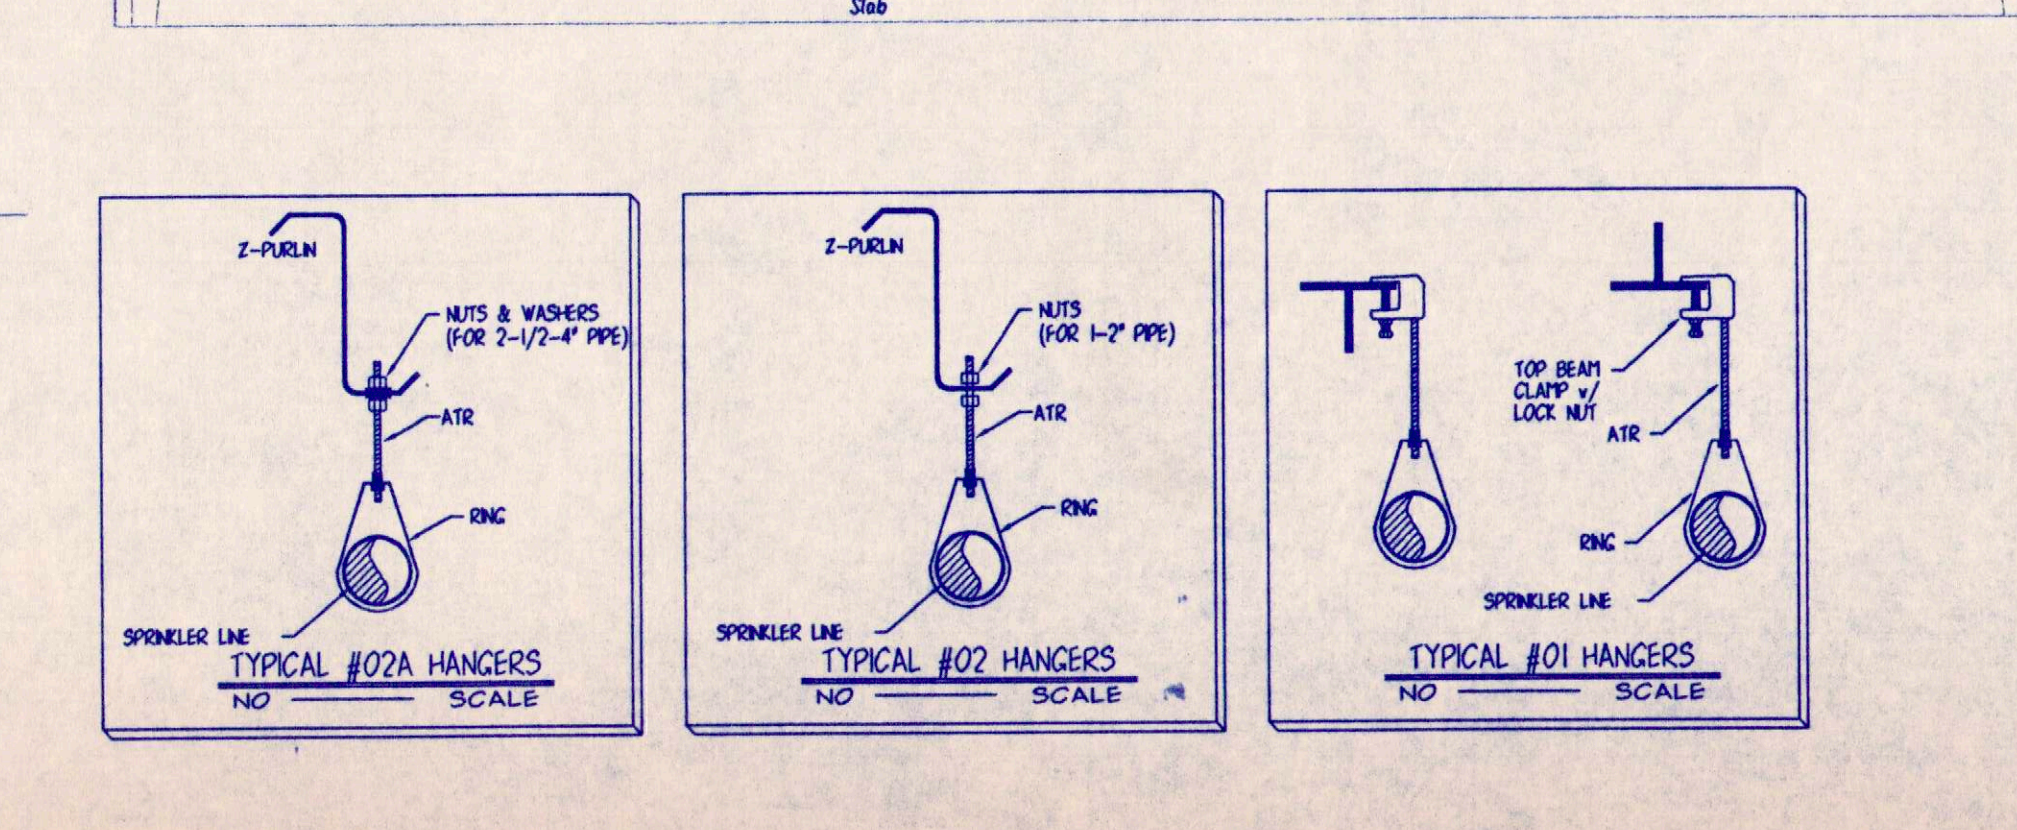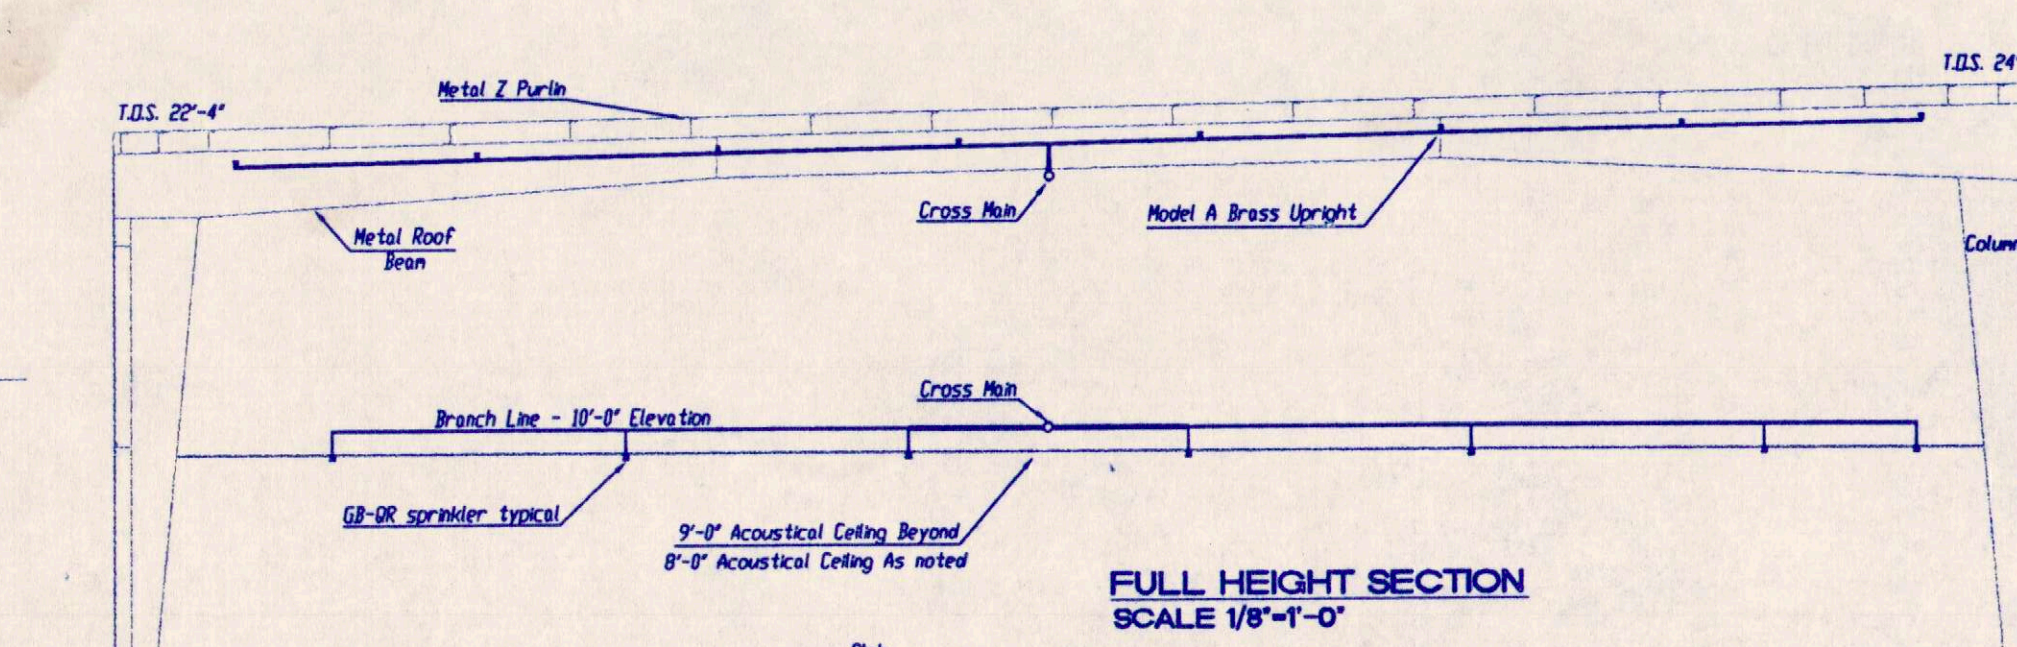

Building Plan


Business Furniture • Facilities Planning • Design
THOMAS W. RUFF & CO.
911 S. ORLANDO AVE. • Maitland, Florida 32751
Phone: (407) 628-2400 Fax: (407) 628-8941

REVISION	DATE	DRAWN
06	04/25/00	FLW
05	04/24/00	FLW
04	04/20/00	FLW
03	04/18/00	FLW
02	04/06/00	FLW
01	04/04/00	FLW

The data in this document incorporate proprietary rights of Thomas W. Ruff Co. Any party accepting this document does so in confidence and agrees that it shall not be duplicated in whole or in part, nor disclosed to others without the written consent of Thomas W. Ruff Co.

SALES	AMY GORDON
DESIGNED	OTHERS
DRAWN	F. LEE WHITENER
PROJECT	NO00021.DWG
DATE	03/07/2000
SCALE	1/4"=1'-0"
APPROVED	

PRIME CONSTRUCTION
PRELIMINARY FURNITURE PLAN
ORLANDO, FLORIDA
5528 FORCE FOUR PKWY.
PHONE: (407) 856-8180 FAX:

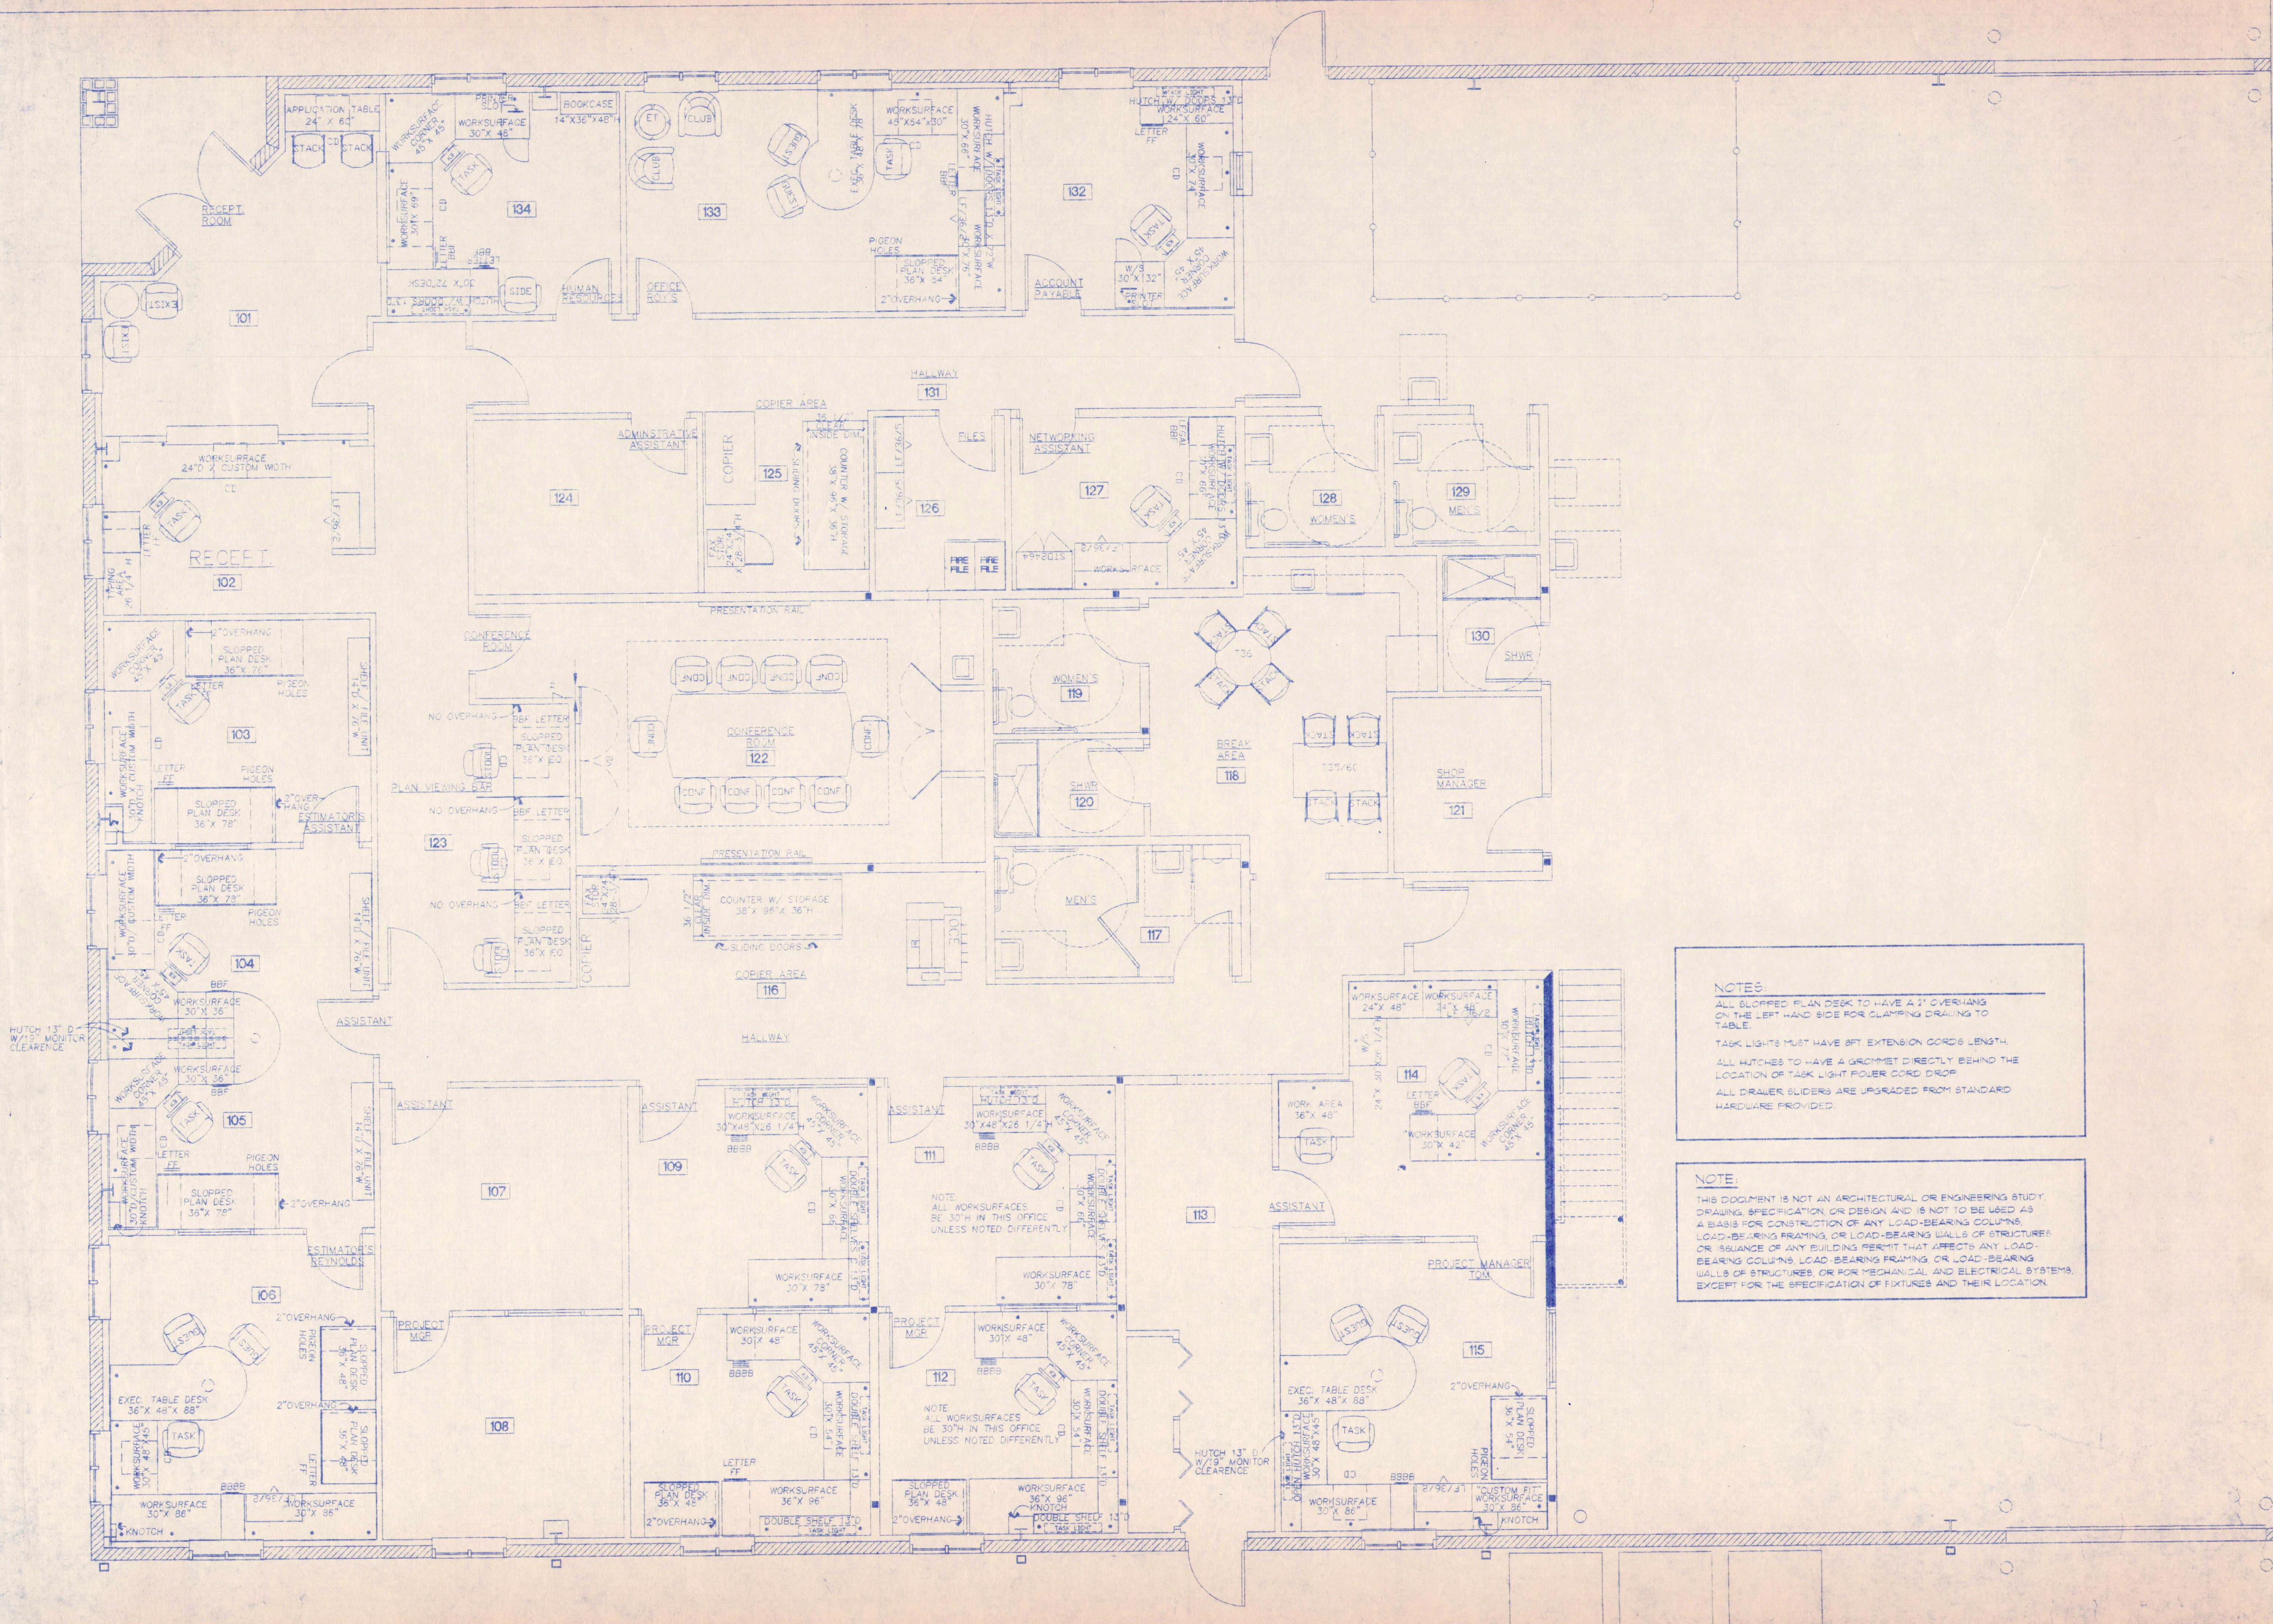

NOTES:
ALL SLOPPED PLAN DESK TO HAVE A 2" OVERHANG ON THE LEFT HAND SIDE FOR CLAMPING DRAWING TO TABLE.
TASK LIGHTS MUST HAVE 8FT EXTENSION CORDS LENGTH.
ALL HUTCHES TO HAVE A GROMMET DIRECTLY BEHIND THE LOCATION OF TASK LIGHT POWER CORD DROP.
ALL DRAWER SLIDERS ARE UPGRADED FROM STANDARD HARDWARE PROVIDED.

NOTE:
THIS DOCUMENT IS NOT AN ARCHITECTURAL OR ENGINEERING STUDY, DRAWING, SPECIFICATION, OR DESIGN AND IS NOT TO BE USED AS A BASIS FOR CONSTRUCTION OF ANY LOAD-BEARING COLUMNS, LOAD-BEARING FRAMING OR LOAD-BEARING WALLS OF STRUCTURES OR ISSUANCE OF ANY BUILDING PERMIT THAT AFFECTS ANY LOAD-BEARING COLUMNS, LOAD-BEARING FRAMING OR LOAD-BEARING WALLS OF STRUCTURES, OR FOR MECHANICAL AND ELECTRICAL SYSTEMS, EXCEPT FOR THE SPECIFICATION OF FIXTURES AND THEIR LOCATION.